




	PHASE-2	
	TENDER DRAWINGS LIST-03	
SR. NO.	DRAWINGS	DRAWING NO.
	ARCHITECTURAL PACKAGE	
1	SITE PLAN-SURVEY	TD-A.0.01
2	SITE DEVELOPMENT LAYOUT	TD-DR-A.0.01
3	LOWER GORUND FLOOR PLAN	TD-DR-A.1.01
4	UPPER GROUND FLOOR	TD-DR-A.1.02
5	TERRACE PLAN	TD-DR-A.1.03
6	ROOF PLAN	TD-DR-A.1.04
7	REFLECTED CEILING PLAN-LOWER GROUND FLOOR	TD-DR-A.1.05
8	REFELECTED CEILING PLAN-UPPER GROUND FLOOR	TD-DR-A.1.06
9	SECTIONS	TD-DR-A.2.01
10	ELEVATIONS	TD-DR-A.3.01
11	TYPICAL TOILET DETAIL	TD-DR-A.4.01
12	DOOR DETAILS	TD-DR-A.4.02
13	GLAZING DETAILS	TD-DR-A.4.03
14	WINDOW DETAILS	TD-DR-A.4.04

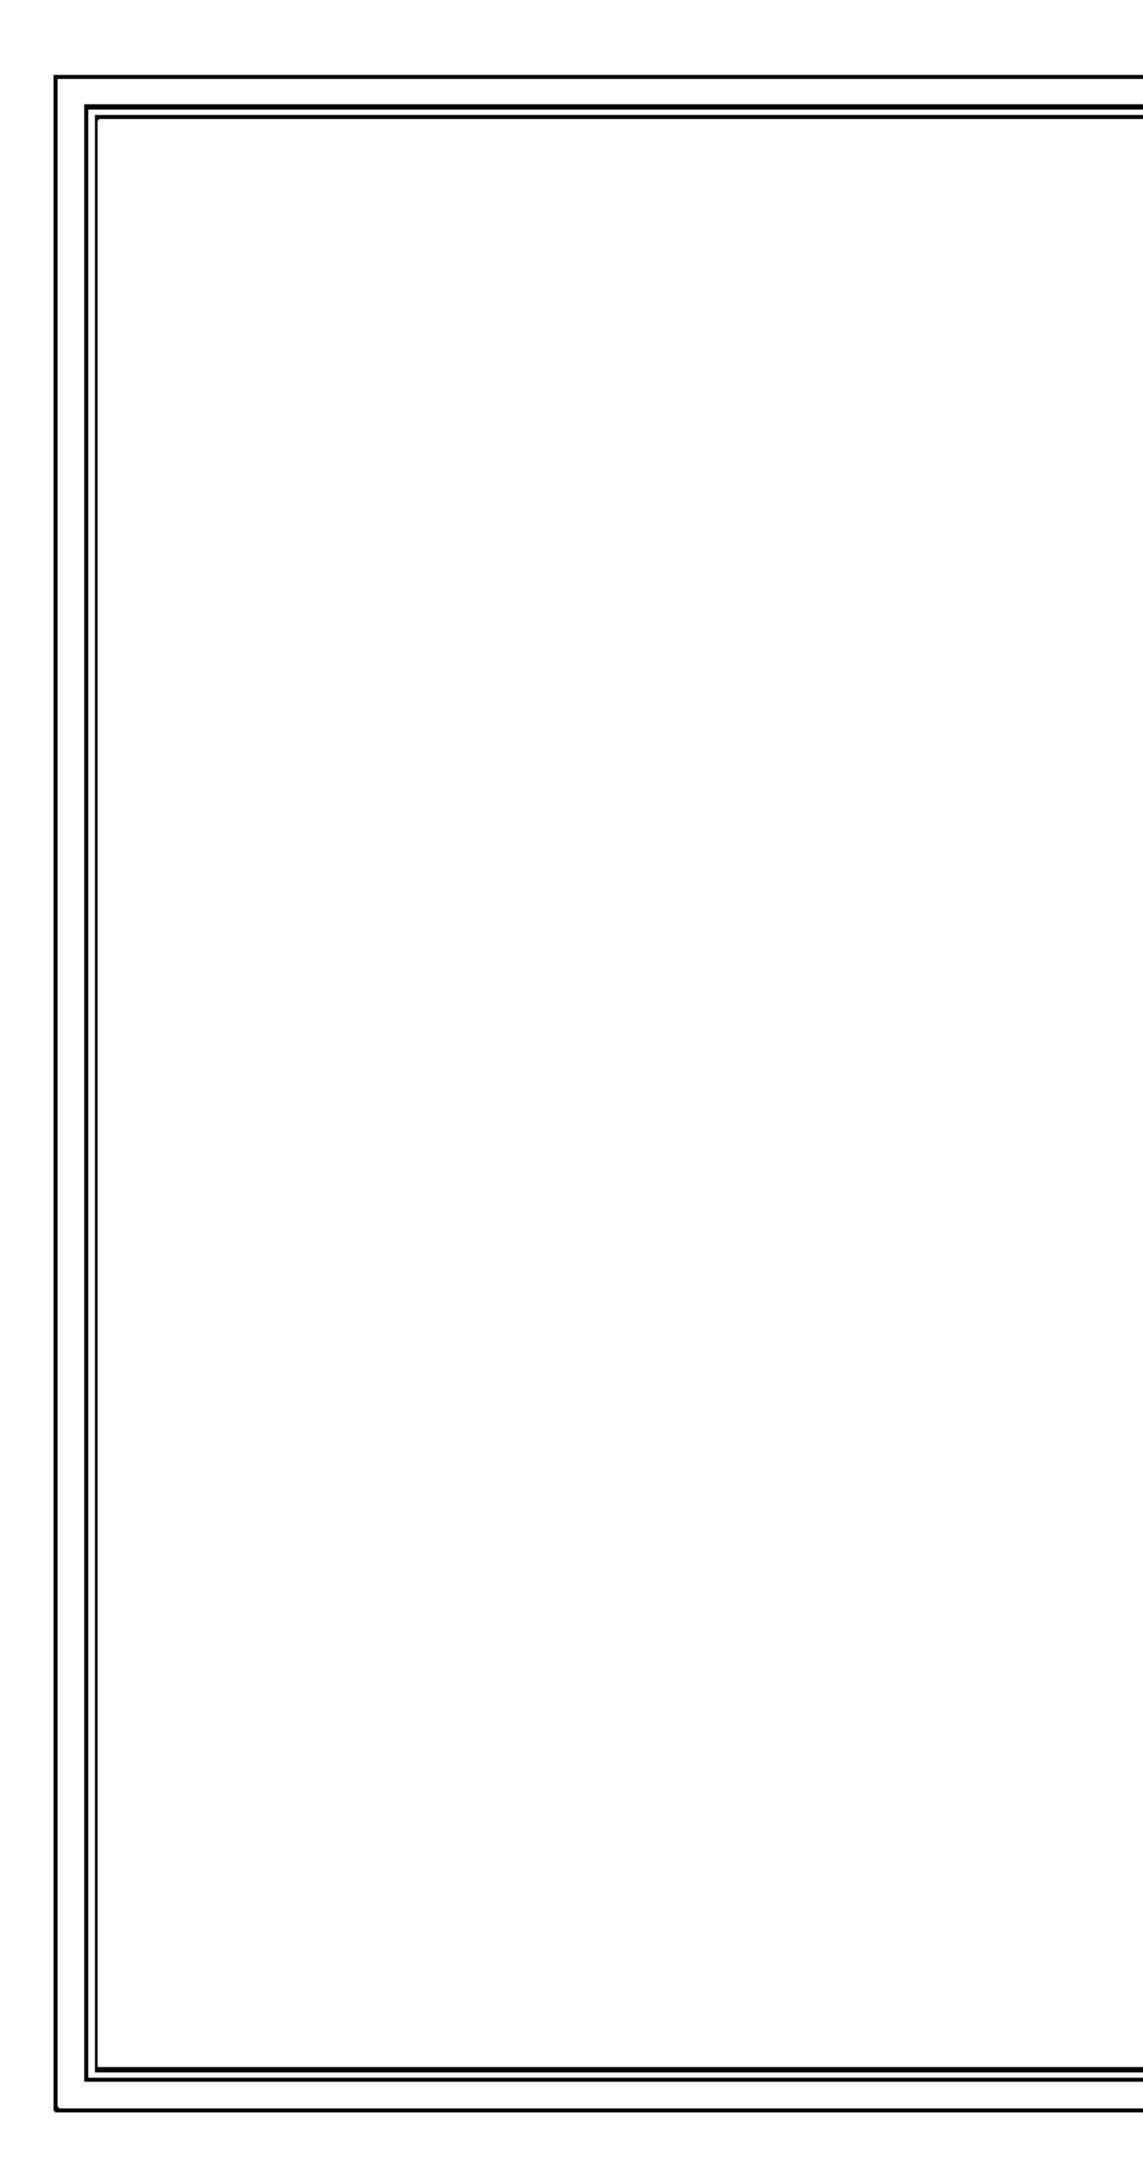


# ARCHITECTURAL DRAWINGS

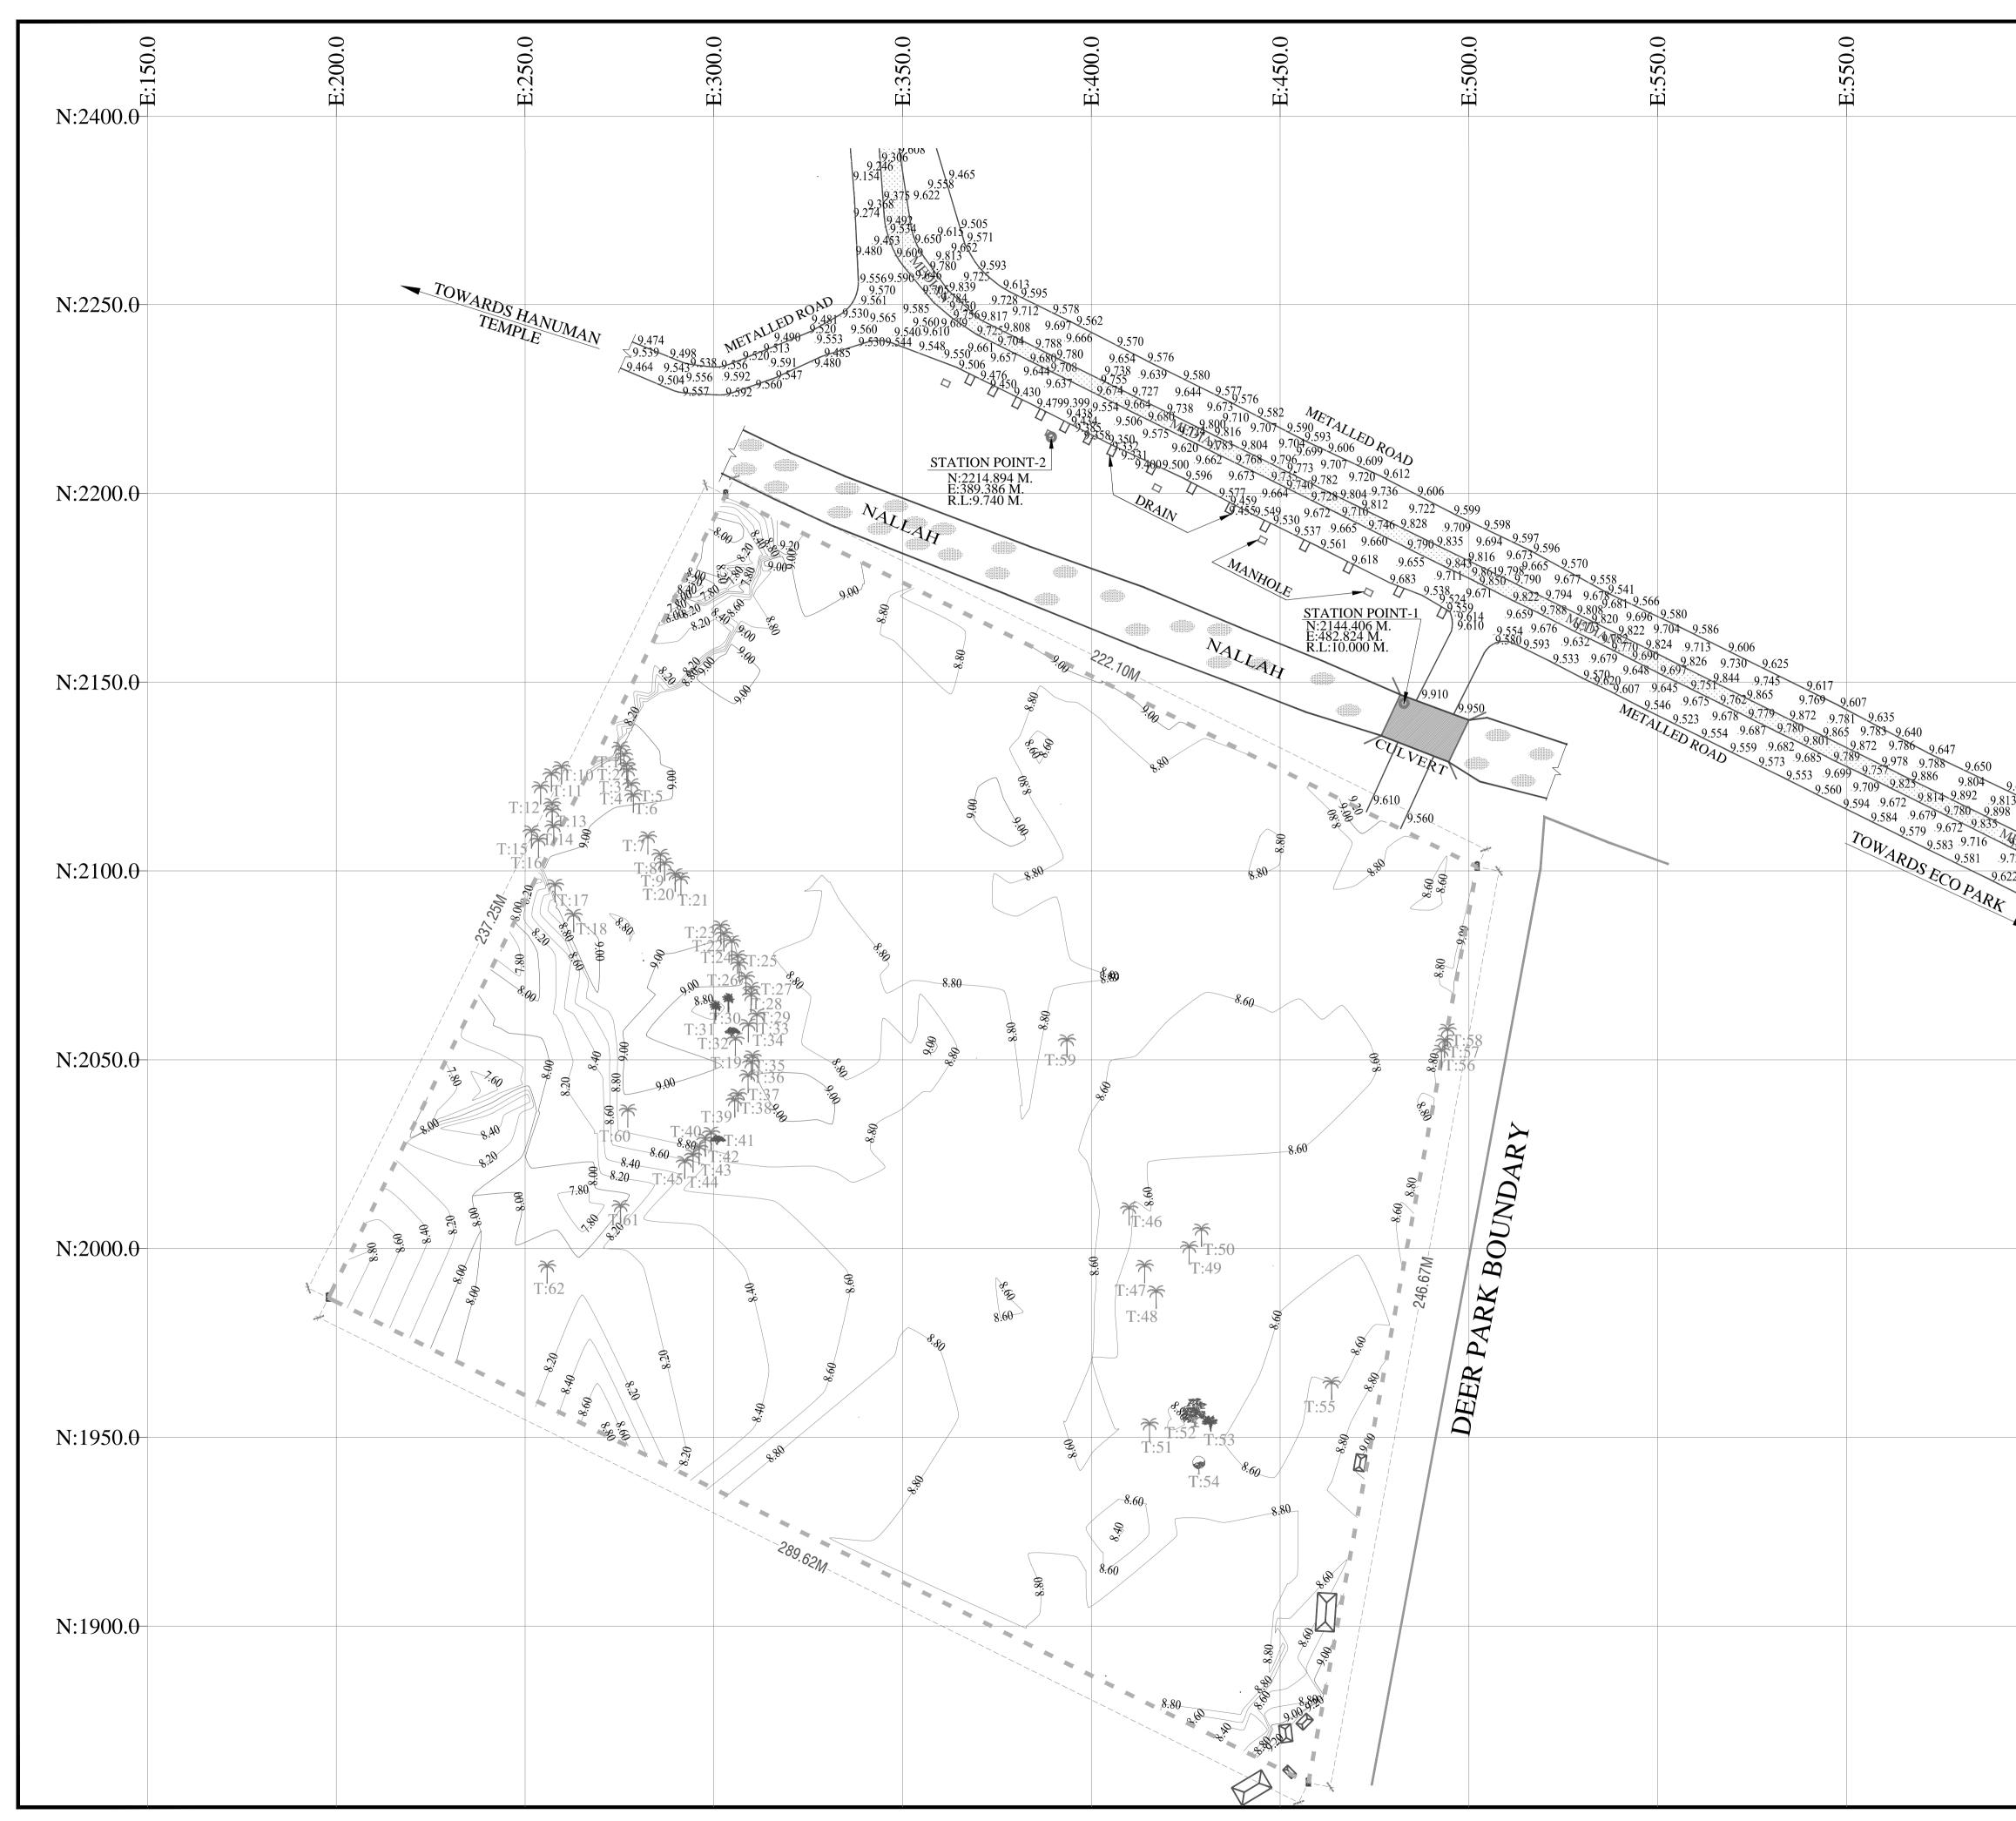

	2		TEND	DER [	DRAWI	NG
		GENE		FS		
ע י ני		1. ALL DIM	IENSIONS ARE IN		TERS AND LEVELS	ARE IN METER
		2. ALL DIN		O BE CHEC	KED AND CO-REL/ RAL, STRUCTURA	
		SERVICE	S DRAWINGS A	ND ANY AN	ABIGUITY, DISCRE	PANCY
		PRIOR T 3. DO NOT	O COMMENCEN SCALE THE DRA	VENT OF EX		
			AWING TO BE R			
		RELEVA	NT SERVICES AN	ID STRUCTI	JRAL DRAWINGS.	
		REVIS	IONS			
		REV	DI	ESCRIPT	ION	DATE
		KEY P	LAN			
)						
9.652						
0.012	9.697					
.070 9	820 9.743 43 9.816 9.768	1				
METOP	$\begin{array}{c} 820 & 9.743 \\ 43 & 9.816 & 9.768 \\ \hline 9.877 & 9.810 \\ \hline 9.810 & 9.805 \\ \hline \end{array}$					
.9.721	9.805 - 9.708 9.773	1				
	9.708 \2.775					
<u>9.6</u> RK	9.581					
		CLIEN	Т			
		INDIA	ブ All II	NDIA F	OOTBALL F	EDERATION
			Football	House, See New Delhi	ctor 19, Phase 1,	
			)// Tel- 91-1	11-253082	00/ 201	
		V		11-253082 iff@the-aif	34/ 25308236 f.com	
		ARCH				
		colla	ige 🏉		300, Sai Sam	DESIGN PVT. LTD Ipanna, Station Rd
		des	ign 🌑		Vikhroli East,	Mumbai 400 083 0842 / 43 / 44 / 45
		ARCHITEC	TURE   INTERIOR	IS   PMC	www.collagec	
		JIKU	CTURAL C			
					anghvi and nsultants Pv	
				7th	)NSUITANTS P\ 1 Floor, Padmavat	
			SACP	Sh	raddhanand Road	
				Mu	ımbai - 400057.   - +91 22 2614 4	4832, Fax - +91
					2617 1804	
		PROJE	СТ			
		ΝΛΤΙΟ			EXCELLEN	С.Е
					AHAT, KOL	
				, 117JUN		
		DRAW	ING TITL	.E		
		SURV	EY PLAN			
		DWG.	NO.			REV. NO.
		TD.A.				
		т <i>D</i> .А.	0.01			RO
		PROJE	CT NO.	18-P	245	
		SCALE		1		NORTH
		1 <sup>ST</sup>  SSI	IED ON			
		1 <sup>s™</sup> ISSU APPRC				
		APPRC	DVED			
			OVED CED BY			

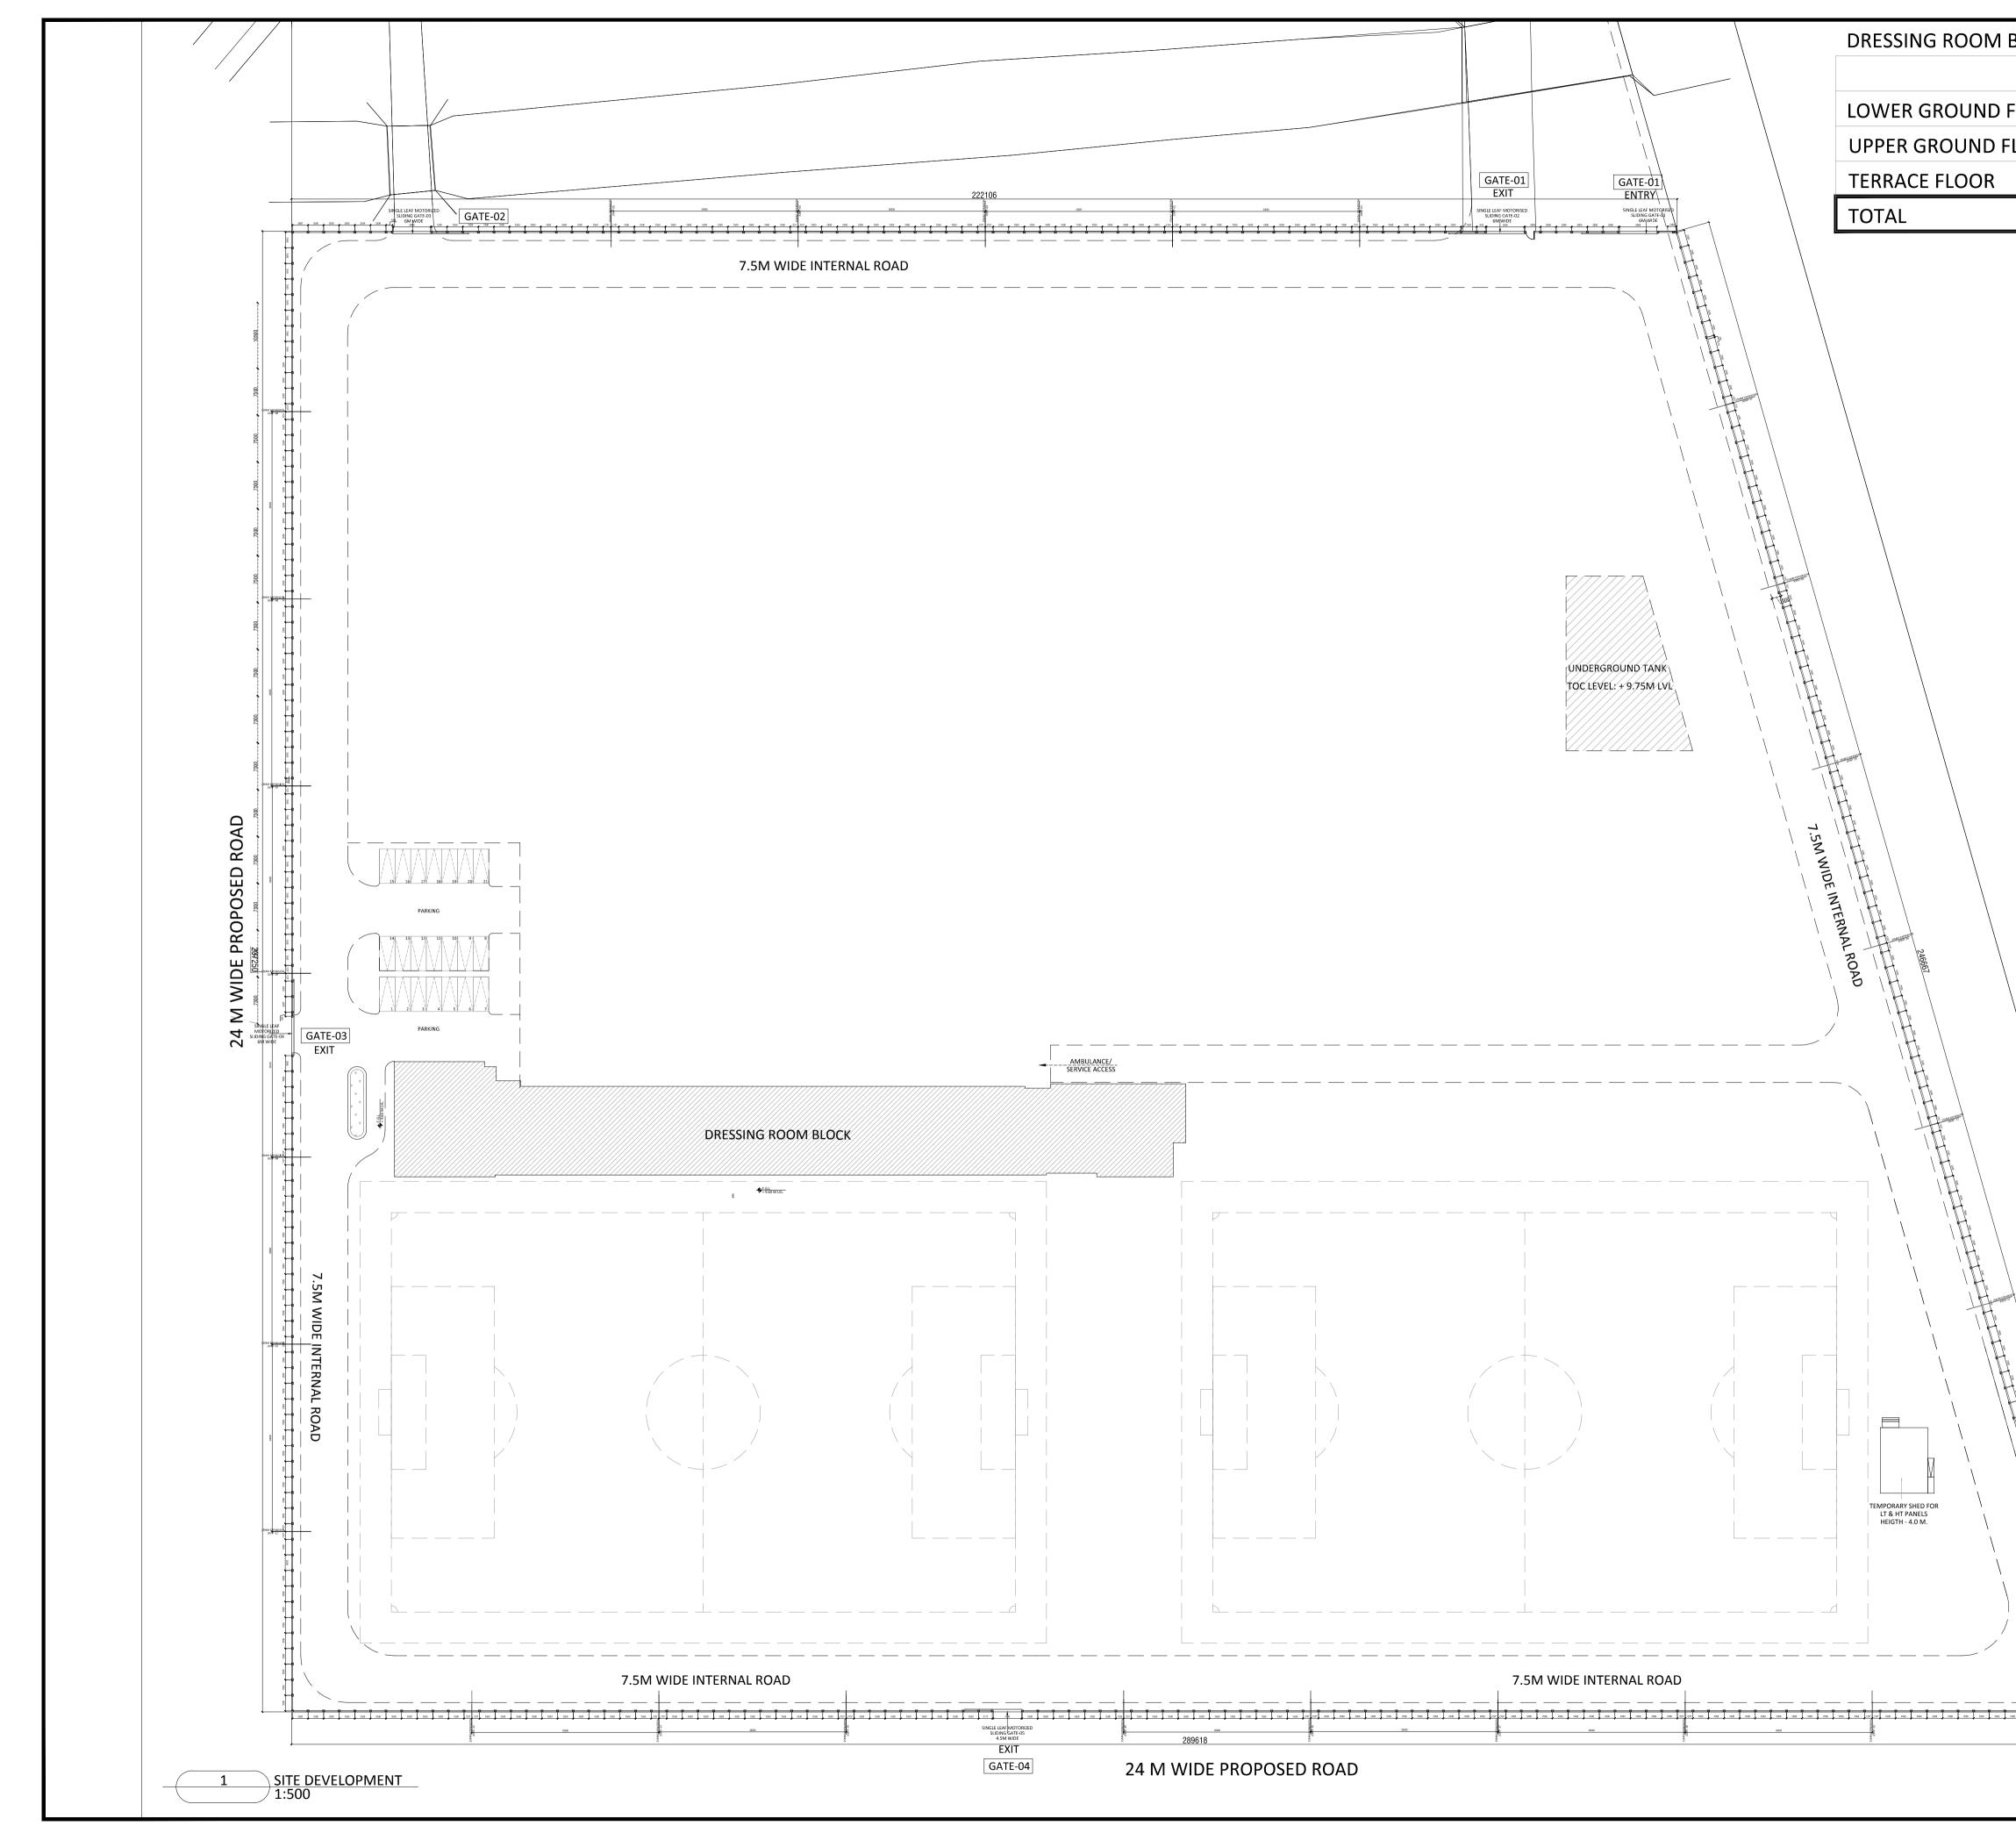

BLOCK		TENDE	<b>R DRAWI</b>	NG
	B.U.A (SQ.M)	GENERAL NOTES		
LOOR	1800	1. ALL DIMENSIONS ARE IN MI UNLESS OTHERWISE SPECIFI 2. ALL DIMENSIONS ARE TO BE	IED. E CHECKED AND CO-REL	ATED
OOR	1260	WITH THE RELEVANT ARCHI SERVICES DRAWINGS AND A OR OMISSION SHALL BE BRC PRIOR TO COMMENCEMENT	ANY AMBIGUITY, DISCRI DUGHT IN TO NOTICE O	EPANCY
	140	<ol> <li>DO NOT SCALE THE DRAWIN FOLLOWED.</li> <li>THIS DRAWING TO BE READ</li> </ol>	NG, WRITTEN DIMENSIO	
	3200	RELEVANT SERVICES AND ST	FRUCTURAL DRAWINGS	
		REVISIONS		
		REV DESC	CRIPTION	DATE
		KEY PLAN		
		STREET NO. 706		
		STREE	4304 Welle Rolfo (RACK) 5704/ET 300, 702 /TER II	PLOT NO
		PLOT NO. IIE/57/3		Opine Own
		60702	UM-SITE 77 SO.M A¢RE ◀	DEER PARK
		<sup></sup>	Annual and a standard and a standard a sta	
DEERP		CLIENT		
DEER PARK PL			IA FOOTBALL F	
DEER PARK PLOT BC		ALL IND Football Hous Dwarka, New Tel- 91-11-25	se, Sector 19, Phase 1, / Delhi: 110075 5308200/ 201	
DEER PARK PLOT BOUNDS		ALL IND Football Hous Dwarka, New Tel- 91-11-25 Fax- 91-11-2 Email- aiff@t	se, Sector 19, Phase 1, / Delhi: 110075 5308200/ 201 /5308234/ 25308236	
DEER PARK PLOT BOUNDARY		ALL IND Football Hous Dwarka, New Tel- 91-11-25 Fax- 91-11-2 Email- aiff@1	se, Sector 19, Phase 1, / Delhi: 110075 5308200/ 201 /5308234/ 25308236 the-aiff.com	
DEER PARK PLOT BOUNDARY		ALL IND Football Hous Dwarka, New Tel- 91-11-25 Fax- 91-11-2 Email- aiff@t	se, Sector 19, Phase 1, v Delhi: 110075 5308200/ 201 5308234/ 25308236 the-aiff.com COLLAGE 300, Sai Sar Vikhroli East	,
DEER PARK PLOT BOUNDARY		ALL IND Football Hous Dwarka, New Tel- 91-11-29 Fax- 91-11	se, Sector 19, Phase 1, v Delhi: 110075 5308200/ 201 5308234/ 25308236 the-aiff.com COLLAGE 300, Sai Sar Vikhroli East +91 22 2574 www.collage	<b>DESIGN PVT. LTD</b> mpanna, Station Rd t, Mumbai 400 083 0842 / 43 / 44 / 45
DEER PARK PLOT BOUNDARY		ALL IND Football Hous Dwarka, New Tel- 91-11-28 Fax- 91-11-2 Email- aiff@1 ARCHITECT	se, Sector 19, Phase 1, v Delhi: 110075 5308200/ 201 5308234/ 25308236 the-aiff.com COLLAGE 300, Sai Sar Vikhroli East +91 22 2574 www.collage NSULTANT	DESIGN PVT. LTD npanna, Station Rd t, Mumbai 400 083 0842 / 43 / 44 / 45 design.net
DEER PARK PLOT BOUNDARY		ALL IND Football Hous Dwarka, New Tel- 91-11-29 Fax- 91-11	se, Sector 19, Phase 1, v Delhi: 110075 5308200/ 201 5308234/ 25308236 the-aiff.com COLLAGE 300, Sai Sar Vikhroli East +91 22 2574 www.collage NSULTANT Shanghvi and Consultants P 7th Elece Dedmone	DESIGN PVT. LTD mpanna, Station Rd t, Mumbai 400 083 0842 / 43 / 44 / 45 design.net Associates vt.Ltd.
DEER PARK PLOT BOUNDARY		ALL IND Football Hous Dwarka, New Tel- 91-11-29 Fax- 91-11	se, Sector 19, Phase 1, v Delhi: 110075 5308200/ 201 5308234/ 25308236 the-aiff.com COLLAGE 300, Sai Sar Vikhroli East +91 22 2574 www.collage NSULTANT Shanghvi and Consultants P 7th Floor, Padmava Shraddhanand Roa Mumbai - 400057.	DESIGN PVT. LTD mpanna, Station Rd t, Mumbai 400 083 0842 / 43 / 44 / 45 design.net Associates vt.Ltd. nti Heights, d,Vile Parle (E),
DEER PARK PLOT BOUNDARY		ALL IND Football Hous Dwarka, New Tel- 91-11-28 Fax- 91-11-28 Email- aiff@r ARCHITECT COLOSECCON ARCHITECTURE   INTERIORS   PI STRUCTURAL COI	se, Sector 19, Phase 1, v Delhi: 110075 5308200/ 201 5308234/ 25308236 the-aiff.com COLLAGE 300, Sai Sar Vikhroli East +91 22 2574 www.collage NSULTANT Shanghvi and Consultants P 7th Floor, Padmava Shraddhanand Roa	DESIGN PVT. LTD mpanna, Station Rd t, Mumbai 400 083 0842 / 43 / 44 / 45 design.net Associates vt.Ltd. nti Heights, d,Vile Parle (E),
DEER PARK PLOT BOUNDARY		ALL IND Football Hous Dwarka, New Tel- 91-11-25 Fax- 91-11-2 Email- aiff@1 ARCHITECT COLOSION ARCHITECTURE INTERIORS IPI STRUCTURAL COI STRUCTURAL COI PROJECT	se, Sector 19, Phase 1, / Delhi: 110075 5308230/ 201 5308234/ 25308236 the-aiff.com COLLAGE 300, Sai Sar Vikhroli East +91 22 2574 www.collage NSULTANT Shanghvi and Consultants P 7th Floor, Padmava Shraddhanand Roa Mumbai - 400057. Tel - +91 22 2614 22 2617 1804	DESIGN PVT. LTD mpanna, Station Rd t, Mumbai 400 083 0842 / 43 / 44 / 45 design.net Associates vt.Ltd. ti Heights, d,Vile Parle (E), 4832, Fax - +91
DEER PARK PLOT BOUNDARY		ALL IND Football Hous Dwarka, New Tel- 91-11-28 Fax- 91-11-28 Email- aiff@r ARCHITECT COLOSECCON ARCHITECTURE   INTERIORS   PI STRUCTURAL COI	se, Sector 19, Phase 1, v Delhi: 110075 5308230/ 201 5308234/ 25308236 the-aiff.com COLLAGE 300, Sai Sar Vikhroli East +91 22 2574 www.collage NSULTANT Shanghvi and Consultants P 7th Floor, Padmava Shraddhanand Roa Mumbai - 400057. Tel - +91 22 2614 22 2617 1804 COF EXCELLEN	DESIGN PVT. LTD mpanna, Station Rd t, Mumbai 400 083 0842 / 43 / 44 / 45 design.net Associates vt.Ltd. ti Heights, d,Vile Parle (E), 4832, Fax - +91
DEER PARK PLOT BOUNDARY		ALL IND Football Hous Dwarka, New Tel- 91-11-25 Fax- 91-11-2 Email- aiff@r ARCHITECT COSSECCE ARCHITECTURE INTERIORS   PI STRUCTURAL COI STRUCTURAL COI STRUCTURAL COI PROJECT NATIONAL CENTRE IN FOOTBALL @ R. DRAWING TITLE	se, Sector 19, Phase 1, v Delhi: 110075 5308200/ 201 5308234/ 25308236 the-aiff.com COLLAGE 300, Sai Sar Vikhroli East +91 22 2574 www.collage NSULTANT Shanghvi and Consultants P 7th Floor, Padmava Shraddhanand Roa Mumbai - 400057. Tel - +91 22 2614 22 2617 1804 COF EXCELLEN AJRAHAT, KOI	DESIGN PVT. LTD mpanna, Station Rd t, Mumbai 400 083 0842 / 43 / 44 / 45 design.net Associates vt.Ltd. ti Heights, d,Vile Parle (E), 4832, Fax - +91
DEER PARK PLOT BOUNDARY		ALL IND Football Hous Dwarka, New Tel- 91-11-2E Fax- 91-11-2 Email- aiff@r ARCHITECT COSSECT ARCHITECTURE   INTERIORS   PI STRUCTURAL COI STRUCTURAL COI PROJECT NATIONAL CENTRE IN FOOTBALL @ R.	se, Sector 19, Phase 1, v Delhi: 110075 5308200/ 201 5308234/ 25308236 the-aiff.com COLLAGE 300, Sai Sar Vikhroli East +91 22 2574 www.collage NSULTANT Shanghvi and Consultants P 7th Floor, Padmava Shraddhanand Roa Mumbai - 400057. Tel - +91 22 2614 22 2617 1804 COF EXCELLEN AJRAHAT, KOI	DESIGN PVT. LTD mpanna, Station Rd t, Mumbai 400 083 0842 / 43 / 44 / 45 design.net Associates vt.Ltd. ti Heights, d,Vile Parle (E), 4832, Fax - +91
DEER PARK PLOT BOUNDARY		ALL IND Football Hous Dwarka, New Tel- 91-11-25 Fax- 91-11-2 Email- aiff@1 ARCHITECT COSCOCOCOCOCOCOCOCOCOCOCOCOCOCOCOCOCOCO	se, Sector 19, Phase 1, v Delhi: 110075 5308200/ 201 5308234/ 25308236 the-aiff.com COLLAGE 300, Sai Sar Vikhroli East +91 22 2574 www.collage NSULTANT Shanghvi and Consultants P 7th Floor, Padmava Shraddhanand Roa Mumbai - 400057. Tel - +91 22 2614 22 2617 1804 COF EXCELLEN AJRAHAT, KOI	DESIGN PVT. LTD mpanna, Station Rd t, Mumbai 400 083 0842 / 43 / 44 / 45 design.net Associates vt.Ltd. ti Heights, d,Vile Parle (E), 4832, Fax - +91 JCE _KATA
DEER PARK PLOT BOUNDARY		ALL IND Football Hous Dwarka, New Tel- 91-11-25 Fax- 91-11-2 Email- aiff@1 ARCHITECT COSCOCOCOCOCOCOCOCOCOCOCOCOCOCOCOCOCOCO	se, Sector 19, Phase 1, v Delhi: 110075 5308200/ 201 5308234/ 25308236 the-aiff.com COLLAGE 300, Sai Sar Vikhroli East +91 22 2574 www.collage NSULTANT Shanghvi and Consultants P 7th Floor, Padmava Shraddhanand Roa Mumbai - 400057. Tel - +91 22 2614 22 2617 1804 COF EXCELLEN AJRAHAT, KOI	DESIGN PVT. LTD mpanna, Station Rd t, Mumbai 400 083 0842 / 43 / 44 / 45 design.net Associates vt.Ltd. ti Heights, d,Vile Parle (E), 4832, Fax - +91 JCE _KATA REV. NO.
DEER PARK PLOT BOUNDARY		ALL IND Football Hous Dwarka, New Tel- 91-11-25 Fax- 91-11-2 Email- aiff@r ARCHITECT CCCCCCCCCCCCCCCCCCCCCCCCCCCCCCCCCC	se, Sector 19, Phase 1, / Delhi: 110075 5308230/ 201 5308234/ 25308236 the-aiff.com COLLAGE 300, Sai Sar Vikhroli East +91 22 2574 www.collage NSULTANT Shanghvi and Consultants P 7th Floor, Padmava Shraddhanand Roa Mumbai - 400057. Tel - +91 22 2614 22 2617 1804 COF EXCELLEN AJRAHAT, KOI	DESIGN PVT. LTD mpanna, Station Rd t, Mumbai 400 083 0842 / 43 / 44 / 45 design.net Associates vt.Ltd. ti Heights, d,Vile Parle (E), 4832, Fax - +91 JCE _KATA
		ALL IND Football Hous Dwarka, New Tel- 91-11-25 Fax- 91-11-2 Email- aiff@/ ARCHITECT CCCCCCCCCCCCCCCCCCCCCCCCCCCCCCCCCC	se, Sector 19, Phase 1, v Delhi: 110075 5308200/ 201 5308234/ 25308236 the-aiff.com COLLAGE 300, Sai Sar Vikhroli East +91 22 2574 www.collage NSULTANT Shanghvi and Consultants P 7th Floor, Padmava Shraddhanand Roa Mumbai - 400057. Tel - +91 22 2614 22 2617 1804 COF EXCELLEN AJRAHAT, KOI	DESIGN PVT. LTD mpanna, Station Rd t, Mumbai 400 083 0842 / 43 / 44 / 45 design.net Associates vt.Ltd. ti Heights, d,Vile Parle (E), 4832, Fax - +91 JCE _KATA REV. NO.
SINGLE LEAF MOTORIZED SLOBA WHOE		ALL IND Football Hous Dwarka, New Tel- 91-11-25 Fax- 91-11-2 Email- aiff@M ARCHITECT CCCCCCCCCCCCCCCCCCCCCCCCCCCCCCCCCC	se, Sector 19, Phase 1, / Delhi: 110075 5308230/ 201 5308234/ 25308236 the-aiff.com COLLAGE 300, Sai Sar Vikhroli East +91 22 2574 www.collage NSULTANT Shanghvi and Consultants P 7th Floor, Padmava Shraddhanand Roa Mumbai - 400057. Tel - +91 22 2614 22 2617 1804 COF EXCELLEN AJRAHAT, KOI COF EXCELLEN AJRAHAT, KOI Saparation State Saparation State	DESIGN PVT. LTD mpanna, Station Rd t, Mumbai 400 083 0842 / 43 / 44 / 45 design.net Associates vt.Ltd. ti Heights, d,Vile Parle (E), 4832, Fax - +91 NCE _KATA REV. NO. REV. NO.
SINGLE LEAF MOTORIZED SUBJECTOR		ALL IND Football Hous Dwarka, New Tel- 91-11-25 Fax- 91-11-2 Email- aiff@r ARCHITECT COSCECCCCCCCCCCCCCCCCCCCCCCCCCCCCCCCCCC	se, Sector 19, Phase 1, / Delhi: 110075 5308230/ 201 5308234/ 25308236 the-aiff.com COLLAGE 300, Sai Sar Vikhroli East +91 22 2574 www.collage NSULTANT Shanghvi and Consultants P 7th Floor, Padmava Shraddhanand Roa Mumbai - 400057. Tel - +91 22 2614 22 2617 1804 COF EXCELLEN AJRAHAT, KOI COF EXCELLEN AJRAHAT, KOI Saparation State Saparation State	DESIGN PVT. LTD mpanna, Station Rd t, Mumbai 400 083 0842 / 43 / 44 / 45 design.net Associates vt.Ltd. ti Heights, d,Vile Parle (E), 4832, Fax - +91 NCE _KATA REV. NO. REV. NO.

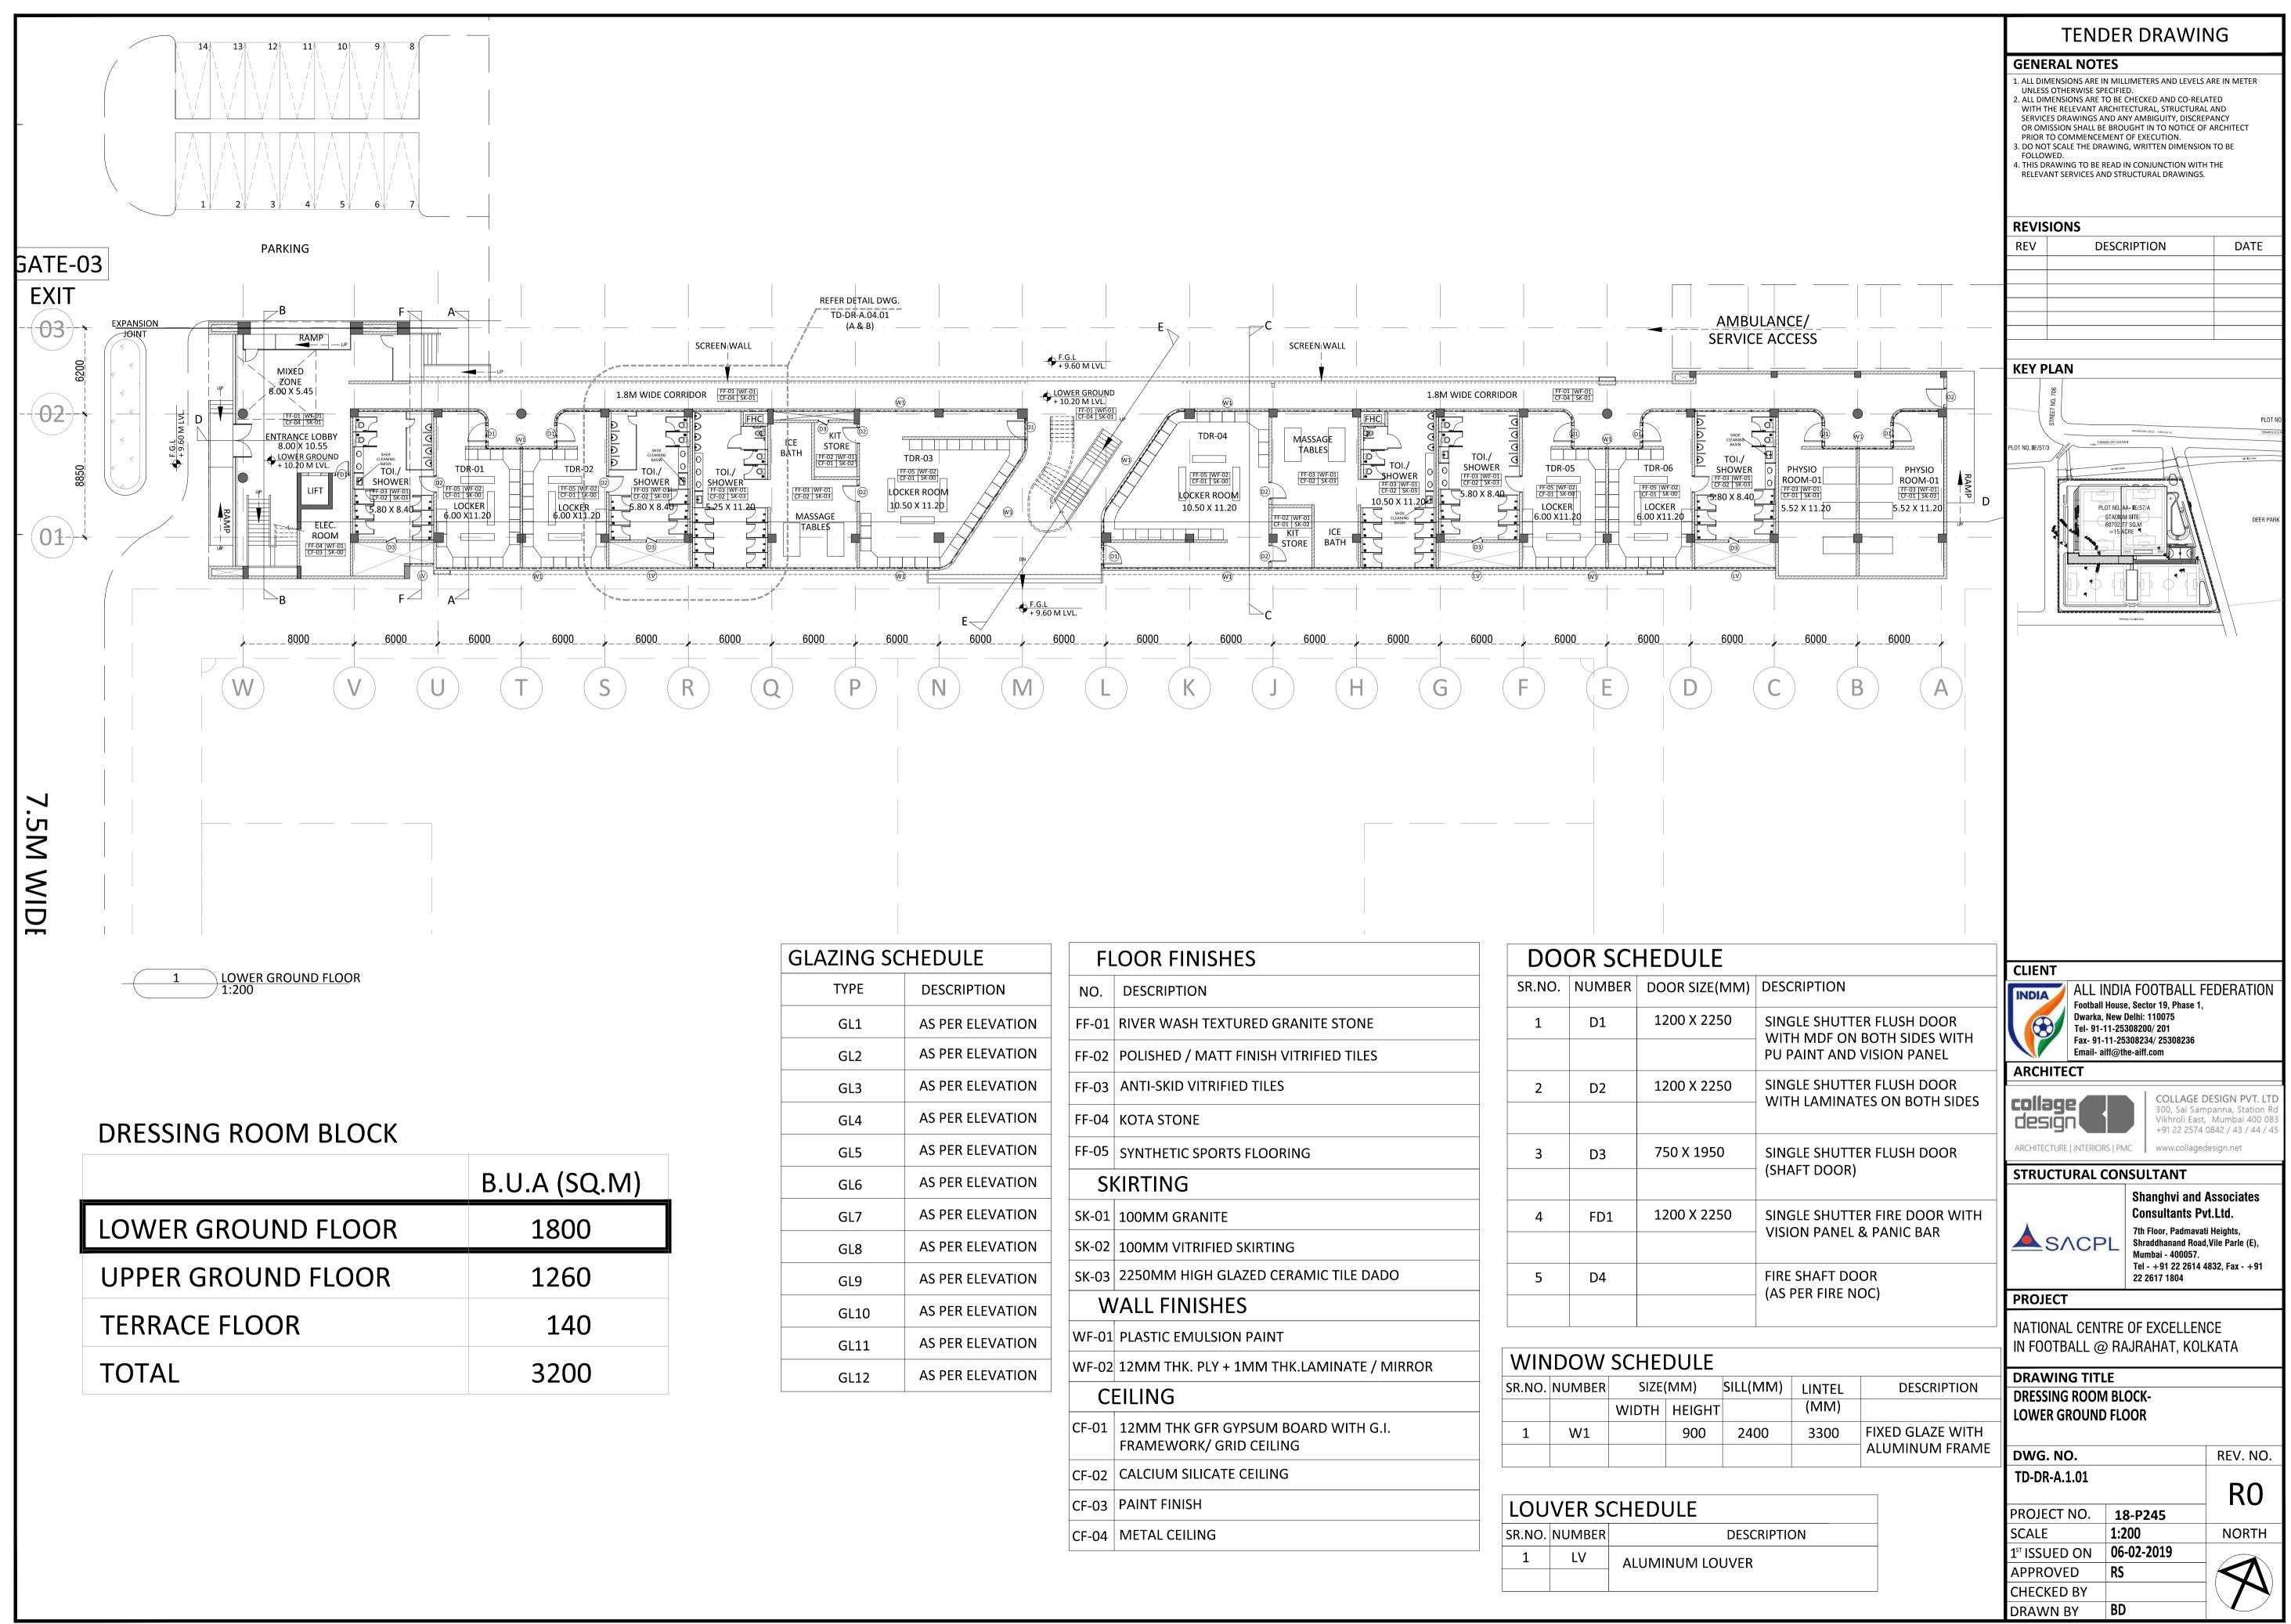

ZING SCHEDULE					
ТҮРЕ	DESCRIPTION				
GL1	AS PER ELEVATION				
GL2	AS PER ELEVATION				
GL3	AS PER ELEVATION				
GL4	AS PER ELEVATION				
GL5	AS PER ELEVATION				
GL6	AS PER ELEVATION				
GL7	AS PER ELEVATION				
GL8	AS PER ELEVATION				
GL9	AS PER ELEVATION				
GL10	AS PER ELEVATION				
GL11	AS PER ELEVATION				
GI 12	AS PER ELEVATION				


FL	OOR FINISHES
NO.	DESCRIPTION
FF-01	RIVER WASH TEXTURED GRANITE STONE
FF-02	POLISHED / MATT FINISH VITRIFIED TILES
FF-03	ANTI-SKID VITRIFIED TILES
FF-04	KOTA STONE
FF-05	SYNTHETIC SPORTS FLOORING
Sł	KIRTING
SK-01	100MM GRANITE
SK-02	100MM VITRIFIED SKIRTING
SK-03	2250MM HIGH GLAZED CERAMIC TILE DADO
W	ALL FINISHES
WF-01	PLASTIC EMULSION PAINT
WF-02	12MM THK. PLY + 1MM THK.LAMINATE / MIRROR
C	EILING
CF-01	12MM THK GFR GYPSUM BOARD WITH G.I. FRAMEWORK/ GRID CEILING
CF-02	CALCIUM SILICATE CEILING
CF-03	PAINT FINISH
CF-04	METAL CEILING

	U	U	R	S	C	Η	F	D	U	L	

SR.NO.	NUMBER	DOOR SIZE(MM)	D
1	D1	1200 X 2250	S V
			P
2	D2	1200 X 2250	S V
			v
3	D3	750 X 1950	S
			(9
4	FD1	1200 X 2250	S V
5	D4		F (/
			(/

WINDOW SCHEDULE						
SR.NO.	NUMBER	SIZE	SIZE(MM)			
		WIDTH	HEIGHT			
1	W1		900	2400		

LOUVER SCHEDULE						
SR.NO.	NUMBER	DESCRIF				
1	LV	ALUMINUM LOUVER				

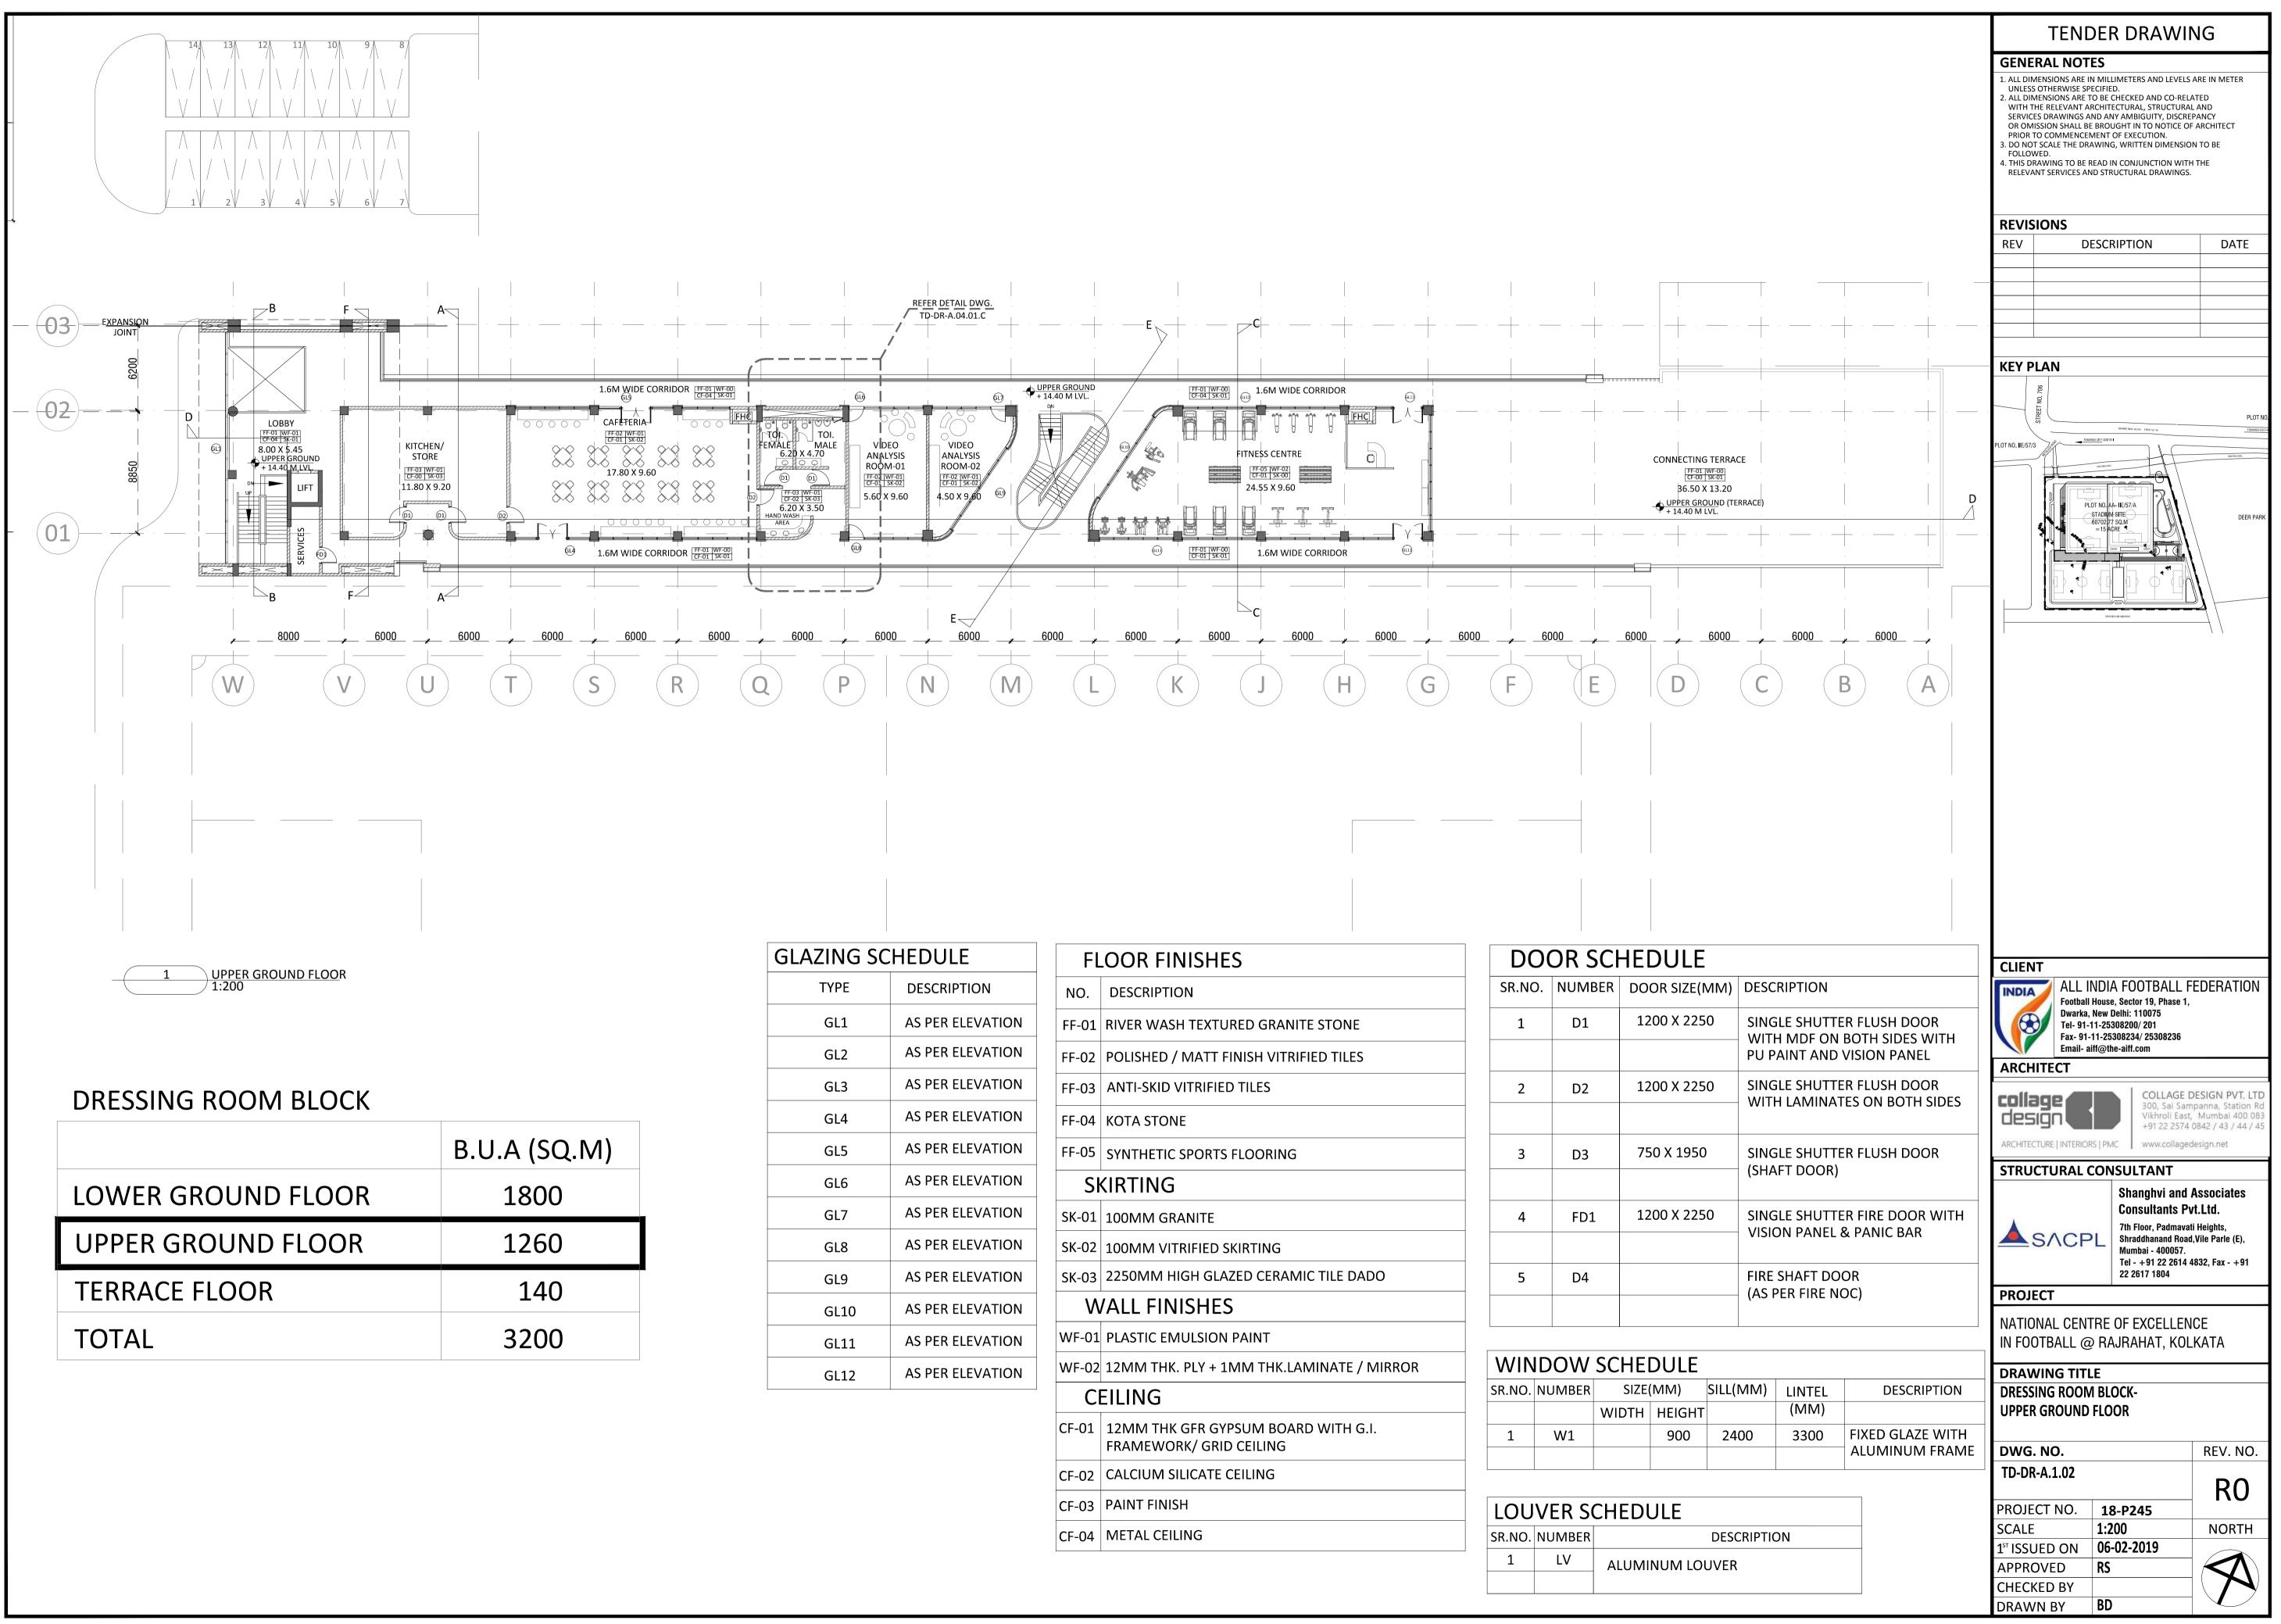

	B.U.A (SQ.M)
LOWER GROUND FLOOR	1800
UPPER GROUND FLOOR	1260
TERRACE FLOOR	140
TOTAL	3200


ZING SCHEDULE					
ТҮРЕ	DESCRIPTION				
GL1	AS PER ELEVATION				
GL2	AS PER ELEVATION				
GL3	AS PER ELEVATION				
GL4	AS PER ELEVATION				
GL5	AS PER ELEVATION				
GL6	AS PER ELEVATION				
GL7	AS PER ELEVATION				
GL8	AS PER ELEVATION				
GL9	AS PER ELEVATION				
GL10	AS PER ELEVATION				
GL11	AS PER ELEVATION				
GL12	AS PER ELEVATION				

FL	OOR FINISHES
NO.	DESCRIPTION
FF-01	RIVER WASH TEXTURED GRANITE STONE
FF-02	POLISHED / MATT FINISH VITRIFIED TILES
FF-03	ANTI-SKID VITRIFIED TILES
FF-04	KOTA STONE
FF-05	SYNTHETIC SPORTS FLOORING
Sł	KIRTING
SK-01	100MM GRANITE
SK-02	100MM VITRIFIED SKIRTING
SK-03	2250MM HIGH GLAZED CERAMIC TILE DADO
W	ALL FINISHES
WF-01	PLASTIC EMULSION PAINT
WF-02	12MM THK. PLY + 1MM THK.LAMINATE / MIRROR
Cl	EILING
CF-01	12MM THK GFR GYPSUM BOARD WITH G.I. FRAMEWORK/ GRID CEILING
CF-02	CALCIUM SILICATE CEILING
CF-03	PAINT FINISH
CF-04	METAL CEILING

DE	DOOR SIZE(MM)	NUMBER	SR.NO.
SII W	1200 X 2250	D1	1
PL			
SII W	1200 X 2250	D2	2
vv			
SI	750 X 1950	D3	3
(SI			
SI	1200 X 2250	FD1	4
VI			
FI		D4	5
(A			
		1	

SR.NO.NUMBERSIZE(MM)SILL(MM)1WIDTHHEIGHT1W19002400	WIN	IDOW	SCHE	DULE	
	SR.NO.	NUMBER	SIZE	(MM)	SILL(MM)
1 W1 900 2400			WIDTH	HEIGHT	
	1	W1		900	2400

LOU	VER S	CHEDULE
SR.NO.	NUMBER	DESCRIP
1	LV	ALUMINUM LOUVER

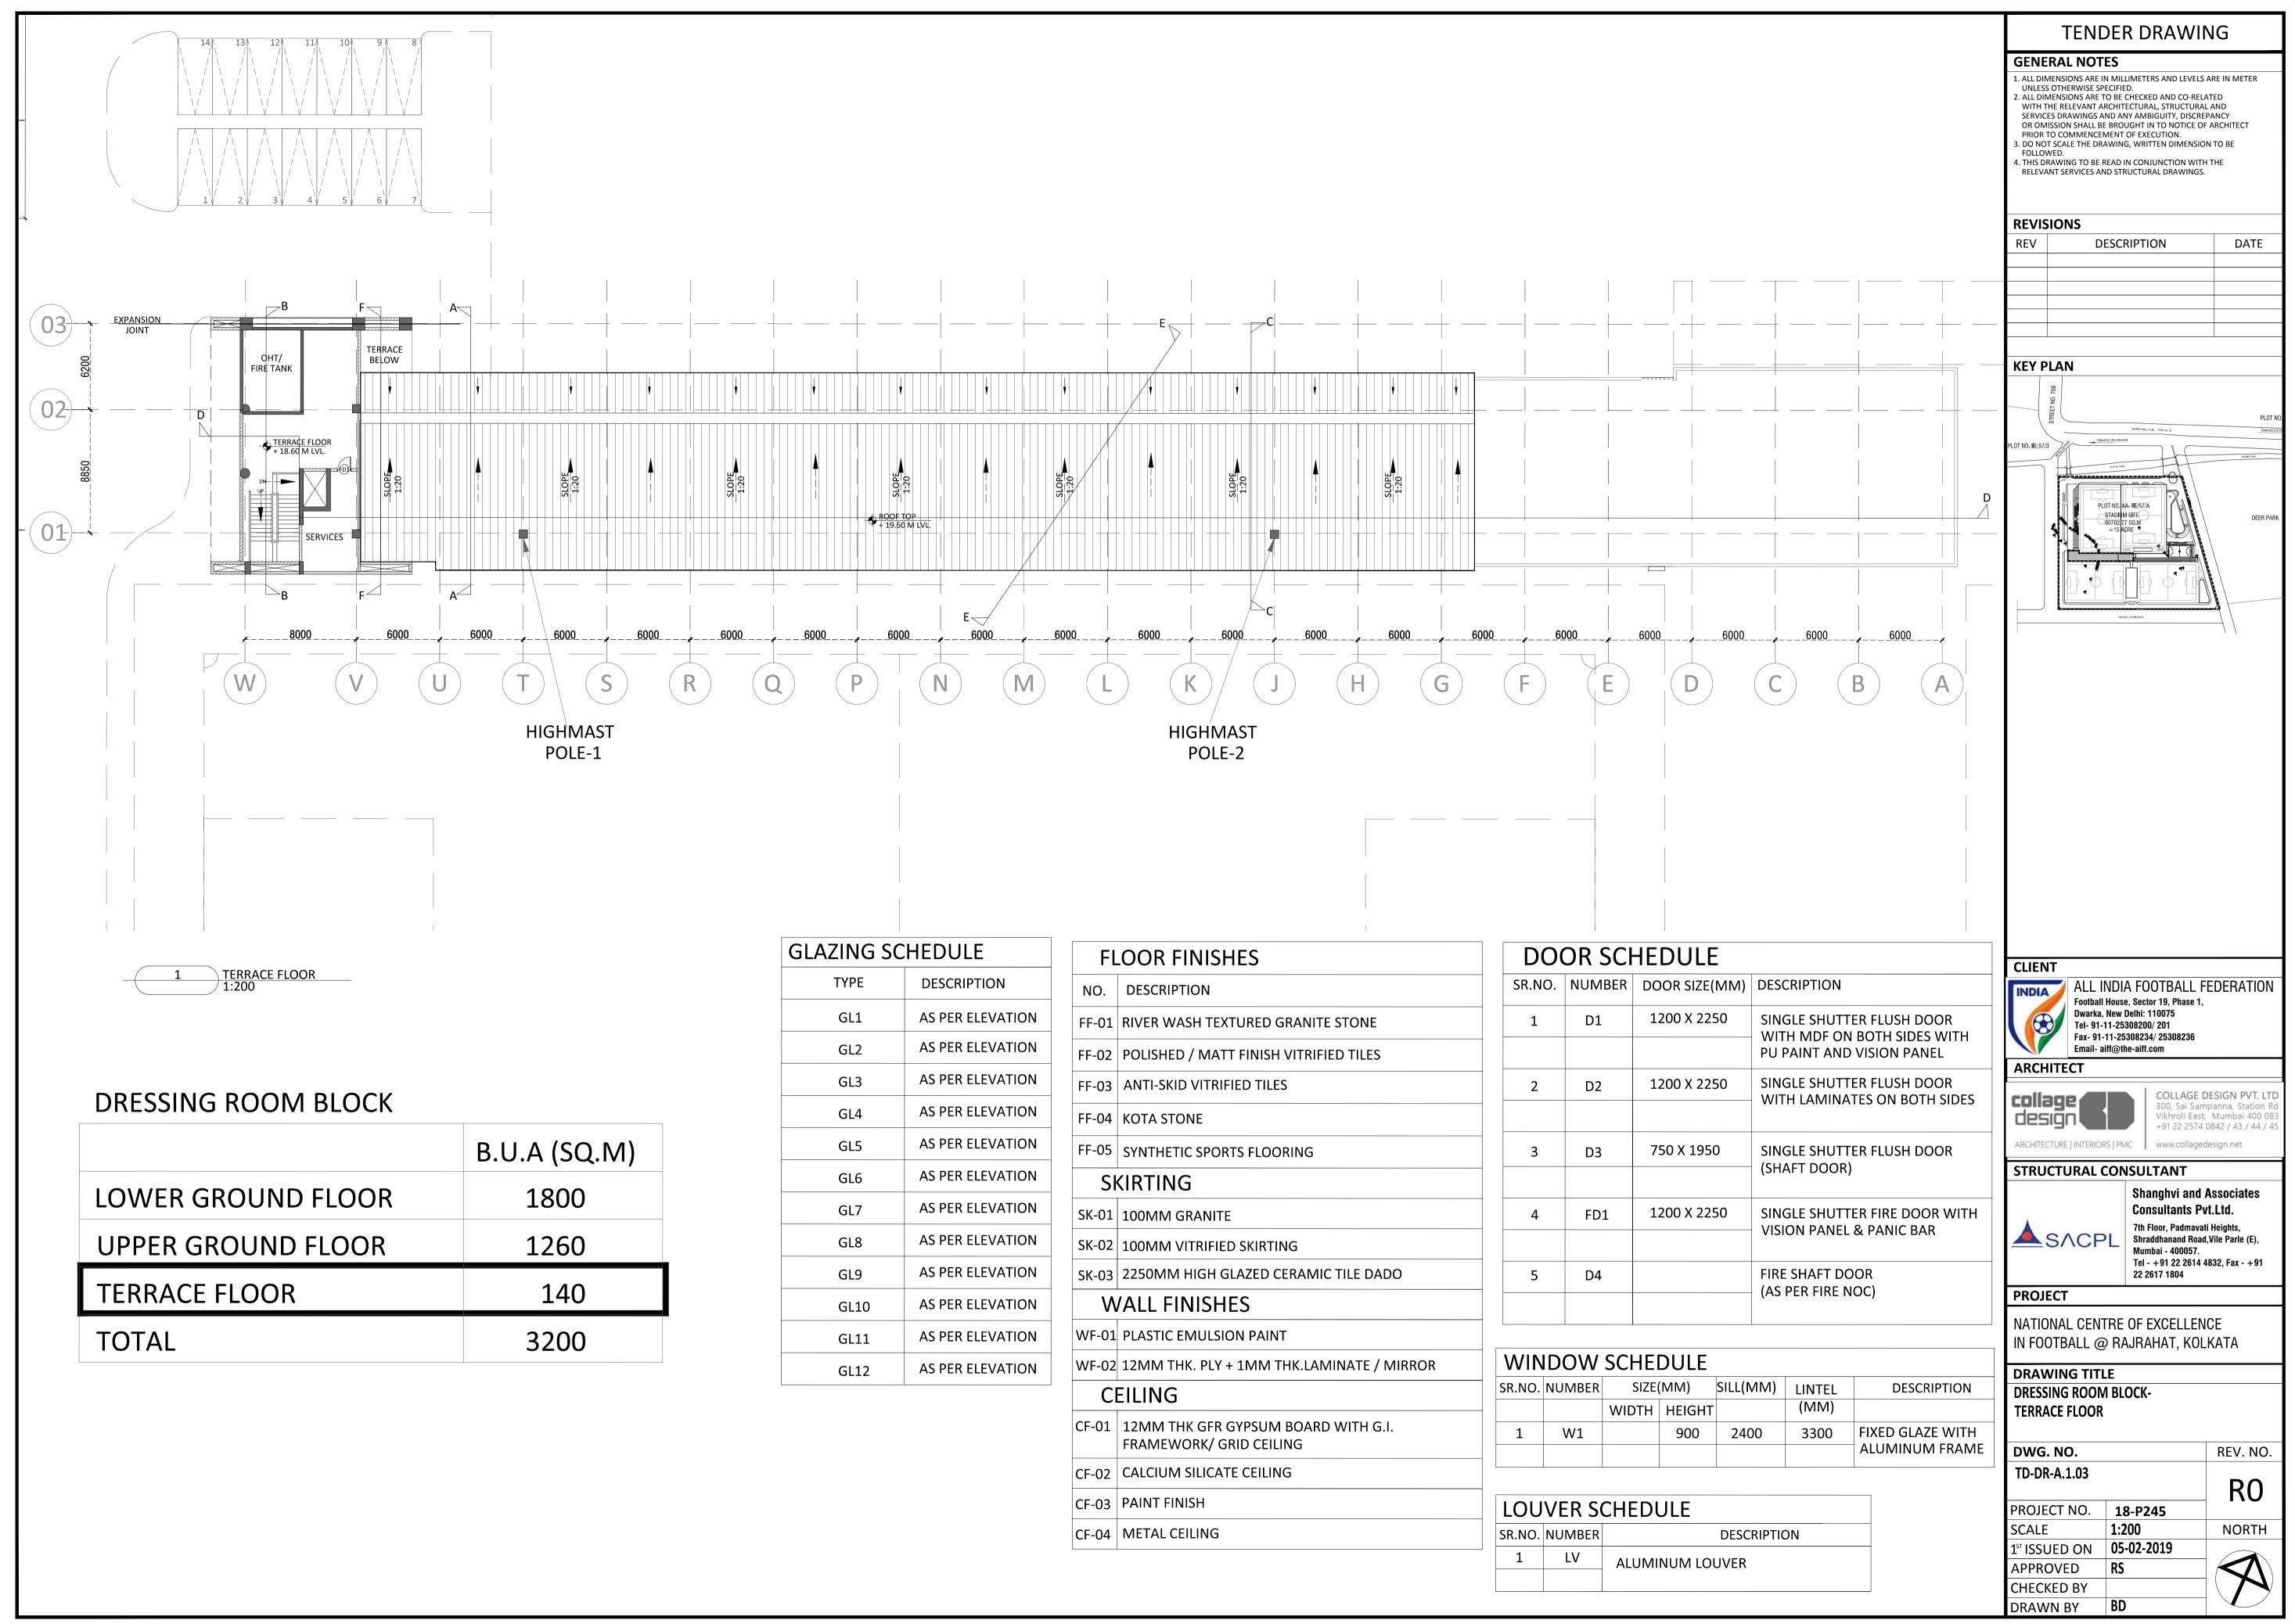


ITPE	DESCRIPTION
GL1	AS PER ELEVATION
GL2	AS PER ELEVATION
GL3	AS PER ELEVATION
GL4	AS PER ELEVATION
GL5	AS PER ELEVATION
GL6	AS PER ELEVATION
GL7	AS PER ELEVATION
GL8	AS PER ELEVATION
GL9	AS PER ELEVATION
GL10	AS PER ELEVATION
GL11	AS PER ELEVATION
GL12	AS PER ELEVATION

FL	OOR FINISHES
NO.	DESCRIPTION
FF-01	RIVER WASH TEXTURED GRANITE STONE
FF-02	POLISHED / MATT FINISH VITRIFIED TILES
FF-03	ANTI-SKID VITRIFIED TILES
FF-04	KOTA STONE
FF-05	SYNTHETIC SPORTS FLOORING
S	KIRTING
SK-01	100MM GRANITE
SK-02	100MM VITRIFIED SKIRTING
SK-03	2250MM HIGH GLAZED CERAMIC TILE DADO
N	ALL FINISHES
WF-01	PLASTIC EMULSION PAINT
WF-02	12MM THK. PLY + 1MM THK.LAMINATE / MIRROR
C	EILING
CF-01	12MM THK GFR GYPSUM BOARD WITH G.I. FRAMEWORK/ GRID CEILING
CF-02	CALCIUM SILICATE CEILING
CF-03	PAINT FINISH
CF-04	METAL CEILING

SR.NO.	NUMBER	DOOR SIZE(MM)	DE
1	D1	1200 X 2250	SII W
			PL
2	D2	1200 X 2250	SII W
			~~~
3	D3	750 X 1950	SII
			(SI
4	FD1	1200 X 2250	SII
			VI
5	D4		FIF (A

WIN	IDOW	SCHE	DULE	
SR.NO.	NUMBER	SIZE	(MM)	SILL(MM)
		WIDTH	HEIGHT	
1	W1		900	2400

LOU	VER S	CHEDULE
SR.NO.	NUMBER	DESCRIPT
1	LV	ALUMINUM LOUVER

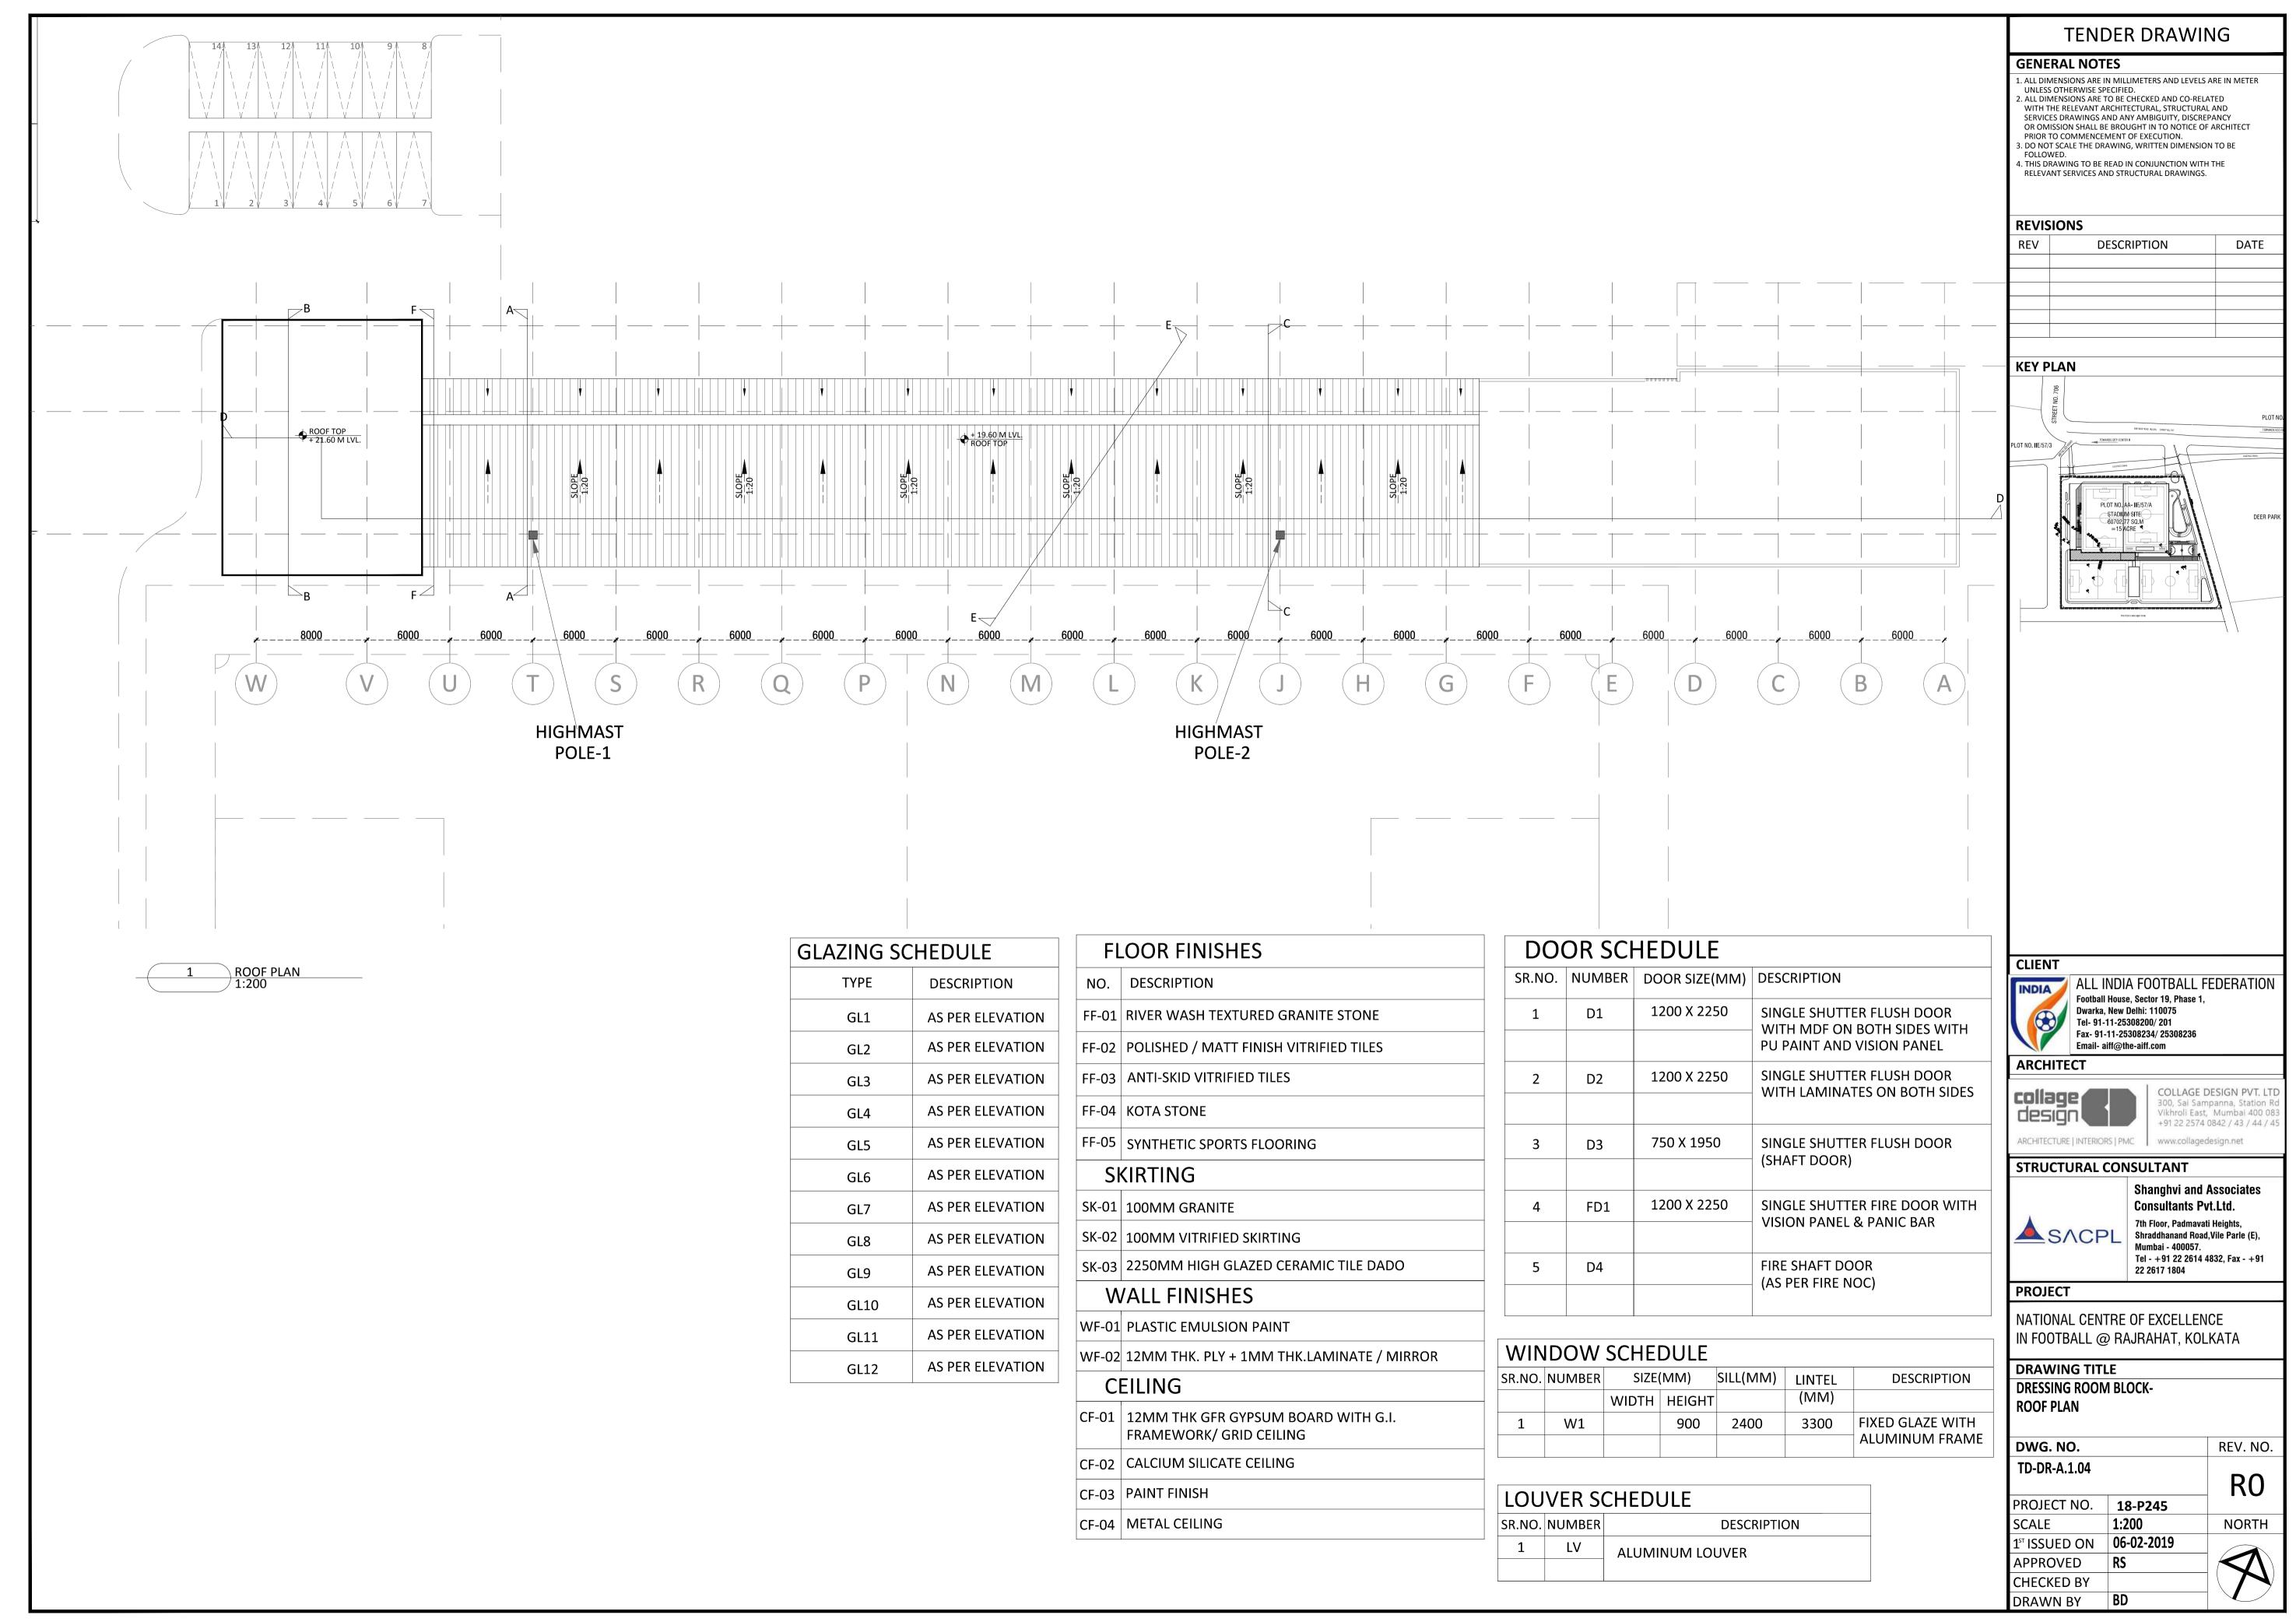


ZING SC	HEDULE
ТҮРЕ	DESCRIPTION
GL1	AS PER ELEVATION
GL2	AS PER ELEVATION
GL3	AS PER ELEVATION
GL4	AS PER ELEVATION
GL5	AS PER ELEVATION
GL6	AS PER ELEVATION
GL7	AS PER ELEVATION
GL8	AS PER ELEVATION
GL9	AS PER ELEVATION
GL10	AS PER ELEVATION
GL11	AS PER ELEVATION
GL12	AS PER ELEVATION

FL	OOR FINISHES
NO.	DESCRIPTION
FF-01	RIVER WASH TEXTURED GRANITE STONE
FF-02	POLISHED / MATT FINISH VITRIFIED TILES
FF-03	ANTI-SKID VITRIFIED TILES
FF-04	KOTA STONE
FF-05	SYNTHETIC SPORTS FLOORING
S	KIRTING
SK-01	100MM GRANITE
SK-02	100MM VITRIFIED SKIRTING
SK-03	2250MM HIGH GLAZED CERAMIC TILE DADO
M	ALL FINISHES
WF-01	PLASTIC EMULSION PAINT
WF-02	12MM THK. PLY + 1MM THK.LAMINATE / MIRROR
C	EILING
CF-01	12MM THK GFR GYPSUM BOARD WITH G.I. FRAMEWORK/ GRID CEILING
CF-02	CALCIUM SILICATE CEILING
CF-03	PAINT FINISH
CF-04	METAL CEILING


	ILDULL		
DES	DOOR SIZE(MM)	NUMBER	SR.NO.
SIN WI	1200 X 2250	D1	1
PU			
SIN WI	1200 X 2250	D2	2
VVI			
SIN	750 X 1950	D3	3
(S⊦			
SIN	1200 X 2250	FD1	4
VIS			
FIR		D4	5
(AS			
		1	


SR.NO.	NUMBER	SIZE	(MM)	SILL(MM)
		WIDTH	HEIGHT	
1	W1		900	2400


LOU	VER S	CHEDULE
SR.NO.	NUMBER	DESCRIP
1	LV	ALUMINUM LOUVER

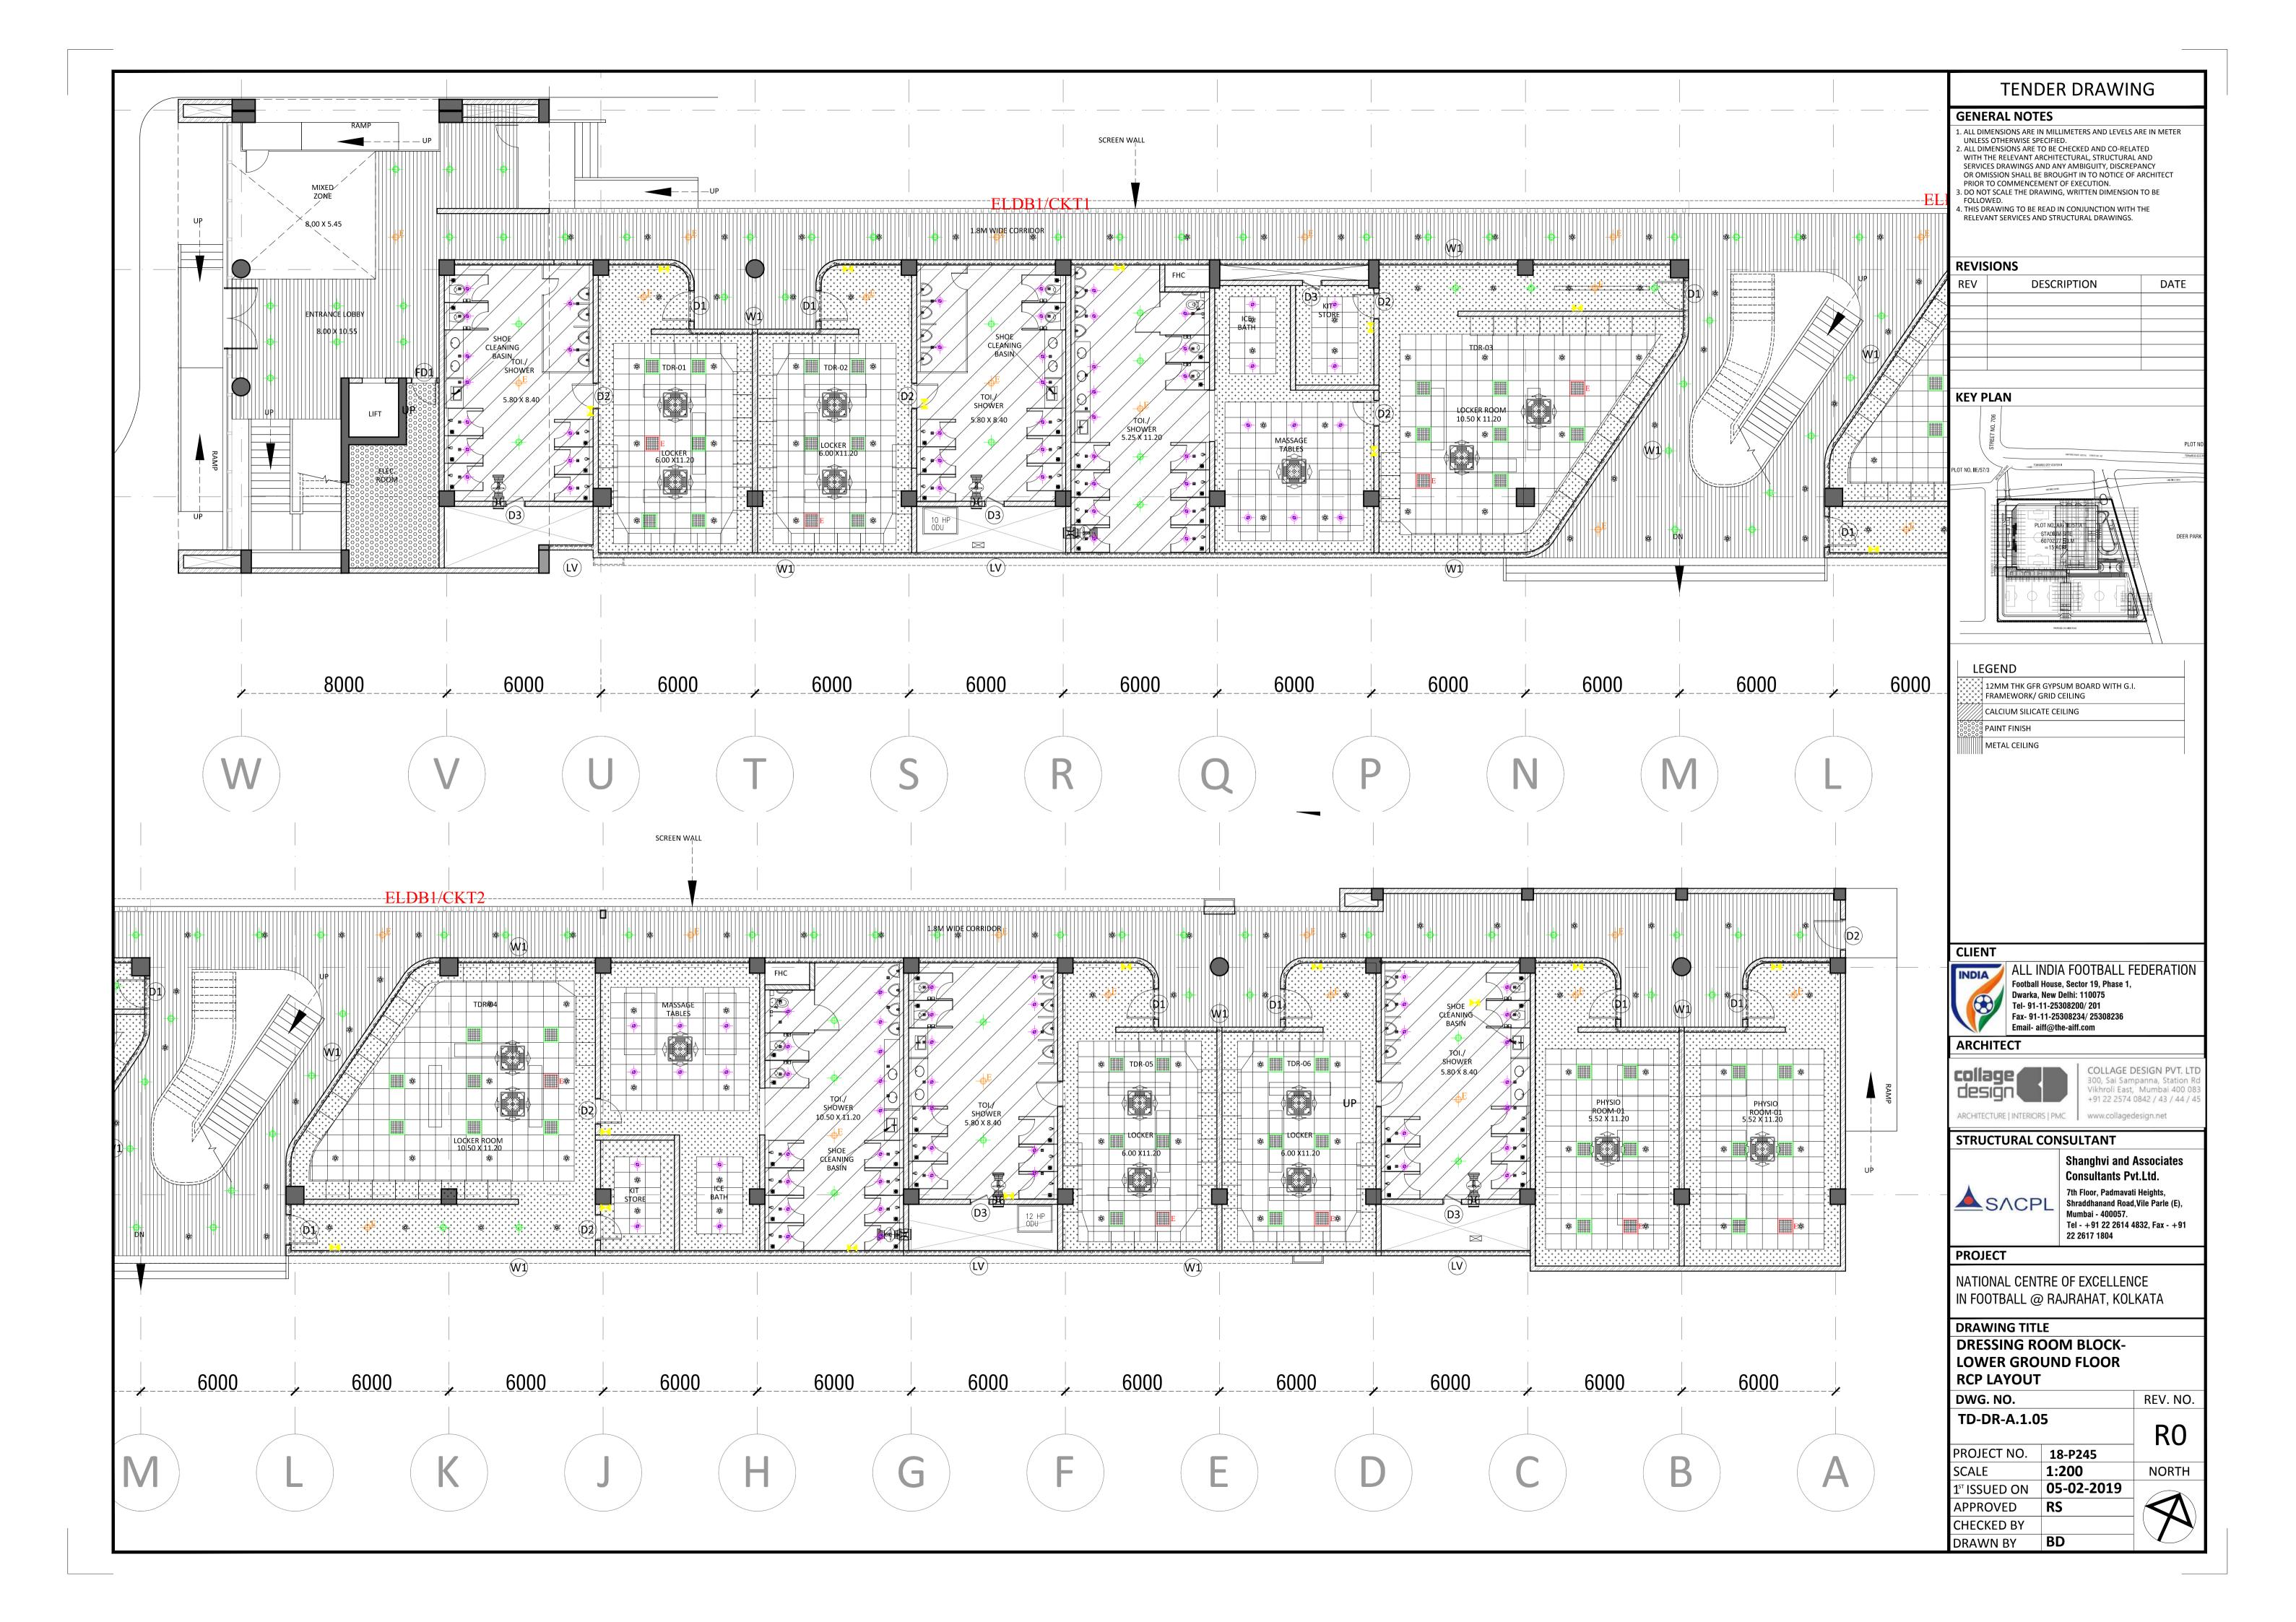




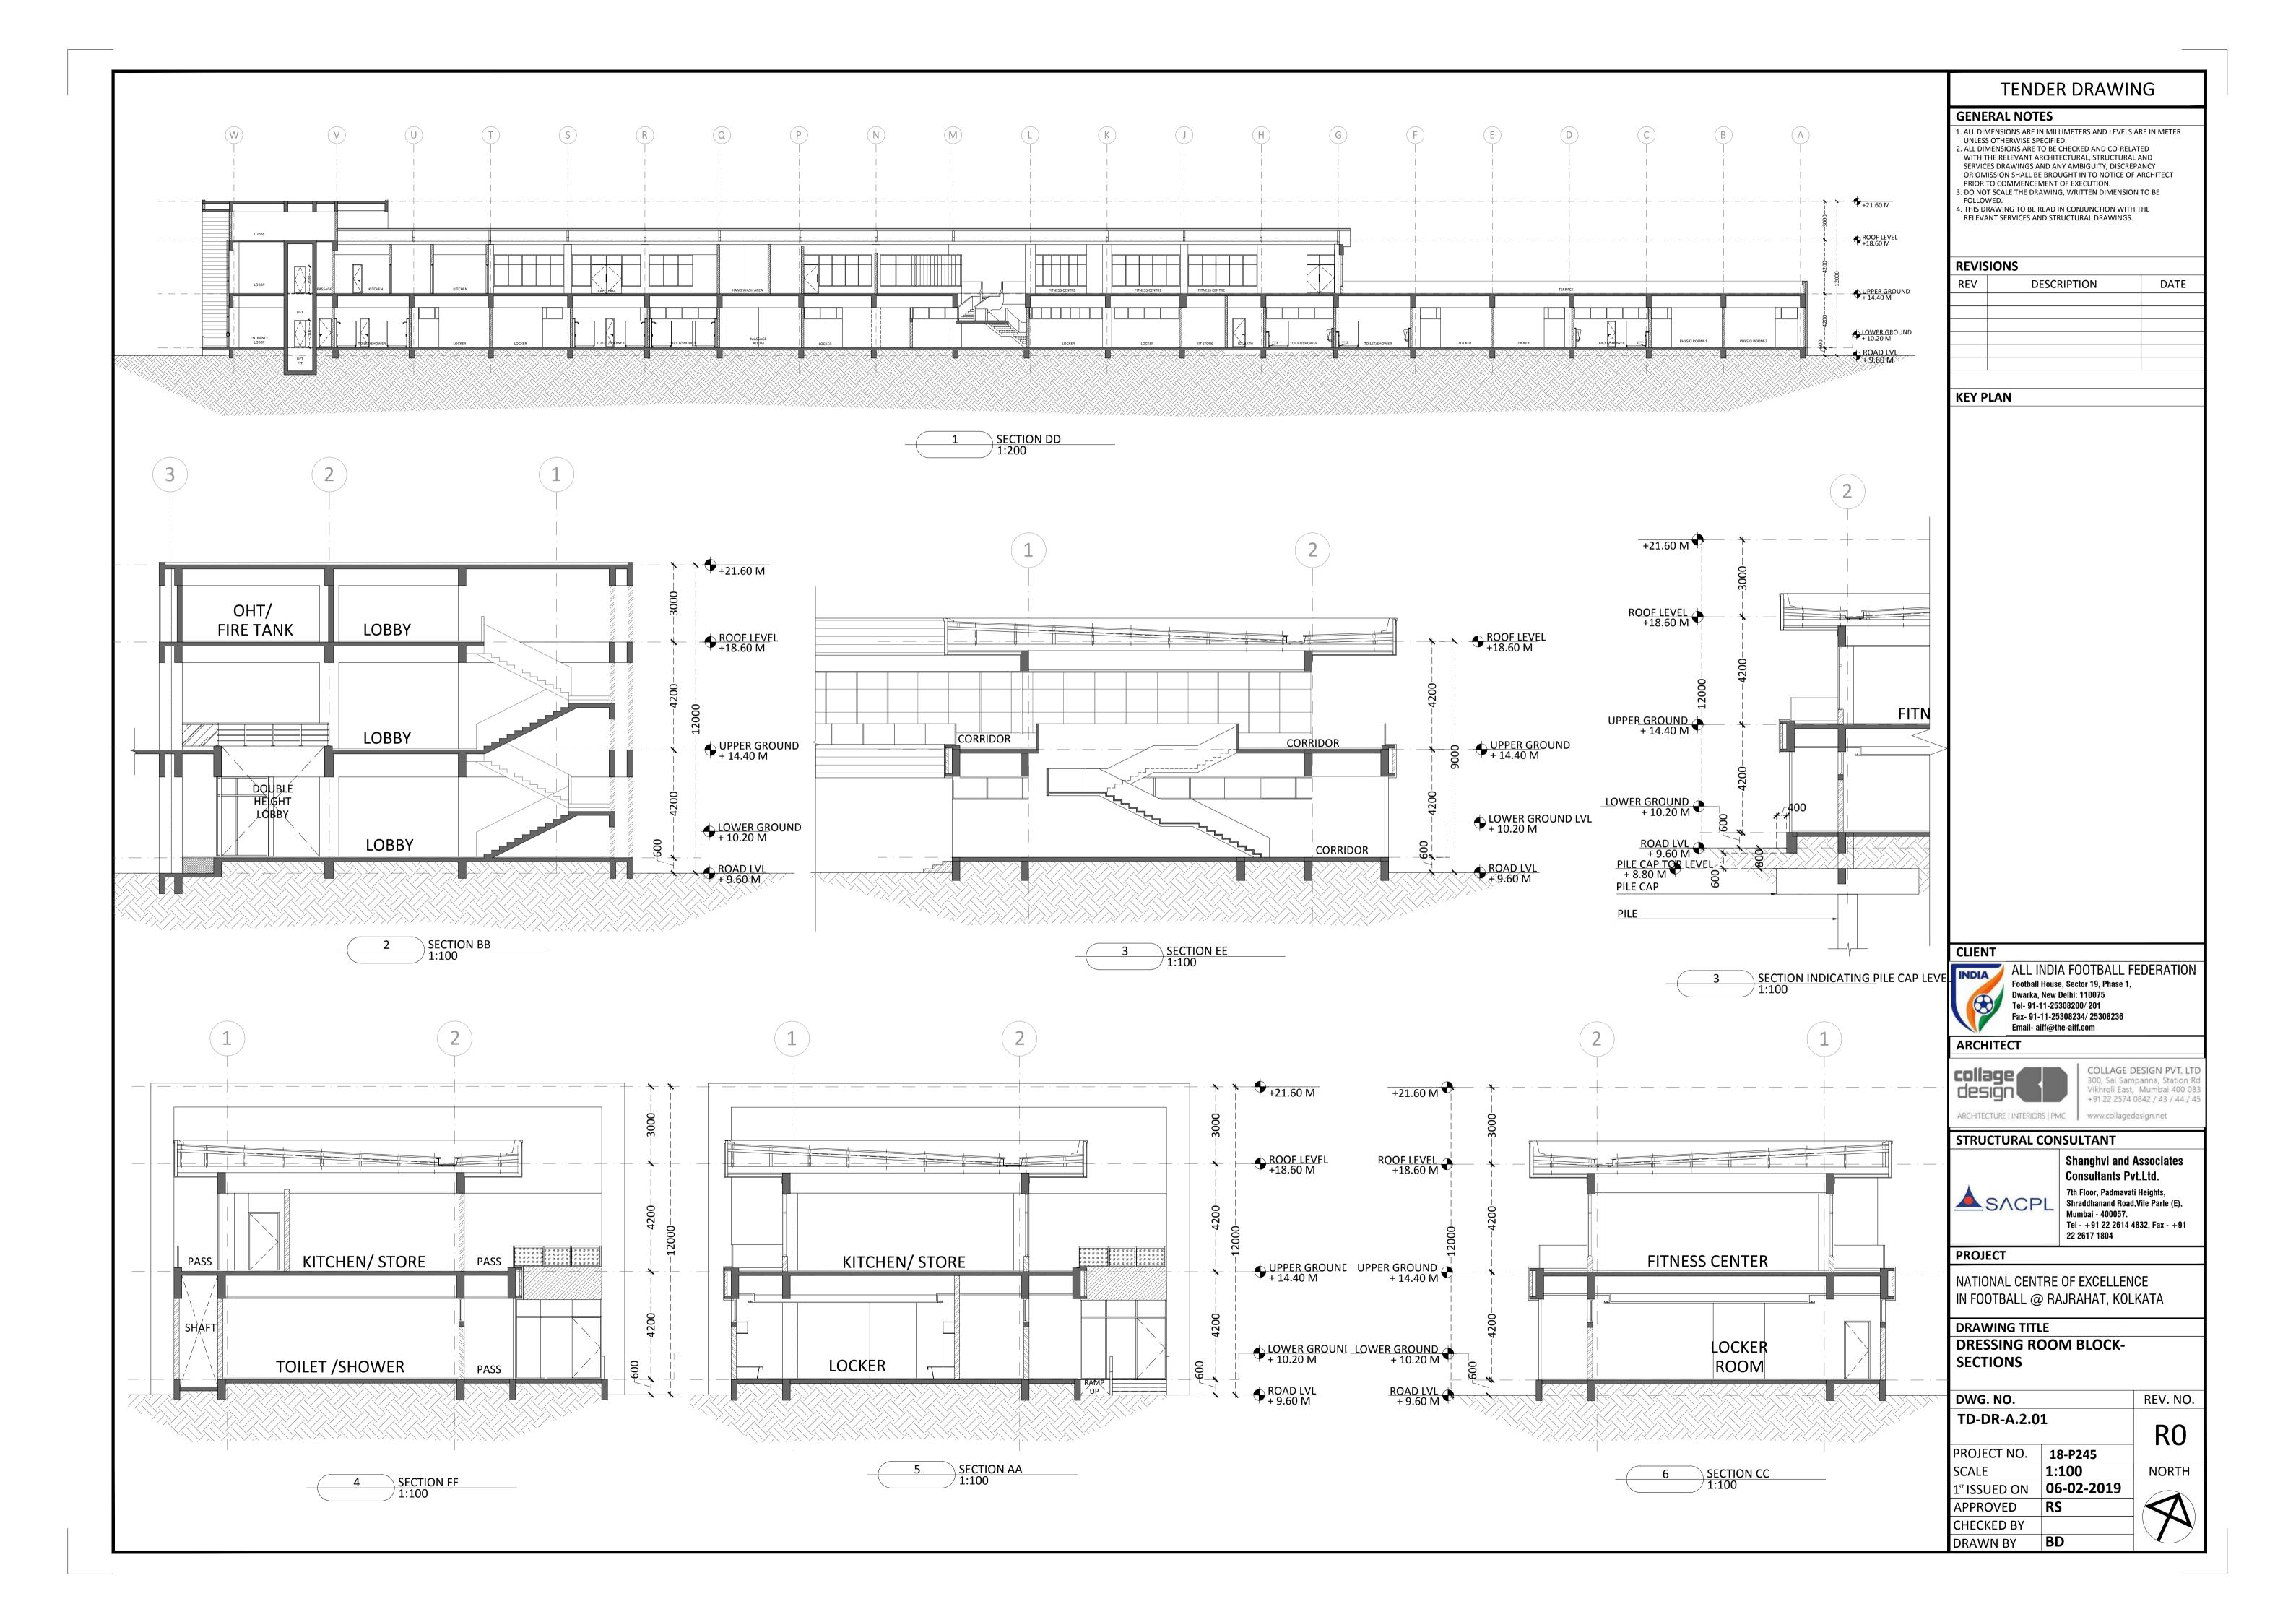


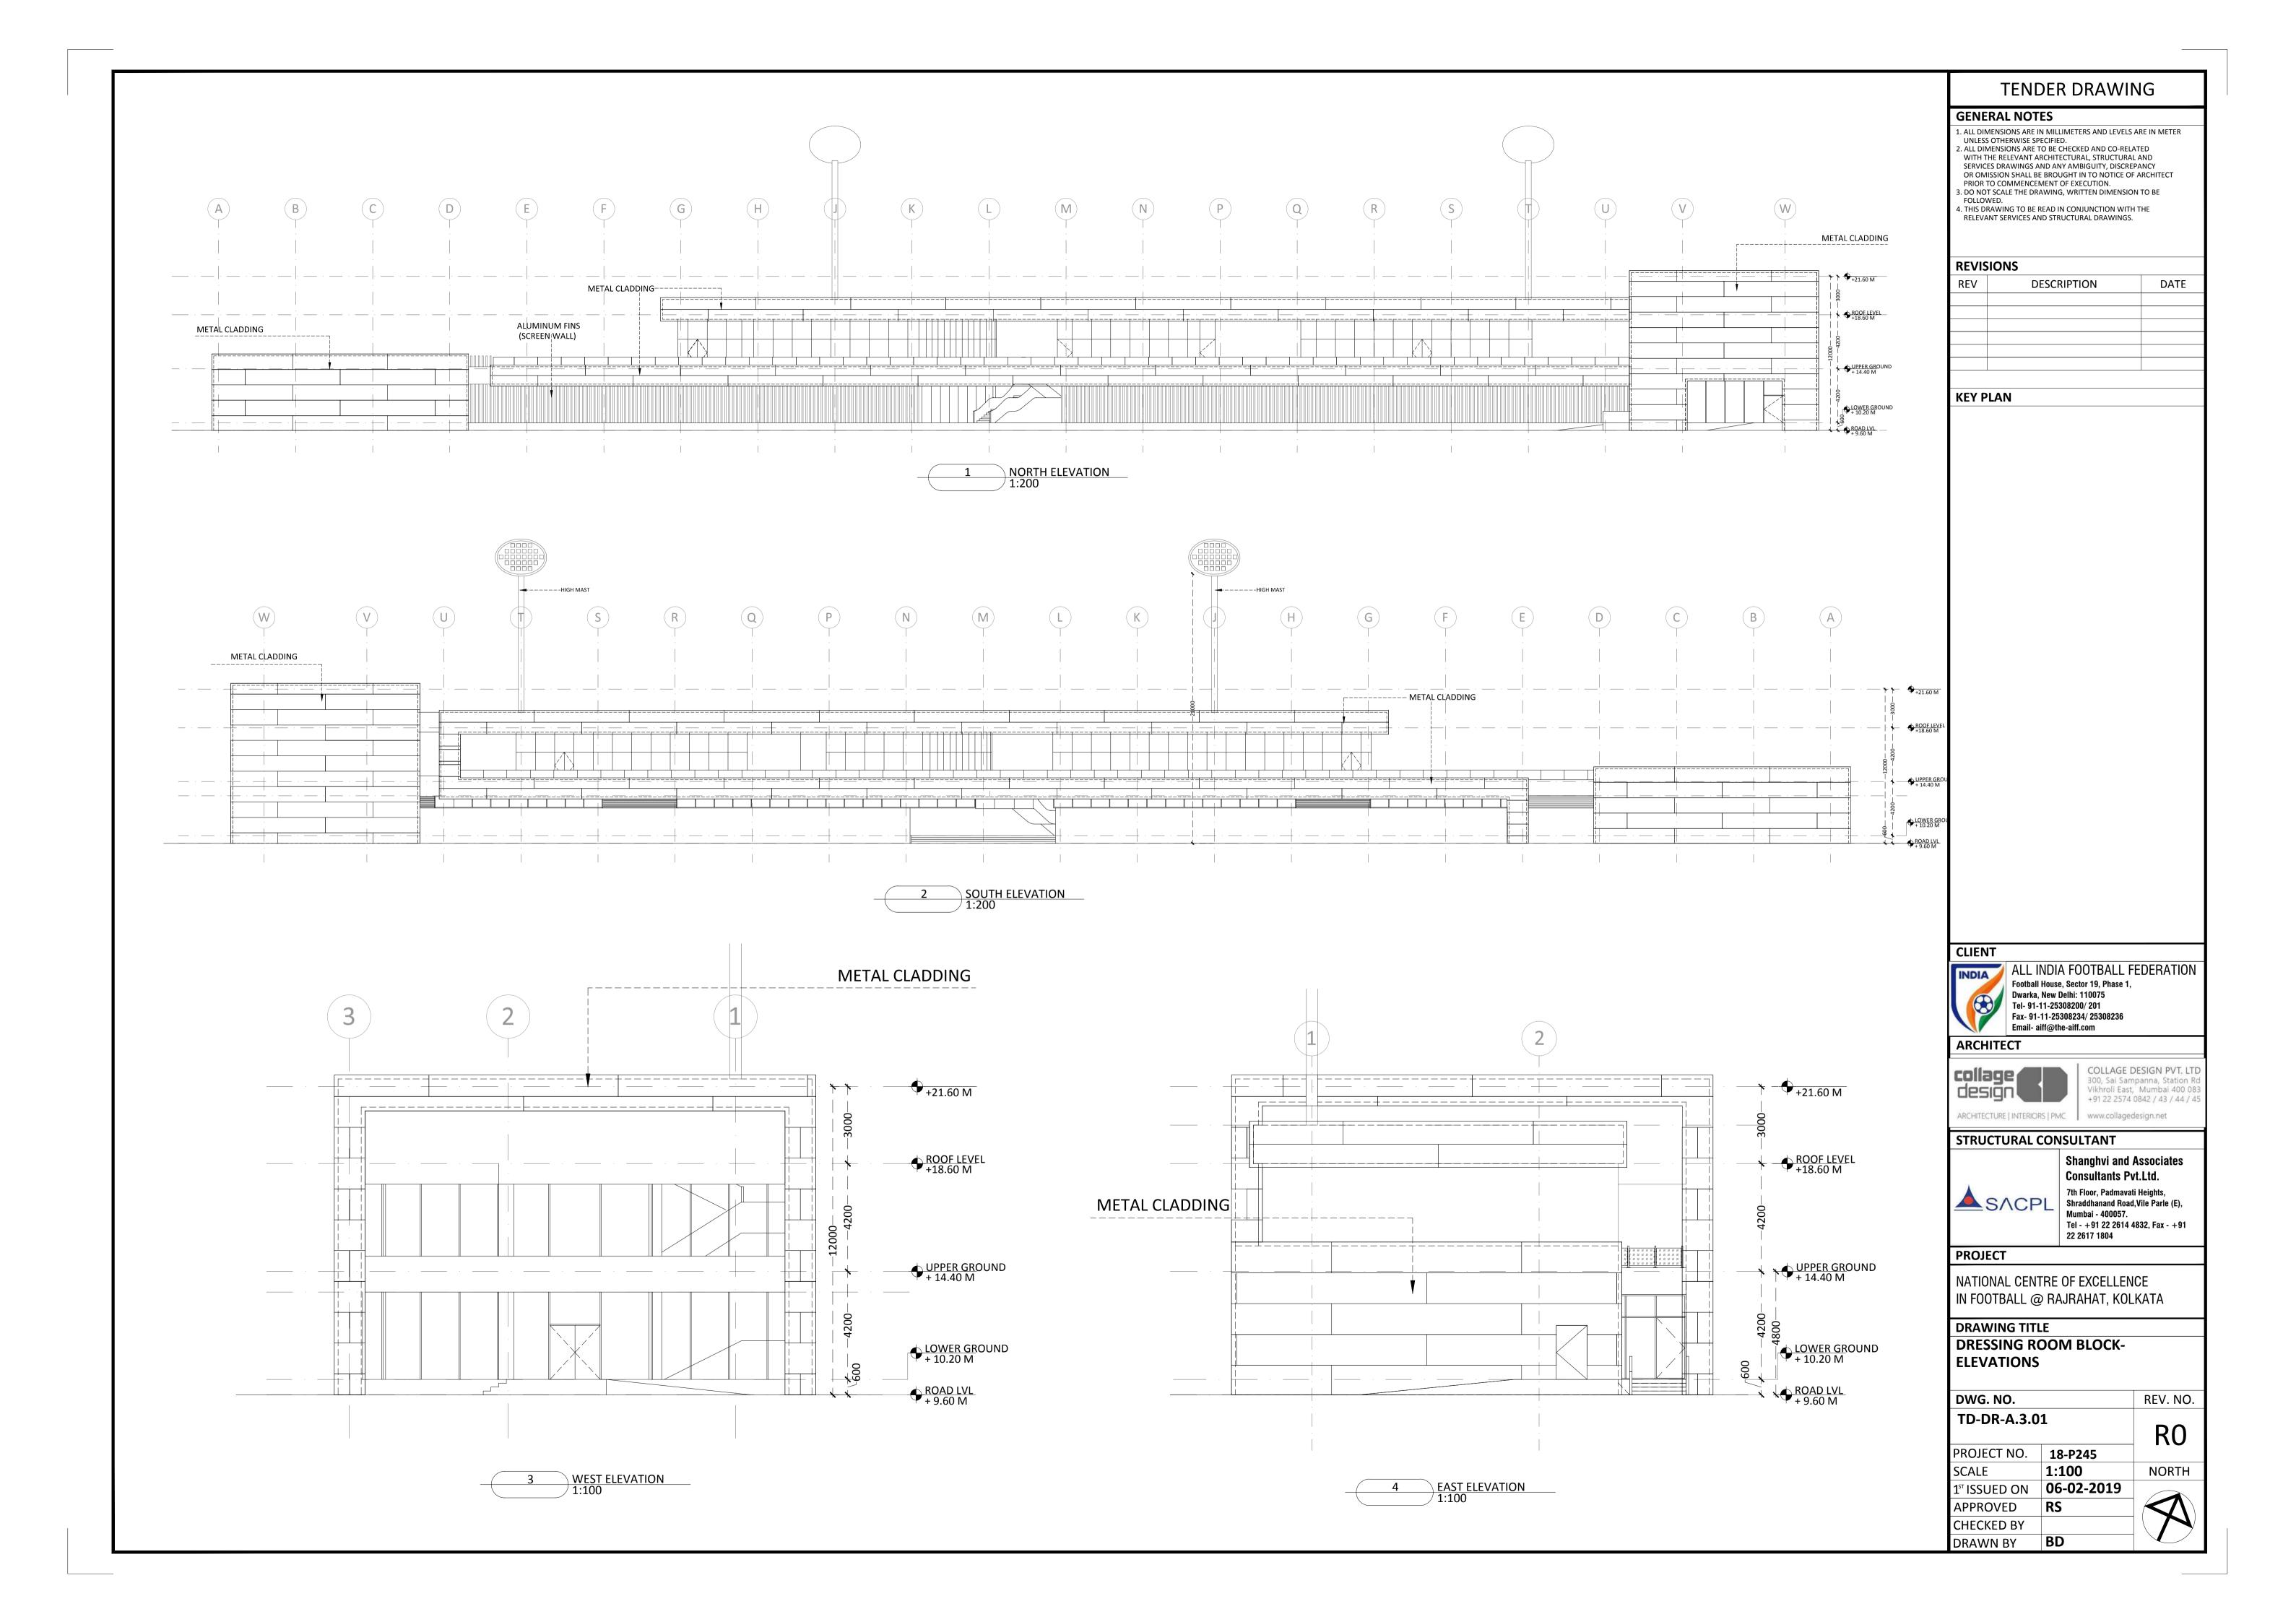

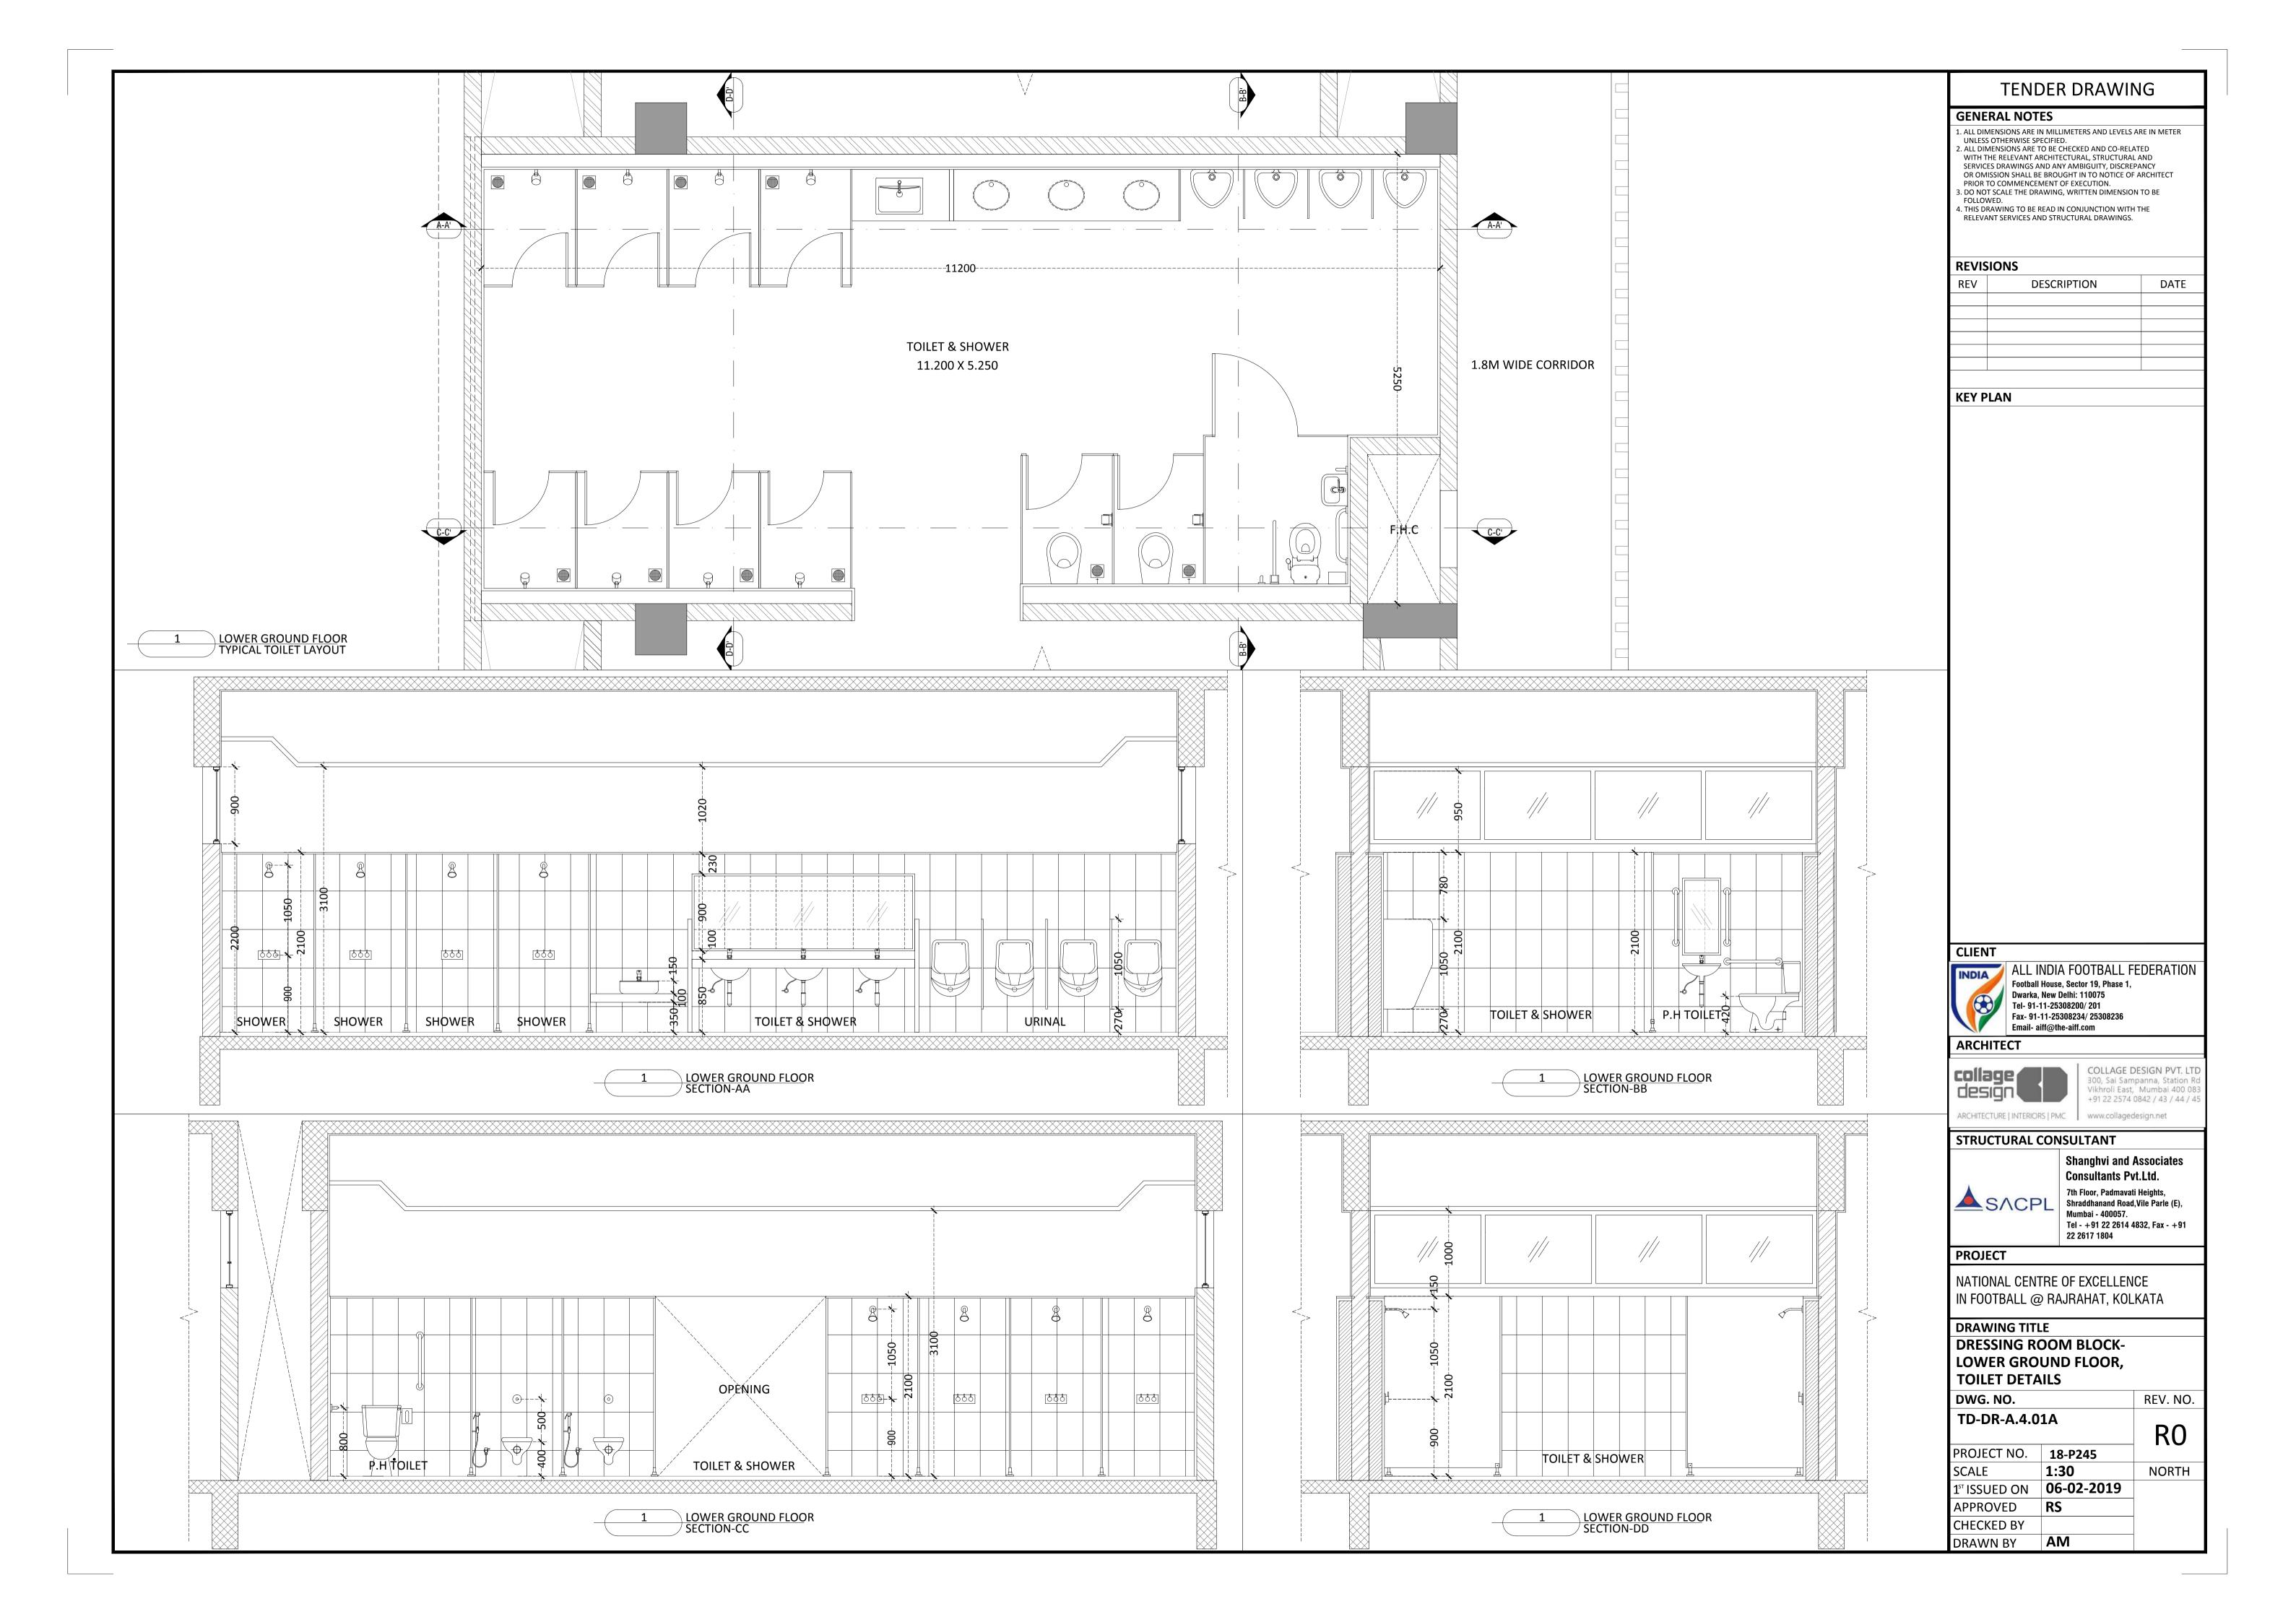


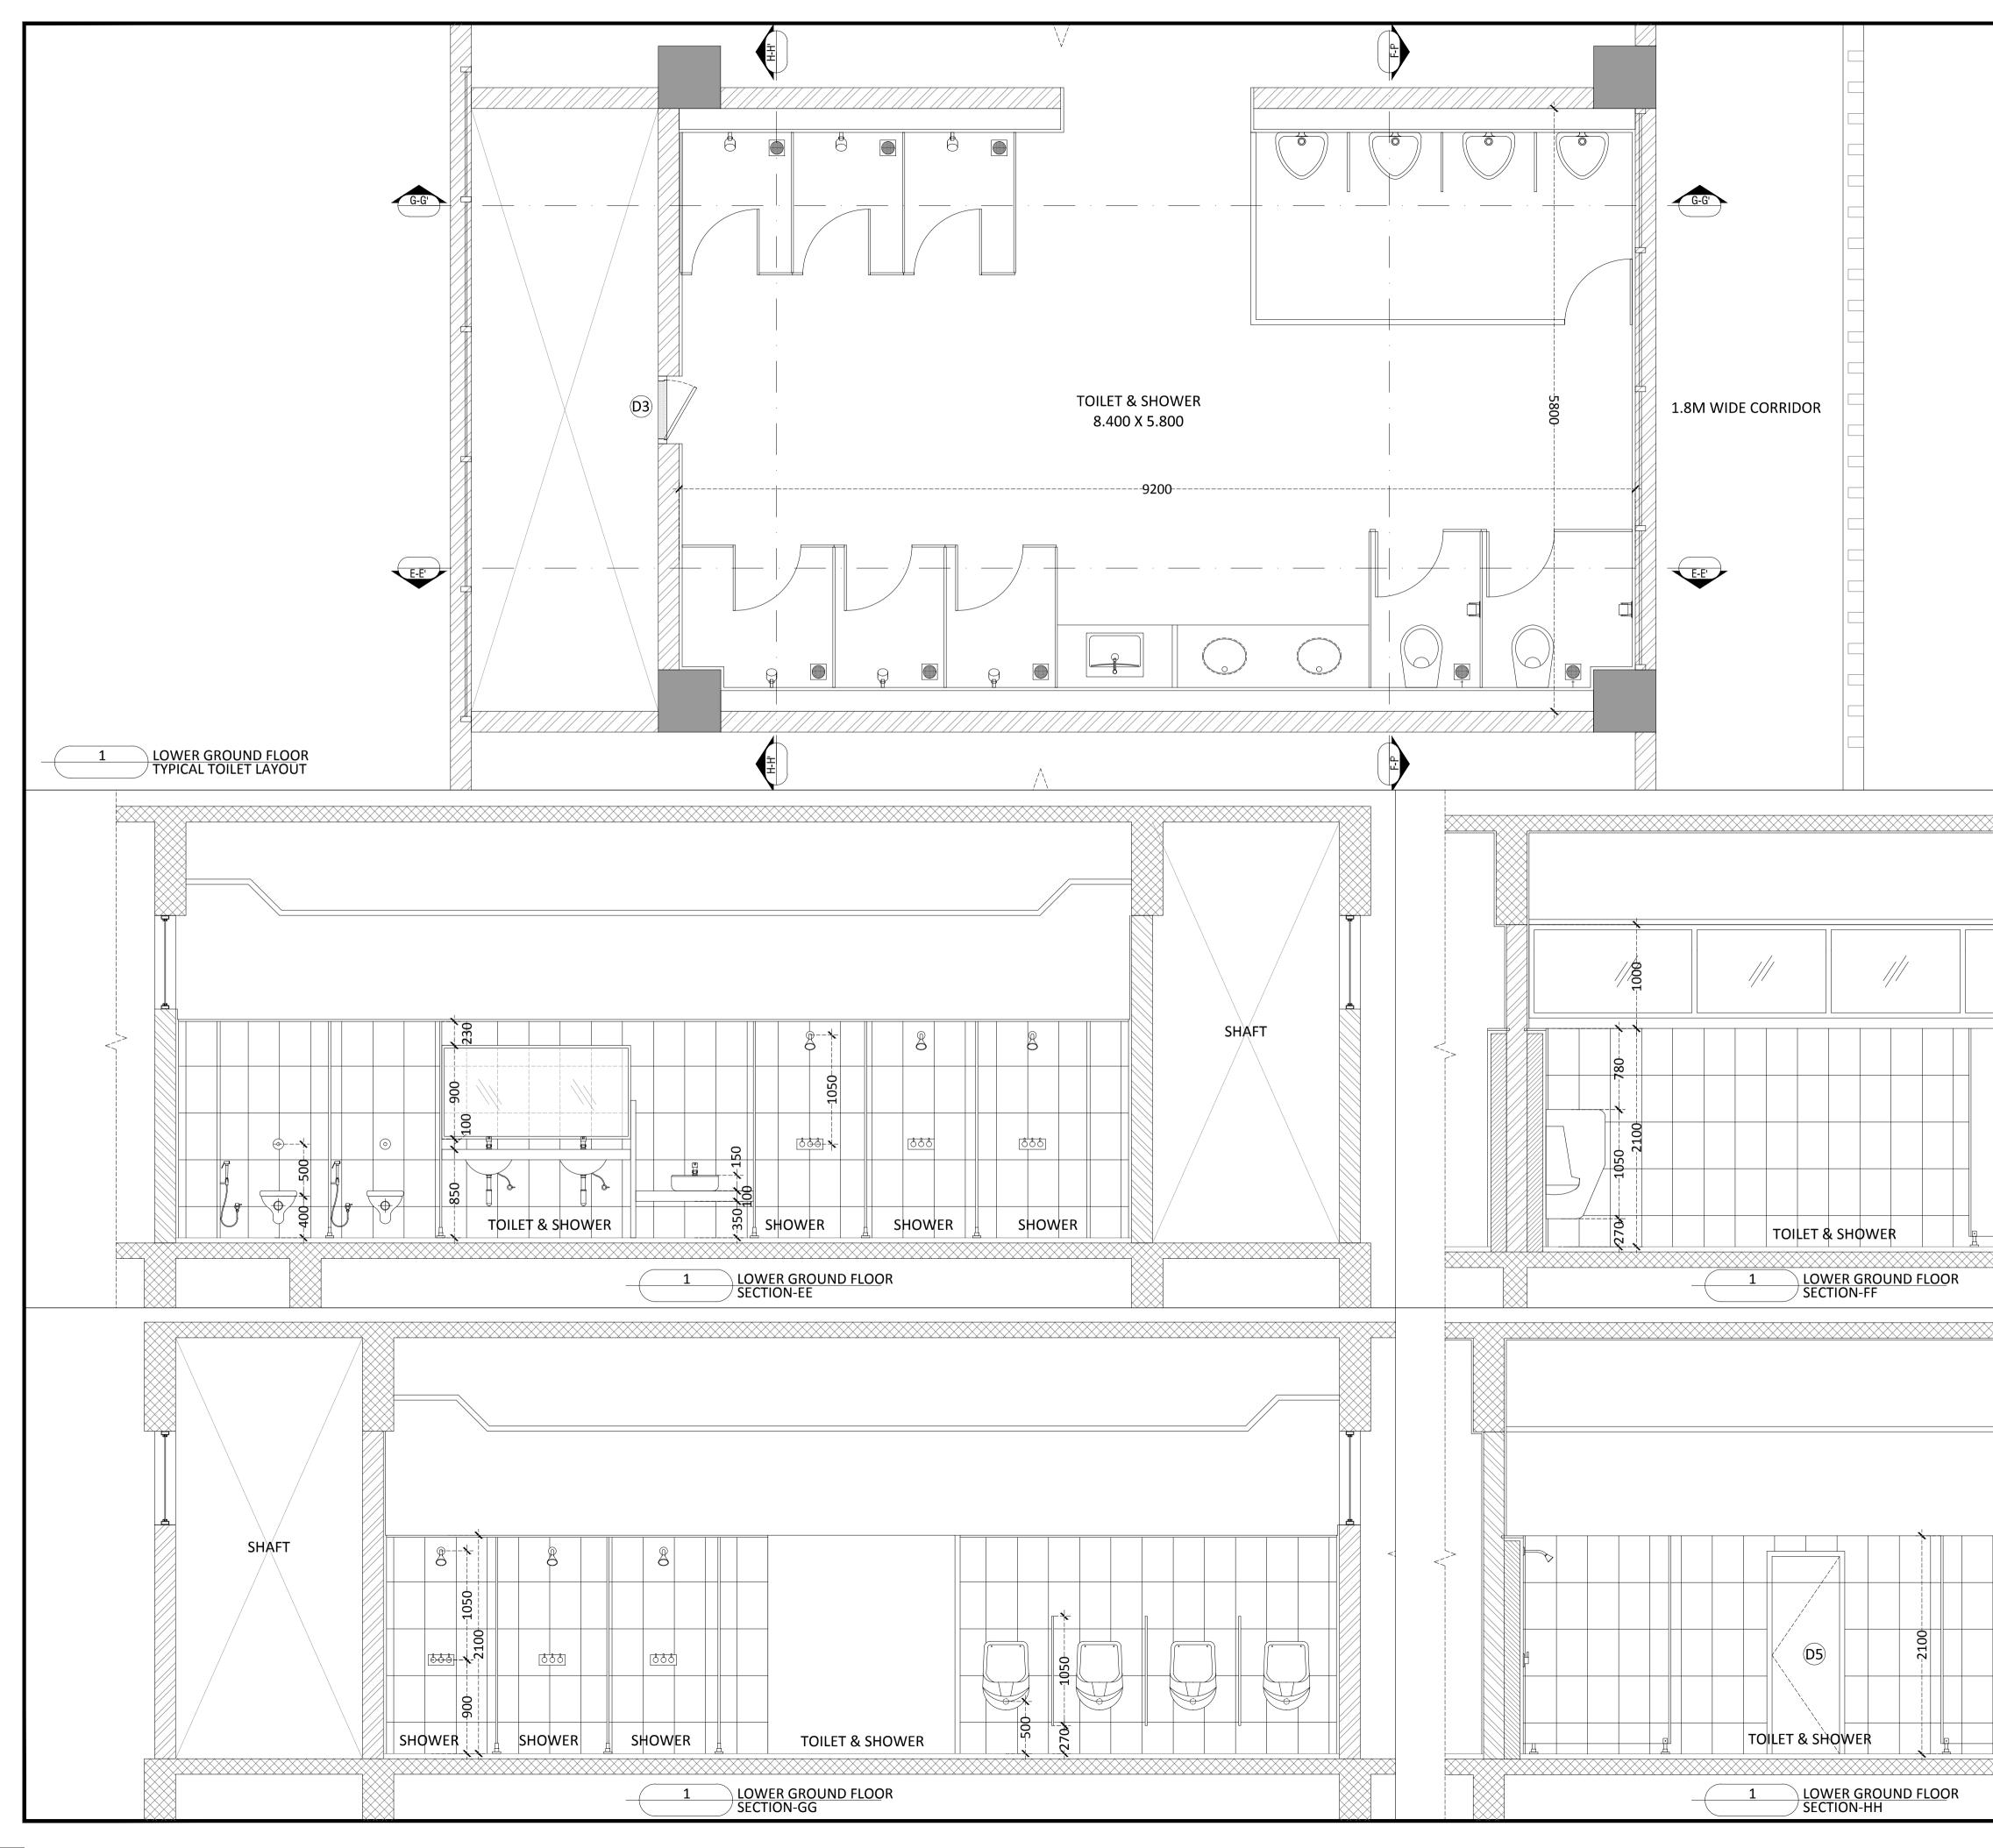


	TEND	DER DRAWI	NG
	UNLESS OTHERWISE SP 2. ALL DIMENSIONS ARE T WITH THE RELEVANT AI SERVICES DRAWINGS A OR OMISSION SHALL BE PRIOR TO COMMENCEM	N MILLIMETERS AND LEVELS ECIFIED. O BE CHECKED AND CO-REL RCHITECTURAL, STRUCTURA ND ANY AMBIGUITY, DISCRE E BROUGHT IN TO NOTICE O	ATED L AND EPANCY F ARCHITECT
		READ IN CONJUNCTION WITH ID STRUCTURAL DRAWINGS.	
	REVISIONS		
	REV DI	ESCRIPTION	DATE
	KEY PLAN		
	CLIENT		
		NDIA FOOTBALL F House, Sector 19, Phase 1, New Delhi: 110075	
	ALL II Football Dwarka, Tel- 91- Fax- 91-	House, Sector 19, Phase 1, New Delhi: 110075 11-25308200/ 201 11-25308234/ 25308236	
	ALL II Football Dwarka, Tel- 91- Fax- 91-	House, Sector 19, Phase 1, New Delhi: 110075 11-25308200/ 201	
	ALL II Football Dwarka, Tel- 91- Fax- 91- Email- a ARCHITECT	House, Sector 19, Phase 1, New Delhi: 110075 11-25308200/ 201 11-25308234/ 25308236 iff@the-aiff.com COLLAGE I 300, Sai San	DESIGN PVT. LTD
*	ALL II Football Dwarka, Tel-91- Fax-91- Email- a ARCHITECT	House, Sector 19, Phase 1, New Delhi: 110075 11-25308200/ 201 11-25308234/ 25308236 iff@the-aiff.com COLLAGE I 300, Sai San Vikhroli East +91 22 2574	DESIGN PVT. LTD npanna, Station Rd , Mumbai 400 083 0842 / 43 / 44 / 45
*	ALL II Football Dwarka, Tel-91- Fax-91- Email- a ARCHITECT COULT ARCHITECT	House, Sector 19, Phase 1, New Delhi: 110075 11-25308200/ 201 11-25308234/ 25308236 iff@the-aiff.com COLLAGE I 300, Sai San Vikhroli East +91 22 2574 www.collaged	DESIGN PVT. LTD npanna, Station Rd , Mumbai 400 083 0842 / 43 / 44 / 45
*	ALL II Football Dwarka, Tel-91- Fax-91- Email- a ARCHITECT	House, Sector 19, Phase 1, New Delhi: 110075 11-25308200/ 201 11-25308234/ 25308236 iff@the-aiff.com COLLAGE I 300, Sai San Vikhroli East +91 22 2574 www.collaged CONSULTANT Shanghvi and	DESIGN PVT. LTD npanna, Station Rd , Mumbai 400 083 0842 / 43 / 44 / 45 design.net Associates
*	ALL II Football Dwarka, Tel-91- Fax-91- Email- a ARCHITECT COLLAGE ARCHITECTURE   INTERIOR STRUCTURAL C	House, Sector 19, Phase 1, New Delhi: 110075 11-25308200/ 201 11-25308234/ 25308236 iff@the-aiff.com COLLAGE I 300, Sai San Vikhroli East +91 22 2574 www.collaged CONSULTANT Shanghvi and Consultants Pu 7th Elogr. Padmava	DESIGN PVT. LTD hpanna, Station Rd , Mumbai 400 083 0842 / 43 / 44 / 45 design.net Associates /t.Ltd. ti Heights,
*	ALL II Football Dwarka, Tel-91- Fax-91- Email- a ARCHITECT COULT ARCHITECT	House, Sector 19, Phase 1, New Delhi: 110075         11-25308200/ 201         11-25308234/ 25308236         iff@the-aiff.com         COLLAGE I 300, Sai San Vikhroli East +91 22 2574         KS   PMC         CONSULTANT         Shanghvi and Consultants Py 7th Floor, Padmava Shraddhanand Roac Mumbai - 400057. Tel - +91 22 2614	DESIGN PVT. LTD hpanna, Station Rd , Mumbai 400 083 0842 / 43 / 44 / 45 design.net Associates /t.Ltd. ti Heights, I,Vile Parle (E),
*	ALL II Football Dwarka, Tel-91- Fax-91- Email- a ARCHITECT COLLAGE ARCHITECTURE   INTERIOR STRUCTURAL C	House, Sector 19, Phase 1, New Delhi: 110075 11-25308200/ 201 11-25308234/ 25308236 iff@the-aiff.com COLLAGE I 300, Sai San Vikhroli East +91 22 2574 www.collaged CONSULTANT Shanghvi and Consultants Pu 7th Floor, Padmava Shraddhanand Road Mumbai - 400057.	DESIGN PVT. LTD hpanna, Station Rd , Mumbai 400 083 0842 / 43 / 44 / 45 design.net Associates /t.Ltd. ti Heights, I,Vile Parle (E),
	ALL II Football Dwarka, Tel-91- Fax-91- Email- a ARCHITECT ARCHITECT ARCHITECTURE   INTERIOR STRUCTURAL O BROJECT	House, Sector 19, Phase 1, New Delhi: 110075         11-25308200/ 201         11-25308234/ 25308236         iff@the-aiff.com         COLLAGE I 300, Sai San Vikhroli East +91 22 2574         KS   PMC         CONSULTANT         Shanghvi and Consultants Py 7th Floor, Padmava Shraddhanand Roac Mumbai - 400057. Tel - +91 22 2614	DESIGN PVT. LTD ppanna, Station Rd , Mumbai 400 083 0842 / 43 / 44 / 45 design.net Associates /t.Ltd. ti Heights, 1,Vile Parle (E), 4832, Fax - +91
*	ALL II Football Dwarka, Tel-91- Fax-91- Email- a ARCHITECT COLLAGE ARCHITECTURE   INTERIOR STRUCTURAL C STRUCTURAL C PROJECT NATIONAL CENT IN FOOTBALL @	House, Sector 19, Phase 1, New Delhi: 110075 11-25308200/ 201 11-25308234/ 25308236 iff@the-aiff.com COLLAGE I 300, Sai San Vikhroli East +91 22 2574 www.collaged CONSULTANT Shanghvi and Consultants Py 7th Floor, Padmava Shraddhanand Road Mumbai - 400057. Tel - +91 22 2614 22 2617 1804	DESIGN PVT. LTD hpanna, Station Rd , Mumbai 400 083 0842 / 43 / 44 / 45 design.net Associates yt.Ltd. ti Heights, 1,Vile Parle (E), 4832, Fax - +91 ICE
	ALL II Football Dwarka, Tel-91- Fax-91- Email- a ARCHITECT COSSIGN ARCHITECTURE   INTERIOR STRUCTURAL OF STRUCTURAL OF PROJECT NATIONAL CENT IN FOOTBALL @ DRAWING TITL	House, Sector 19, Phase 1, New Delhi: 110075 11-25308200/ 201 11-25308234/ 25308236 iff@the-aiff.com COLLAGE I 300, Sai San Vikhroli East +91 22 2574 www.collaged CONSULTANT Shanghvi and Consultants Pa 7th Floor, Padmava Shraddhanand Road Mumbai - 400057. Tel - +91 22 2614 / 22 2617 1804	DESIGN PVT. LTD hpanna, Station Rd , Mumbai 400 083 0842 / 43 / 44 / 45 design.net Associates yt.Ltd. ti Heights, 1,Vile Parle (E), 4832, Fax - +91 ICE
	ALL II Football Dwarka, Tel-91- Fax-91- Email- a ARCHITECT ARCHITECT ARCHITECTURE   INTERIOR STRUCTURAL O ARCHITECTURE   INTERIOR BROJECT NATIONAL CENT IN FOOTBALL @ DRAWING TITL DRESSING RO LOWER GRO	House, Sector 19, Phase 1, New Delhi: 110075 11-25308200/ 201 11-25308234/ 25308236 iff@the-aiff.com COLLAGE I 300, Sai San Vikhroli East +91 22 2574 www.collaged CONSULTANT Shanghvi and Consultants Py 7th Floor, Padmava Shraddhanand Road Mumbai - 400057. Tel - +91 22 2614 22 2617 1804 TRE OF EXCELLEN P RAJRAHAT, KOL E DOM BLOCK- UND FLOOR,	DESIGN PVT. LTD hpanna, Station Rd , Mumbai 400 083 0842 / 43 / 44 / 45 design.net Associates yt.Ltd. ti Heights, 1,Vile Parle (E), 4832, Fax - +91 ICE
	ALL II Football Dwarka, Tel-91- Fax-91- Email- a ARCHITECT COLLEGIO ARCHITECTURAL O ARCHITECTURE   INTERIOR STRUCTURAL O ARCHITECTURE   INTERIOR STRUCTURAL O PROJECT NATIONAL CENT IN FOOTBALL @ DRAWING TITL DRESSING RO LOWER GRO TOILET DETA	House, Sector 19, Phase 1, New Delhi: 110075 11-25308200/ 201 11-25308234/ 25308236 iff@the-aiff.com COLLAGE I 300, Sai San Vikhroli East +91 22 2574 www.collaged CONSULTANT Shanghvi and Consultants Py 7th Floor, Padmava Shraddhanand Road Mumbai - 400057. Tel - +91 22 2614 22 2617 1804 TRE OF EXCELLEN P RAJRAHAT, KOL E DOM BLOCK- UND FLOOR,	DESIGN PVT. LTD hpanna, Station Rd , Mumbai 400 083 0842 / 43 / 44 / 45 design.net Associates yt.Ltd. ti Heights, 1,Vile Parle (E), 4832, Fax - +91 ICE
	ALL II Football Dwarka, Tel-91- Fax-91- Email- a ARCHITECT ARCHITECT ARCHITECTURE   INTERIOR STRUCTURAL O ARCHITECTURE   INTERIOR BROJECT NATIONAL CENT IN FOOTBALL @ DRAWING TITL DRESSING RO LOWER GRO	House, Sector 19, Phase 1, New Delhi: 110075 11-25308200/ 201 11-25308234/ 25308236 iff@the-aiff.com COLLAGE I 300, Sai San Vikhroli East +9122 2574 www.collaged CONSULTANT Shanghvi and Consultants Py 7th Floor, Padmava Shraddhanand Road Mumbai - 400057. Tel - +91 22 2614 22 2617 1804 TRE OF EXCELLEN P RAJRAHAT, KOL E DOM BLOCK- UND FLOOR, ILS	DESIGN PVT. LTD panna, Station Rd , Mumbai 400 083 0842 / 43 / 44 / 45 design.net Associates /t.Ltd. ti Heights, 1,Vile Parle (E), 4832, Fax - +91 ICE KATA REV. NO.
	ALL II Football Dwarka, Tel-91- Fax-91- Email- a ARCHITECT COLLEGIO ARCHITECTURAL O ARCHITECTURE   INTERIOR STRUCTURAL O ARCHITECTURE   INTERIOR STRUCTURAL O PROJECT NATIONAL CENT IN FOOTBALL @ DRAWING TITL DRESSING RO LOWER GRO TOILET DETA DWG. NO.	House, Sector 19, Phase 1, New Delhi: 110075 11-25308200/ 201 11-25308234/ 25308236 iff@the-aiff.com COLLAGE I 300, Sai San Vikhroli East +9122 2574 www.collaged CONSULTANT Shanghvi and Consultants Py 7th Floor, Padmava Shraddhanand Road Mumbai - 400057. Tel - +91 22 2614 22 2617 1804 TRE OF EXCELLEN P RAJRAHAT, KOL E DOM BLOCK- UND FLOOR, ILS	DESIGN PVT. LTD ppanna, Station Rd , Mumbai 400 083 0842 / 43 / 44 / 45 design.net Associates yt.Ltd. ti Heights, 1,Vile Parle (E), 4832, Fax - +91 ICE KATA
	ALL II Football Dwarka, Tel-91- Fax-91- Email- a ARCHITECT COLLEGIC ARCHITECTURAL O ARCHITECTURE INTERIOR STRUCTURAL O ARCHITECTURE INTERIOR ORAVING TITL DRESSING RO LOWER GRO TOILET DETA DWG. NO. TD-DR-A.4.0 PROJECT NO. SCALE	House, Sector 19, Phase 1, New Delhi: 110075 11-25308200/ 201 11-25308234/ 25308236 iff@the-aiff.com COLLAGE I 300, Sai San Vikhroli East +9122 2574 www.collaged CONSULTANT Shanghvi and Consultants Py 7th Floor, Padmava Shraddhanand Road Mumbai - 400057. Tel - +91 22 2614 22 2617 1804 TRE OF EXCELLEN P RAJRAHAT, KOL E DOM BLOCK- UND FLOOR, ILS 18-P245 1:30	DESIGN PVT. LTD panna, Station Rd , Mumbai 400 083 0842 / 43 / 44 / 45 design.net Associates /t.Ltd. ti Heights, 1,Vile Parle (E), 4832, Fax - +91 ICE KATA REV. NO.
	ALL II Football Dwarka, Tel-91- Fax-91- Email- a ARCHITECT COLLEGIC ARCHITECTURAL O ARCHITECTURAL O STRUCTURAL O STRUCTURAL O PROJECT NATIONAL CENT IN FOOTBALL @ DRAWING TITL DRESSING RO LOWER GRO TOILET DETA DWG. NO. TD-DR-A.4.0 PROJECT NO.	House, Sector 19, Phase 1, New Delhi: 110075 11-25308200/ 201 11-25308234/ 25308236 iff@the-aiff.com COLLAGE I 300, Sai San Vikhroli East +91 22 2574 www.collaged CONSULTANT CONSULTANT Shanghvi and Consultants Pu 7th Floor, Padmava Shraddhanand Road Mumbai - 400057. Tel - +91 22 2614 22 2617 1804 CRE OF EXCELLEN PAJRAHAT, KOL E DOM BLOCK- UND FLOOR, ALLS 18-P245	DESIGN PVT. LTD panna, Station Rd , Mumbai 400 083 0842 / 43 / 44 / 45 design.net Associates /t.Ltd. ti Heights, 1,Vile Parle (E), 4832, Fax - +91 ICE .KATA REV. NO. REV. NO.

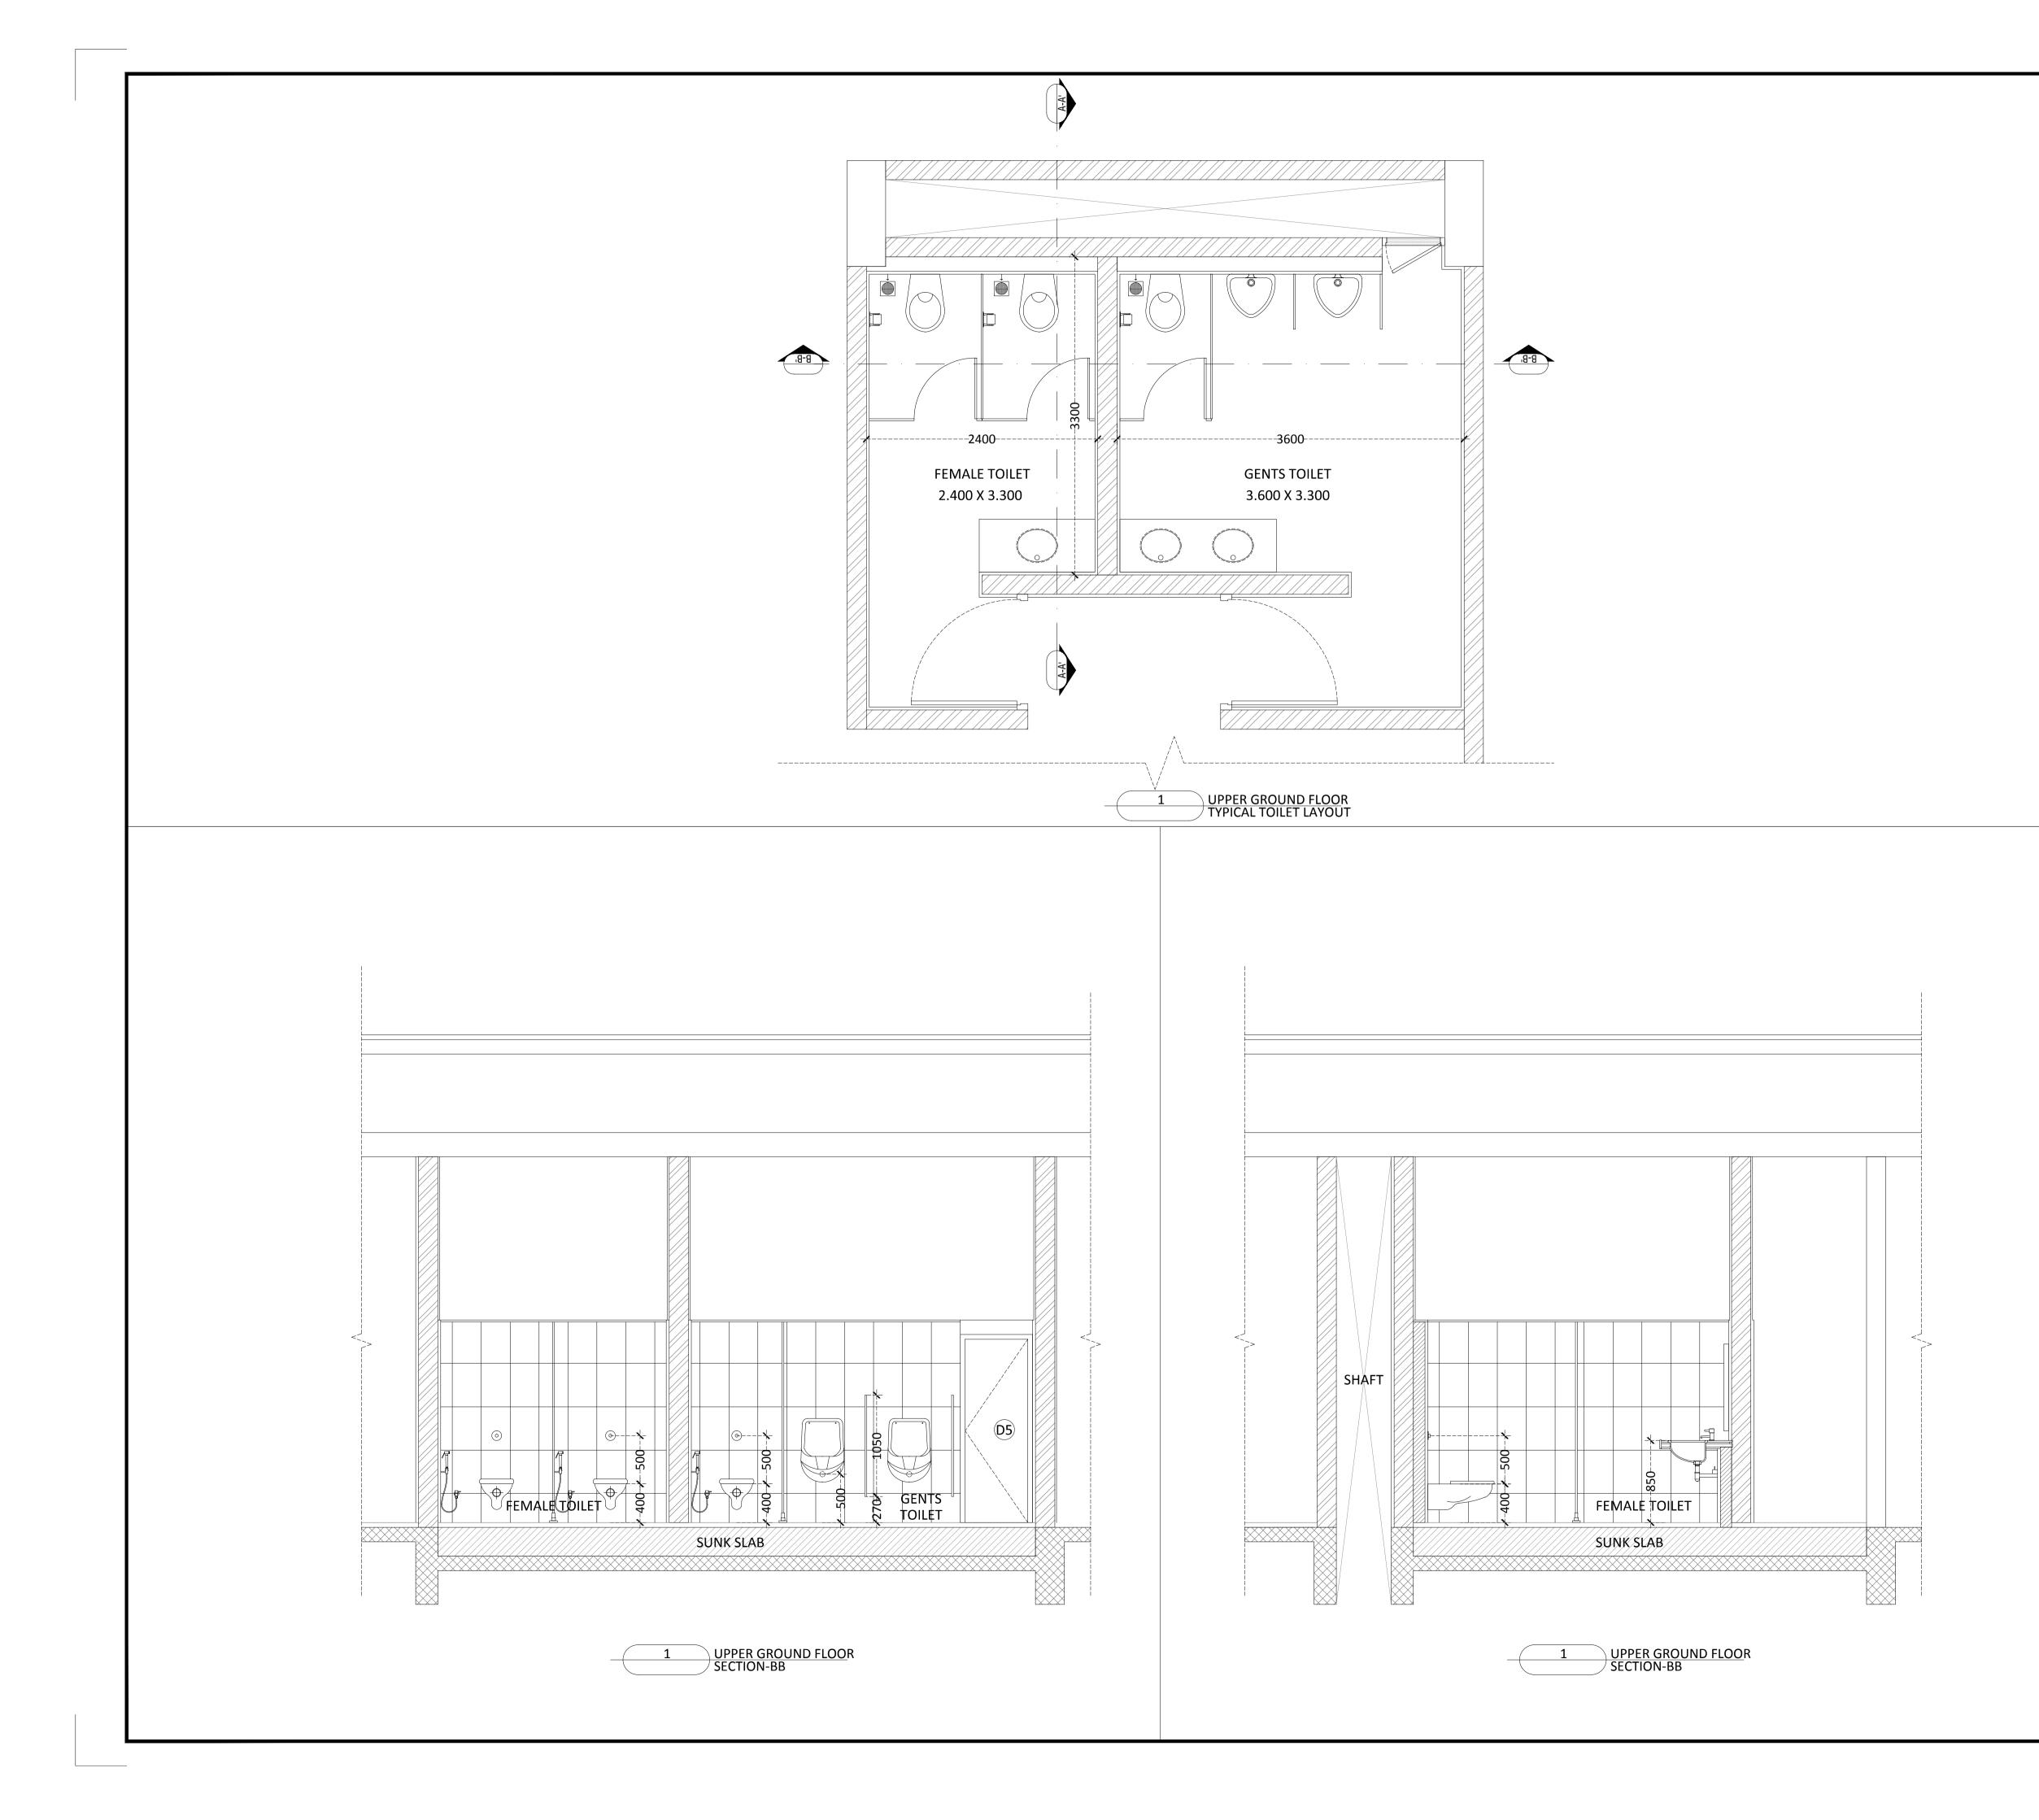



		ירט ו	ער אין	
			DRAWI	٧G
	<b>RAL NOTE</b> MENSIONS ARE IN		TERS AND LEVELS	ARE IN METER
2. ALL DI	S OTHERWISE SPE MENSIONS ARE TO THE RELEVANT AR	D BE CHEC		
SERVIC OR OM	ES DRAWINGS AN	ID ANY AN BROUGHT	IBIGUITY, DISCRE	PANCY
	TO COMMENCEM T SCALE THE DRA WED.			N TO BE
	RAWING TO BE RE ANT SERVICES ANI			
REVIS	SIONS			
REV	DE	SCRIPT	TION	DATE
	I			
KEY P	'LAN			
CLIEN	JT			
INDIA		IDIA F	OOTBALL F	EDERATION
	Football H	louse, Se New Delhi	ctor 19, Phase 1, : 110075	
	🍏   Tel- 91-1	1-253082		
	Email- aif	if@the-ail		
ARCH	IITECT		-	
colla	age 💋		300, Sai Sam	DESIGN PVT. LTD Ipanna, Station Rd
des	iign 🌑			Mumbai 400 083 0842 / 43 / 44 / 45
ARCHITE	CTURE   INTERIORS	5   PMC	www.collaged	design.net
STRU	CTURAL C	ONSU	ILTANT	
			anghvi and	
		7+1	onsultants Pv Floor, Padmavat	
	SACP	Sh	raddhanand Road Imbai - 400057.	
		Te	- +91 22 2614 4 2617 1804	1832, Fax - +91
	ECT	LL		
PROJ				05
NATIO	)NAL CENT OTBALL @			
NATIO IN FO	OTBALL @	RAJR		
NATIO IN FOO DRAV		RAJR E	AHAT, KOL	
NATIO IN FOO DRAV DRES	OTBALL @	RAJR E DOM	AHAT, KOL	
NATIO IN FOO DRAV DRES UPPI	OTBALL @ WING TITL SSING RC	RAJR E DOM IND F	AHAT, KOL	
NATIO IN FOO DRAV DRES UPPI TOIL DWG	OTBALL @ WING TITL SSING RC ER GROU ET DETA . NO.	RAJR E DOM IND F ILS	AHAT, KOL	
NATIO IN FOO DRAV DRES UPPI TOIL DWG	OTBALL @ WING TITL SSING RC ER GROU .ET DETA	RAJR E DOM IND F ILS	AHAT, KOL	KATA REV. NO.
NATIO IN FOO DRAV DRES UPPI TOIL DWG TD-D	OTBALL @ WING TITL SSING RC ER GROU ET DETA . NO.	RAJR E DOM IND F ILS	AHAT, KOL BLOCK- LOOR,	.KATA
NATIO IN FOO DRAV DRES UPPI TOIL DWG TD-D	OTBALL @ WING TITL SSING RC ER GROU ET DETA . NO. DR-A.4.01	RAJR E DOM IND F ILS	AHAT, KOL BLOCK- LOOR,	KATA REV. NO.
NATIO IN FOU DRAV DRES UPPU TOIL DWG TD-E PROJE SCALE	OTBALL @ VING TITL SSING RC ER GROU ET DETA . NO. DR-A.4.01 ECT NO. JED ON	RAJR E DOM IND F ILS LC 18-P 1:30 05-0	AHAT, KOL BLOCK- LOOR,	KATA rev. no. <b>RO</b>
NATIO IN FOO DRAV DRES UPPI TOIL DWG TD-C PROJE SCALE 1 <sup>ST</sup> ISSU APPRO	OTBALL @ VING TITL SSING RC ER GROU ET DETA . NO. DR-A.4.01 ECT NO. JED ON	RAJR E DOM IND F ILS LC 18-P 1:30	AHAT, KOL BLOCK- LOOR, 245	KATA rev. no. <b>RO</b>

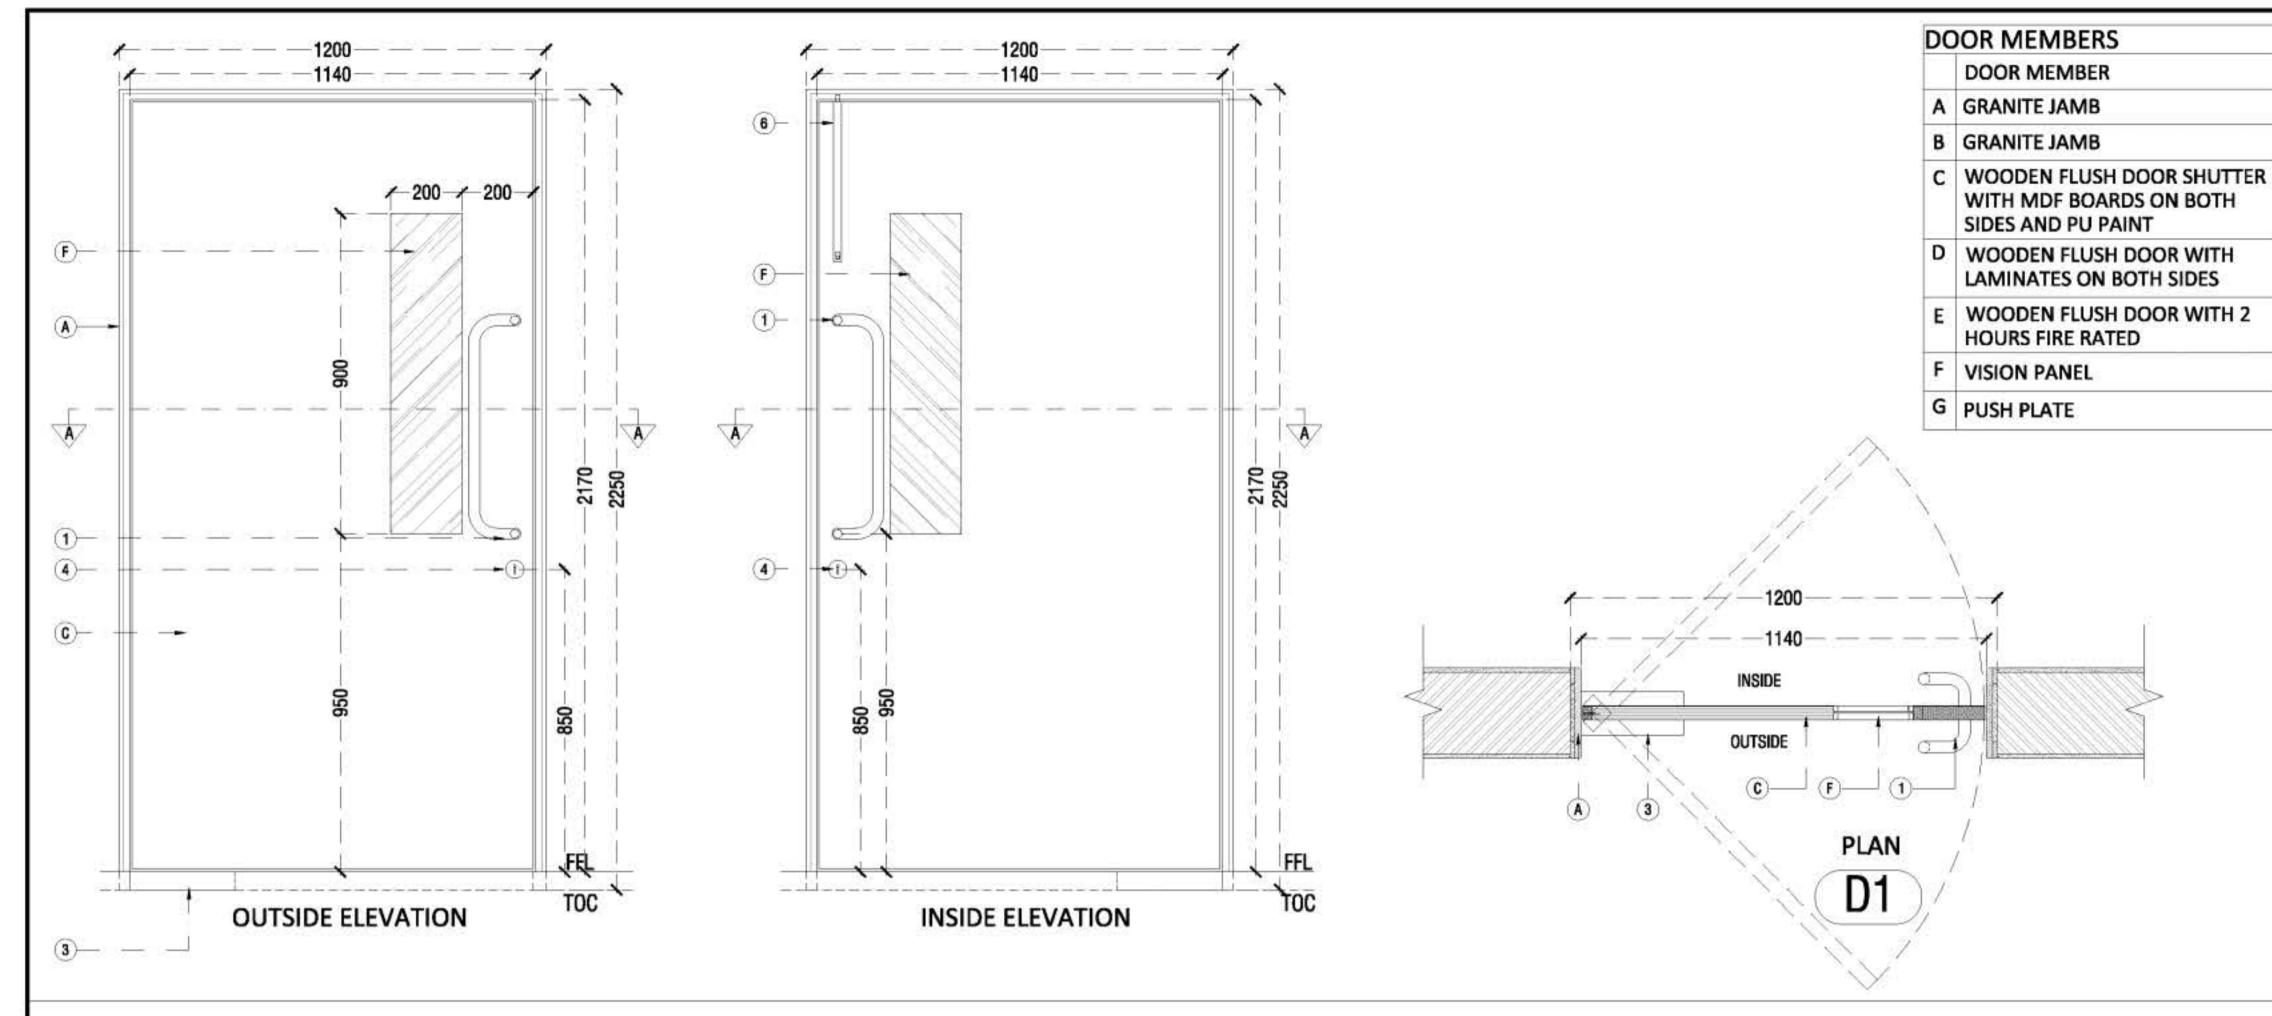

	HARDWARE ITEM	DESCRIPTION
1	SS PULL HANDLE-600MM	ROD DIA - 32 MM, HEIGHT-600
2	SS PULL HANDLE-300MM	ROD DIA - 25 MM, HEIGHT-300
3	FLOOR SPRING	
4	MORTISE DEAD LOCK SET	BOTH SIDE KEYS
5	PANIC BAR	
6	TOWER BOLT	450MM
7	TOWER BOLT	150MM
8	DOOR STOPPER	WALL MOUNTED

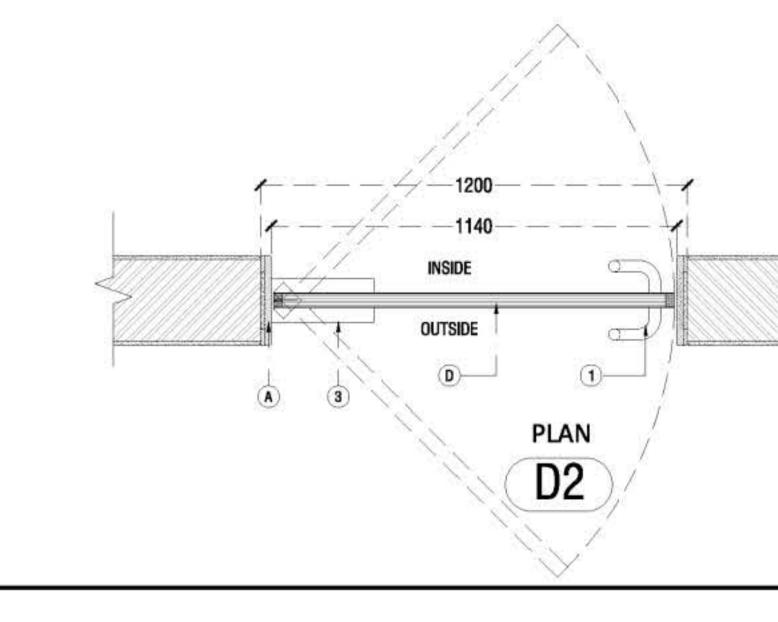


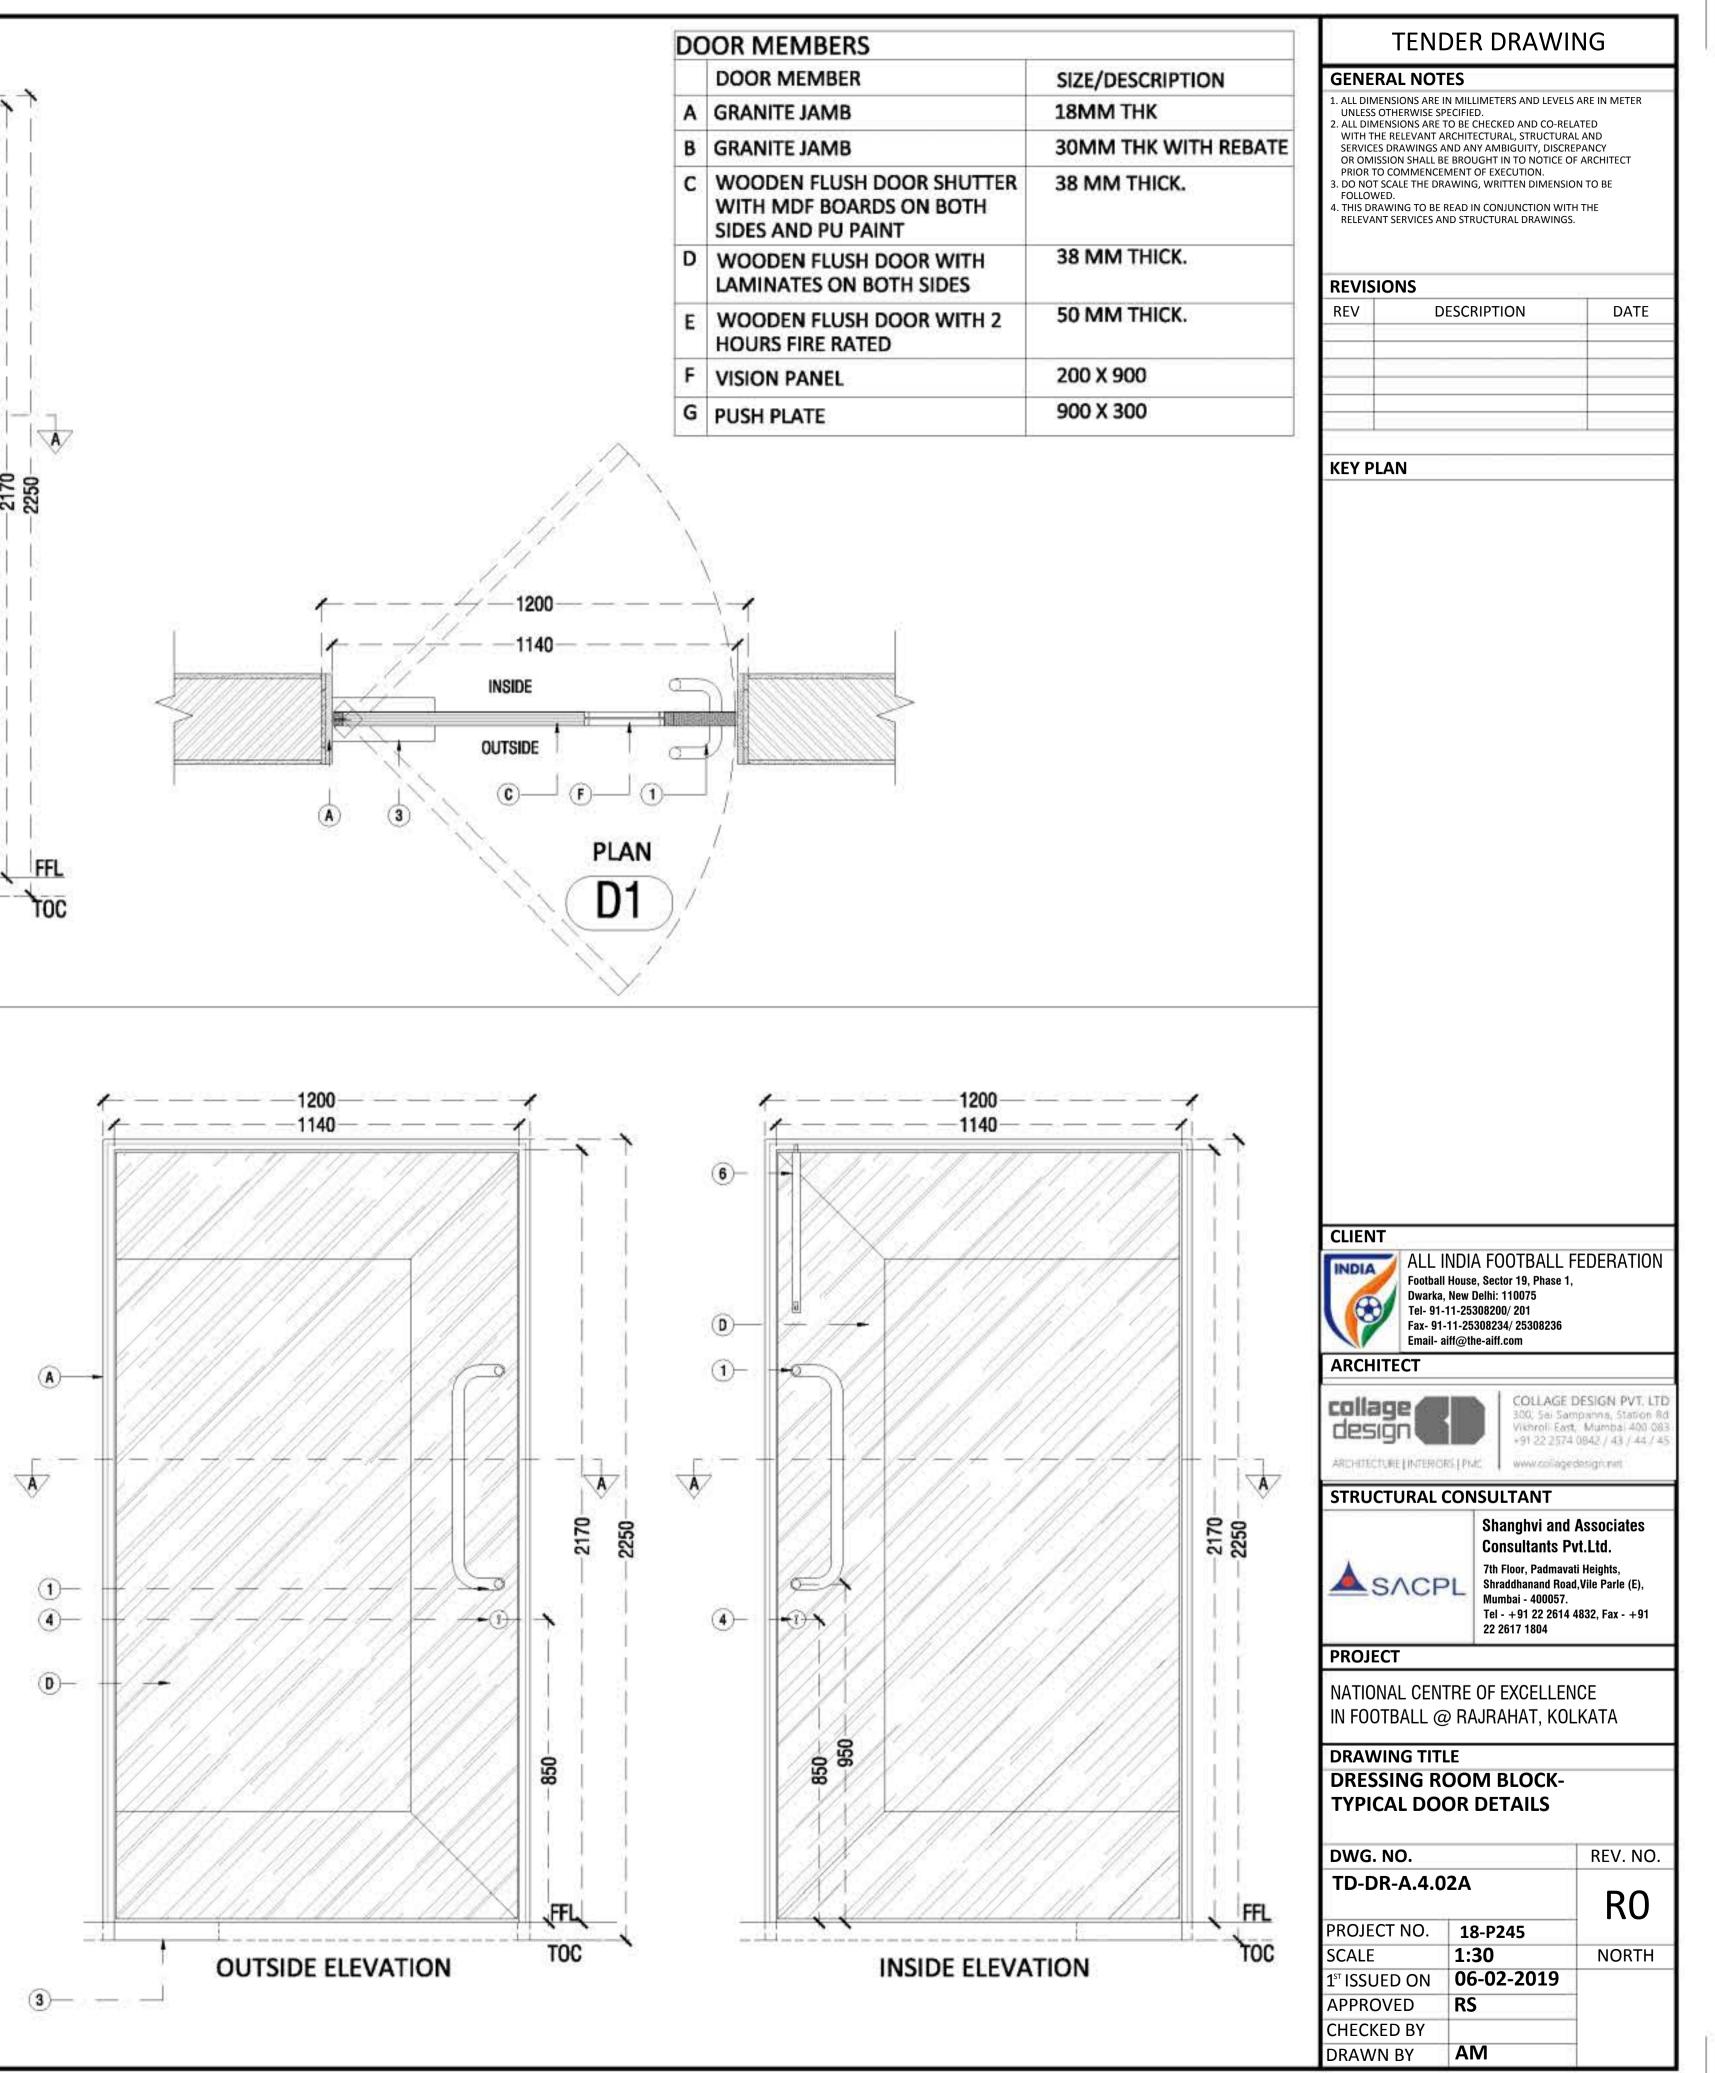


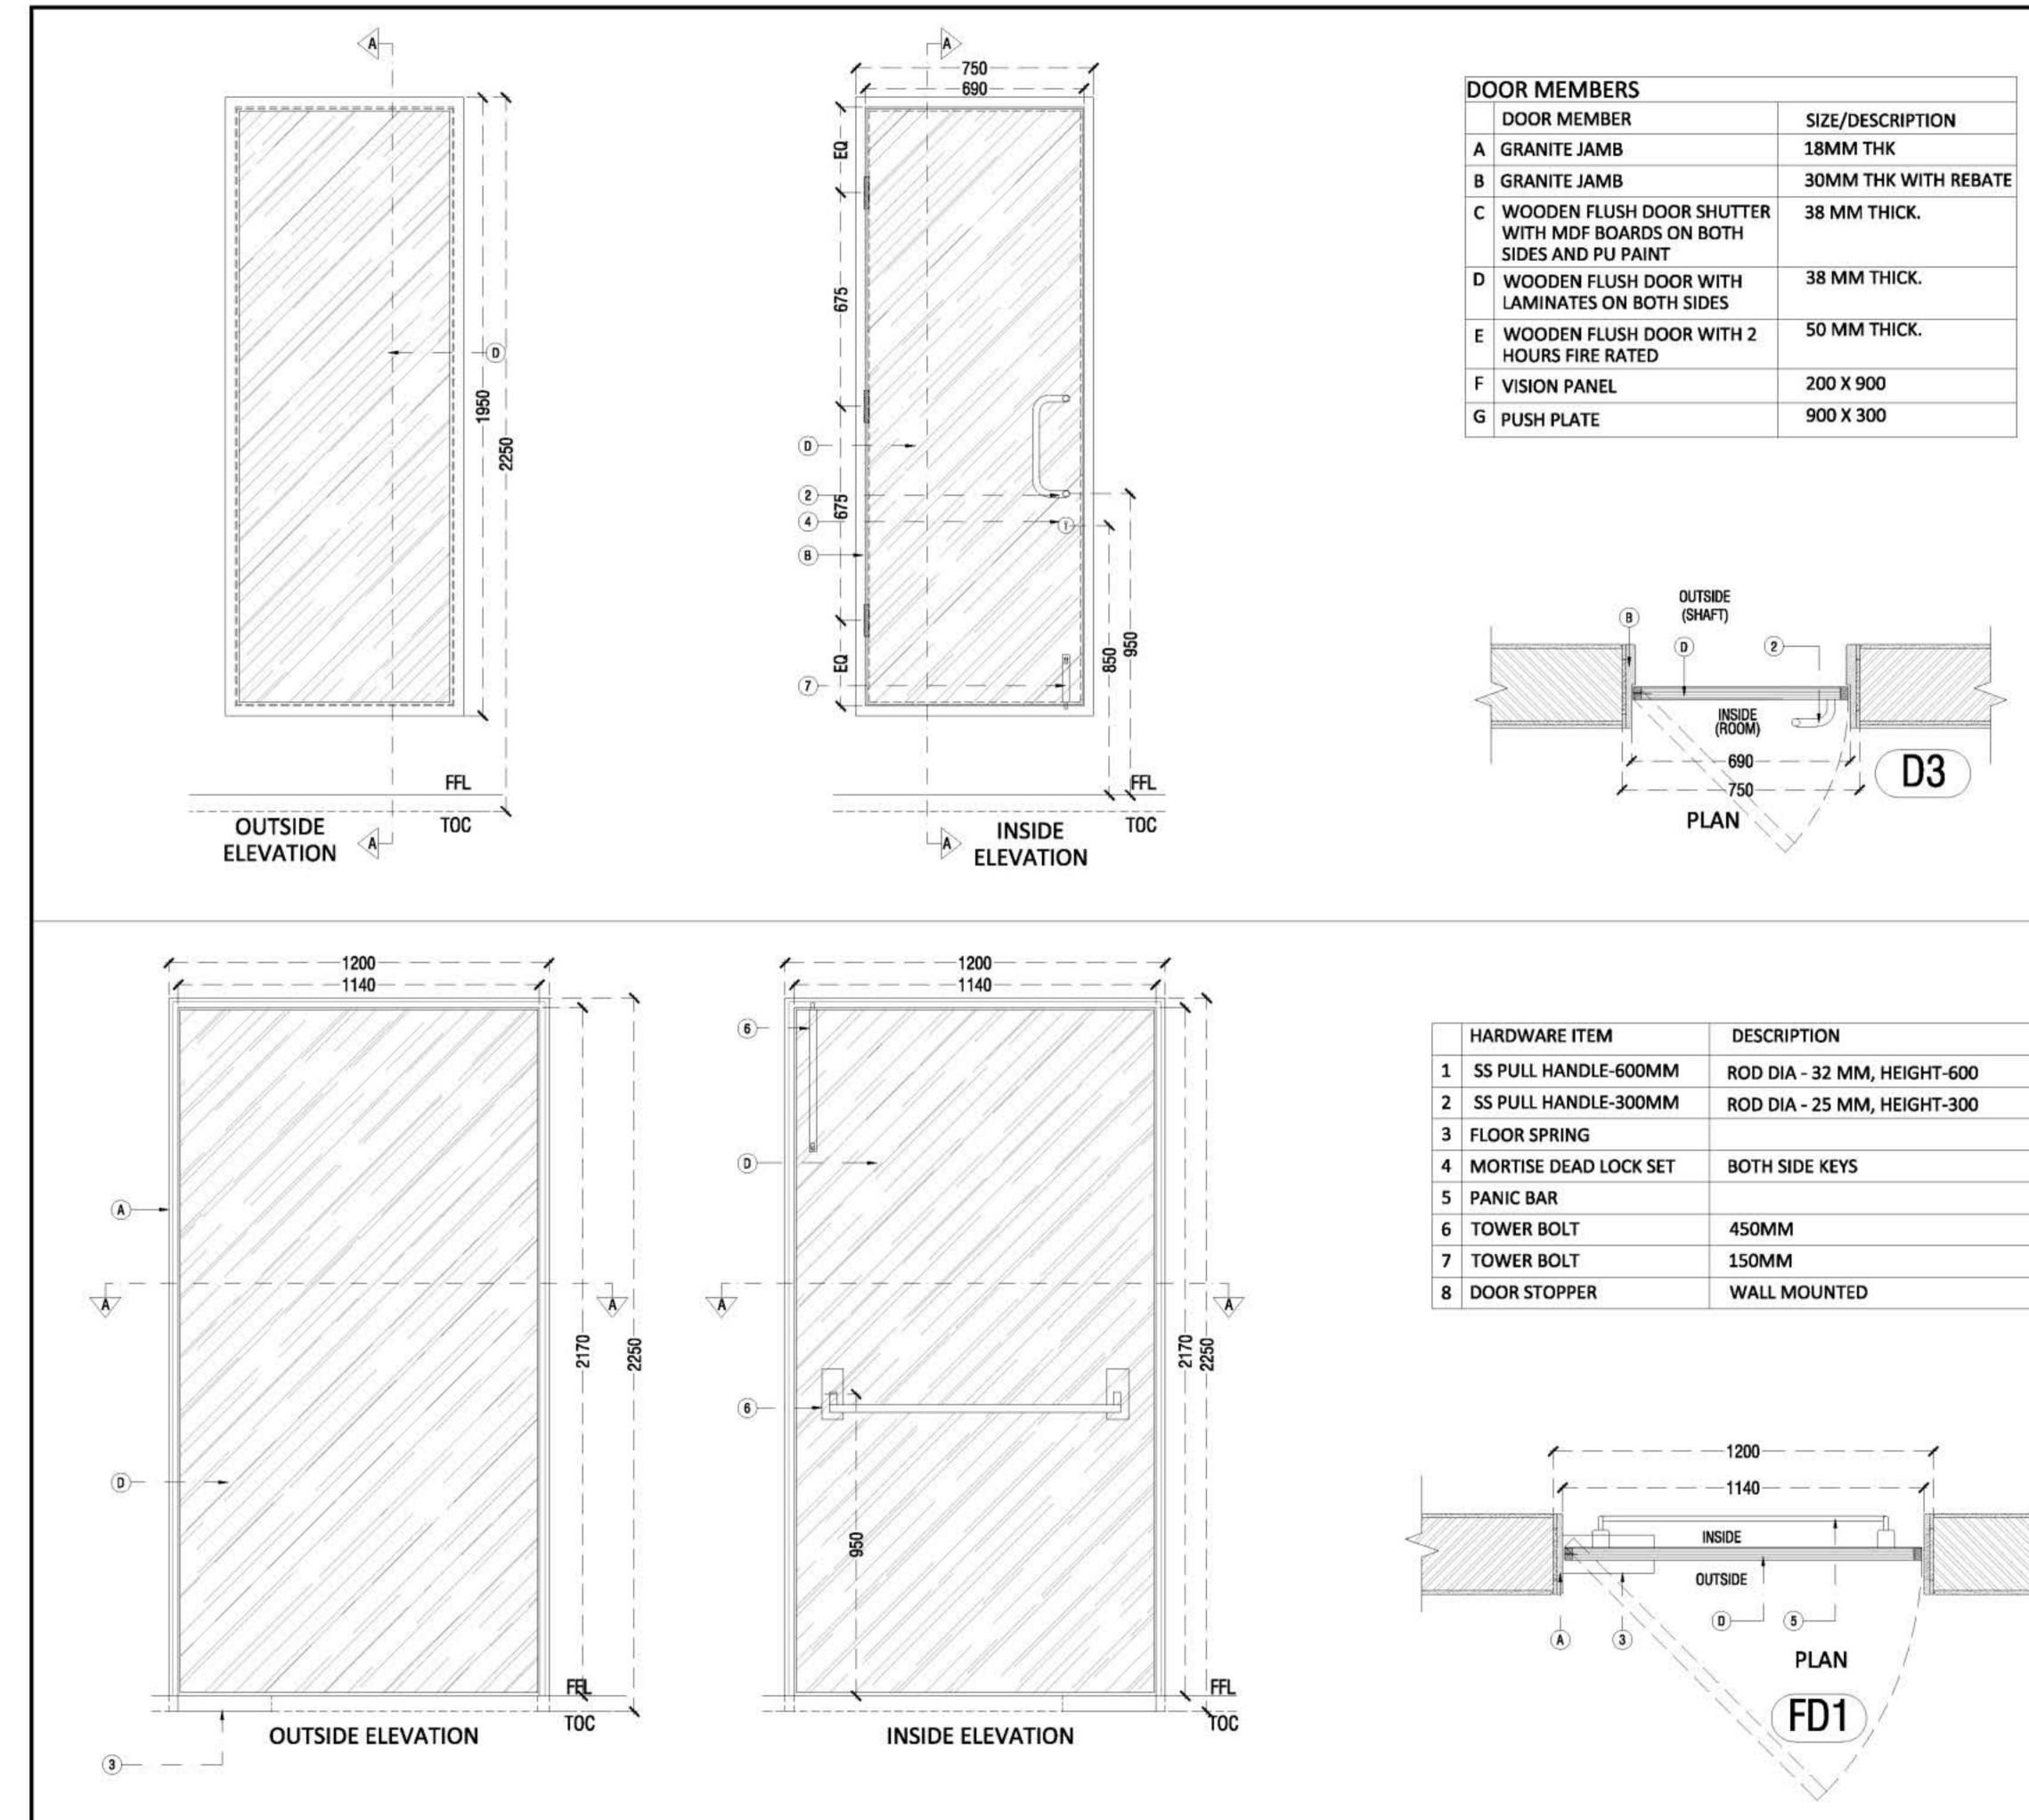



ĺ	HARDWARE ITEM	DESCRIPTION
1	SS PULL HANDLE-600MM	ROD DIA - 32 MM, HEIGHT-600
2	SS PULL HANDLE-300MM	ROD DIA - 25 MM, HEIGHT-300
3	FLOOR SPRING	
4	MORTISE DEAD LOCK SET	BOTH SIDE KEYS
5	PANIC BAR	
6	TOWER BOLT	450MM
7	TOWER BOLT	150MM
8	DOOR STOPPER	WALL MOUNTED

	TEND	DEF	R DRAWI	NG
GENER	AL NOT	ES		
UNLESS C 2. ALL DIME WITH THE SERVICES OR OMISS PRIOR TO 3. DO NOT S FOLLOWE	THERWISE SP NSIONS ARE T E RELEVANT A DRAWINGS A SION SHALL BE COMMENCER GCALE THE DR/ ED.	ECIFIEL TO BE C RCHITE ND AN E BROU MENT C AWING	CHECKED AND CO-RE ECTURAL, STRUCTURA IY AMBIGUITY, DISCR JGHT IN TO NOTICE C OF EXECUTION. G, WRITTEN DIMENSIO	LATED AL AND EPANCY DF ARCHITECT ON TO BE
			N CONJUNCTION WIT UCTURAL DRAWINGS	
REVISI REV		ESCR	RIPTION	DATE
				0
KEY PL	AN	_		
	ALL I Football Dwarka, Tel- 91- <sup>-</sup> Fax- 91-	House New D 11-253 11-253	A FOOTBALL 9, Sector 19, Phase 1 10elhi: 110075 108200/ 201 308234/ 25308236 e-aiff.com	FEDERATION
-	ALL I Football Dwarka, Tel- 91- Fax- 91- Email- a	House New D 11-253 11-253	e, Sector 19, Phase 1 Delhi: 110075 808200/ 201 308234/ 25308236	
ARCHI desi	ALL I Football Dwarka, Tel- 91- Fax- 91- Email- a	House New D 11-253 11-253 iff@th	e, Sector 19, Phase 1 Delhi: 110075 808200/ 201 808234/ 25308236 e-aiff.com COLLAGE 300, Sei Sai Victoroli Eas -91 22 257-	DESIGN PVT. LTD mpanna, Station Rd t, Mumbal 400 083 1 0842 / 43 / 44 / 45
ARCHI Colla desi ARCHIECT	ALL I Football Dwarka, Tel- 91- Fax- 91- Email- a TECT	House New D 11-253 11-253 iff@th	e, Sector 19, Phase 1 Delhi: 110075 808200/ 201 808234/ 25308236 e-aiff.com COLLAGE 300, Sei Sai Victoroli Eas -91 22 257-	DESIGN PVT. LTD mpsinna, Station Rd t, Mumbal 400 083 1 0842 / 43 / 44 / 45
ARCHI COLLAR CLESI ARCHITECT	ALL I Football Dwarka, Tel- 91- Fax- 91- Email- a TECT	House New D 11-253 11-253 iff@th	e, Sector 19, Phase 1 Delhi: 110075 808200/ 201 808234/ 25308236 e-aiff.com COLLAGE 300, 5ai 5ai Victoroli East +91 22 257- www.collage	, DESIGN PVT. LTD mpanna, Station Rd t, Mumbal 400 083 t 0942 / 43 / 44 / 45 rdsign nut Associates rvt.Ltd. ati Heights, d, Vile Parle (E),
ARCHI COLLAR CLESI ARCHITECT	ALL I Football Dwarka, Tel- 91-' Fax- 91- Email- a TECT	House New D 11-253 11-253 iff@th	Sector 19, Phase 1 pelhi: 110075 108200/ 201 1082034/ 25308236 e-aiff.com COLLAGE 100 Sai Sai 100 Sai	, DESIGN PVT. LTD mpanna, Station Rd t, Mumbal 400 083 t 0942 / 43 / 44 / 45 rdsign nut Associates rvt.Ltd. ati Heights, d, Vile Parle (E),
ARCHI ARCHI COLLAR STRUC STRUC PROJEC NATION IN FOOT	ALL I Football Dwarka, Tel- 91-' Fax- 91- Email- a TECT SFCC TURAL C SACP	House New D 11-253 11-253 iff@th CON	Sector 19, Phase 1 pelhi: 110075 108200/ 201 1082034/ 25308236 e-aiff.com COLLAGE 100 Sai Sai 100 Sai	, DESIGN PVT. LTD mpanna, Station Rd t. Mumbai 400 083 1 0842 / 43 / 44 / 45 rdsign rut Associates rvt.Ltd. ati Heights, id,Vile Parle (E), 4832, Fax - +91
ARCHI ARCHI COLLAR STRUC STRUC PROJEC NATION IN FOO DRAW DRESS	ALL I Football Dwarka, Tel- 91- Fax- 91- Email- a TECT SFCC TURAL C SACP CT IAL CENT IAL CENT IAL CENT IBALL @	House New D 11-253 11-253 iff@th/ CON CON	sector 19, Phase 1 pelhi: 110075 108200/ 201 108234/ 25308236 e-aiff.com COLLAGE 100 Set Sa Victorol Ear 102 257- 102	, DESIGN PVT. LTD mpanna, Station Rd t. Mumbai 400 083 1 0842 / 43 / 44 / 45 rdsign rut Associates rvt.Ltd. ati Heights, id,Vile Parle (E), 4832, Fax - +91
ARCHI ARCHI COLLAR STRUC STRUC PROJEC NATION IN FOO DRAW DRESS TYPIC DWG. I TD-DF	ALL I Football Dwarka, Tel- 91- Fax- 91- Email- a TECT SCC TURAL O SACP CT IAL CENT IBALL @ ING TITL SING RO AL DOO NO. R-A.4.0	House New D 11-253 11-253 iff@thi CON CON	Sector 19, Phase 1 Delhi: 110075 108200/ 201 308234/ 25308236 e-aiff.com COLLAGE 300 5a 5a Victorol Eas -91 22 257- WWW22549 SULTANT Shanghvi and Consultants P 7th Floor, Padmava Shraddhanand Roa Mumbai - 400057. Tel - +91 22 2614 22 2617 1804 OF EXCELLEN JRAHAT, KO	, DESIGN PVT. LTD mpanna, Station Rd t. Mumbai 400 083 1 0842 / 43 / 44 / 45 rdsign rut Associates rvt.Ltd. ati Heights, id,Vile Parle (E), 4832, Fax - +91
ARCHI ARCHI COLLAR STRUC STRUC NATION IN FOO DRAW DRESS TYPIC DWG. I TD-DF	ALL I Football Dwarka, Tel- 91- Fax- 91- Email- a TECT SCC TURAL O SACP CT IAL CENT IBALL @ ING TITL SING RO AL DOO NO. R-A.4.0	House New D 11-253 11-253 11-253 iff@th/ CON CON CON CON CON CON CON CON CON CON	sector 19, Phase 1 pelhi: 110075 po8200/ 201 308234/ 25308236 e-aiff.com COLLAGE 300 Set Sa Victoral Eas -91 22 257- WWY 2003 SULTANT Shanghvi and Consultants P 7th Floor, Padmava Shraddhanand Roa Mumbai - 400057. Tel - +91 22 2614 22 2617 1804 OF EXCELLEN JRAHAT, KO MBLOCK- DETAILS S-P245	, DESIGN PVT. LTD mpanna, Station 8d t, Mumbal 400 083 1 0842 / 43 / 44 / 45 rdetignmet Associates vt.Ltd. ati Heights, d,Vile Parle (E), 4832, Fax - +91 NCE LKATA REV. NO. RO.
ARCHI ARCHI COLLAR STRUC STRUC PROJEC NATION IN FOO DRAW DRESS TYPIC DWG. I TD-DF	ALL I Football Dwarka, Tel-91- Fax-91- Email- a TECT SING C AL CENT BALL @ ING TITL SING RO AL DOO NO. R-A.4.0	House New D 11-253 11-253 11-253 iff@thi CON CON CON CON CON CON CON CON CON CON	sector 19, Phase 1 pelhi: 110075 po8200/ 201 308234/ 25308236 e-aiff.com COLLAGE 300 Set Sa Victoral Eas -91 22 257- WWY 2003 SULTANT Shanghvi and Consultants P 7th Floor, Padmava Shraddhanand Roa Mumbai - 400057. Tel - +91 22 2614 22 2617 1804 OF EXCELLEN JRAHAT, KO MBLOCK- DETAILS S-P245	, DESIGN PVT. LTD mpanna, Station Rd t, Mumbal 400 083 1 0942 / 43 / 44 / 45 rdesignment Associates vt.Ltd. ati Heights, d,Vile Parle (E), 4832, Fax - +91 NCE LKATA REV. NO.
ARCHI ARCHI COLLAR STRUC STRUC PROJEC DRAW DRESS TYPIC DWG. I TD-DF PROJEC SCALE	ALL I Football Dwarka, Tel-91- Fax-91- Email- a TECT SING C INTRAL C ING TITL SING R AL DOC NO. R-A.4.0 T NO. R-A.4.0	House New D 11-253 11-253 11-253 iff@thi CON CON CON CON CON CON CON CON CON CON	sector 19, Phase 1 pelhi: 110075 po8200/ 201 308234/ 25308236 e-aiff.com COLLAGE 300, 5ei 5a victorol Eas -91 22 257 victorol Eas -91 22 2614 22 2617 1804 OF EXCELLEN A A B -02 -20 19	, DESIGN PVT. LTD mpanna, Station Rd t, Mumbal 400 083 1 0942 / 43 / 44 / 45 rdesignment Associates vt.Ltd. ati Heights, d,Vile Parle (E), 4832, Fax - +91 NCE LKATA REV. NO. REV. NO.

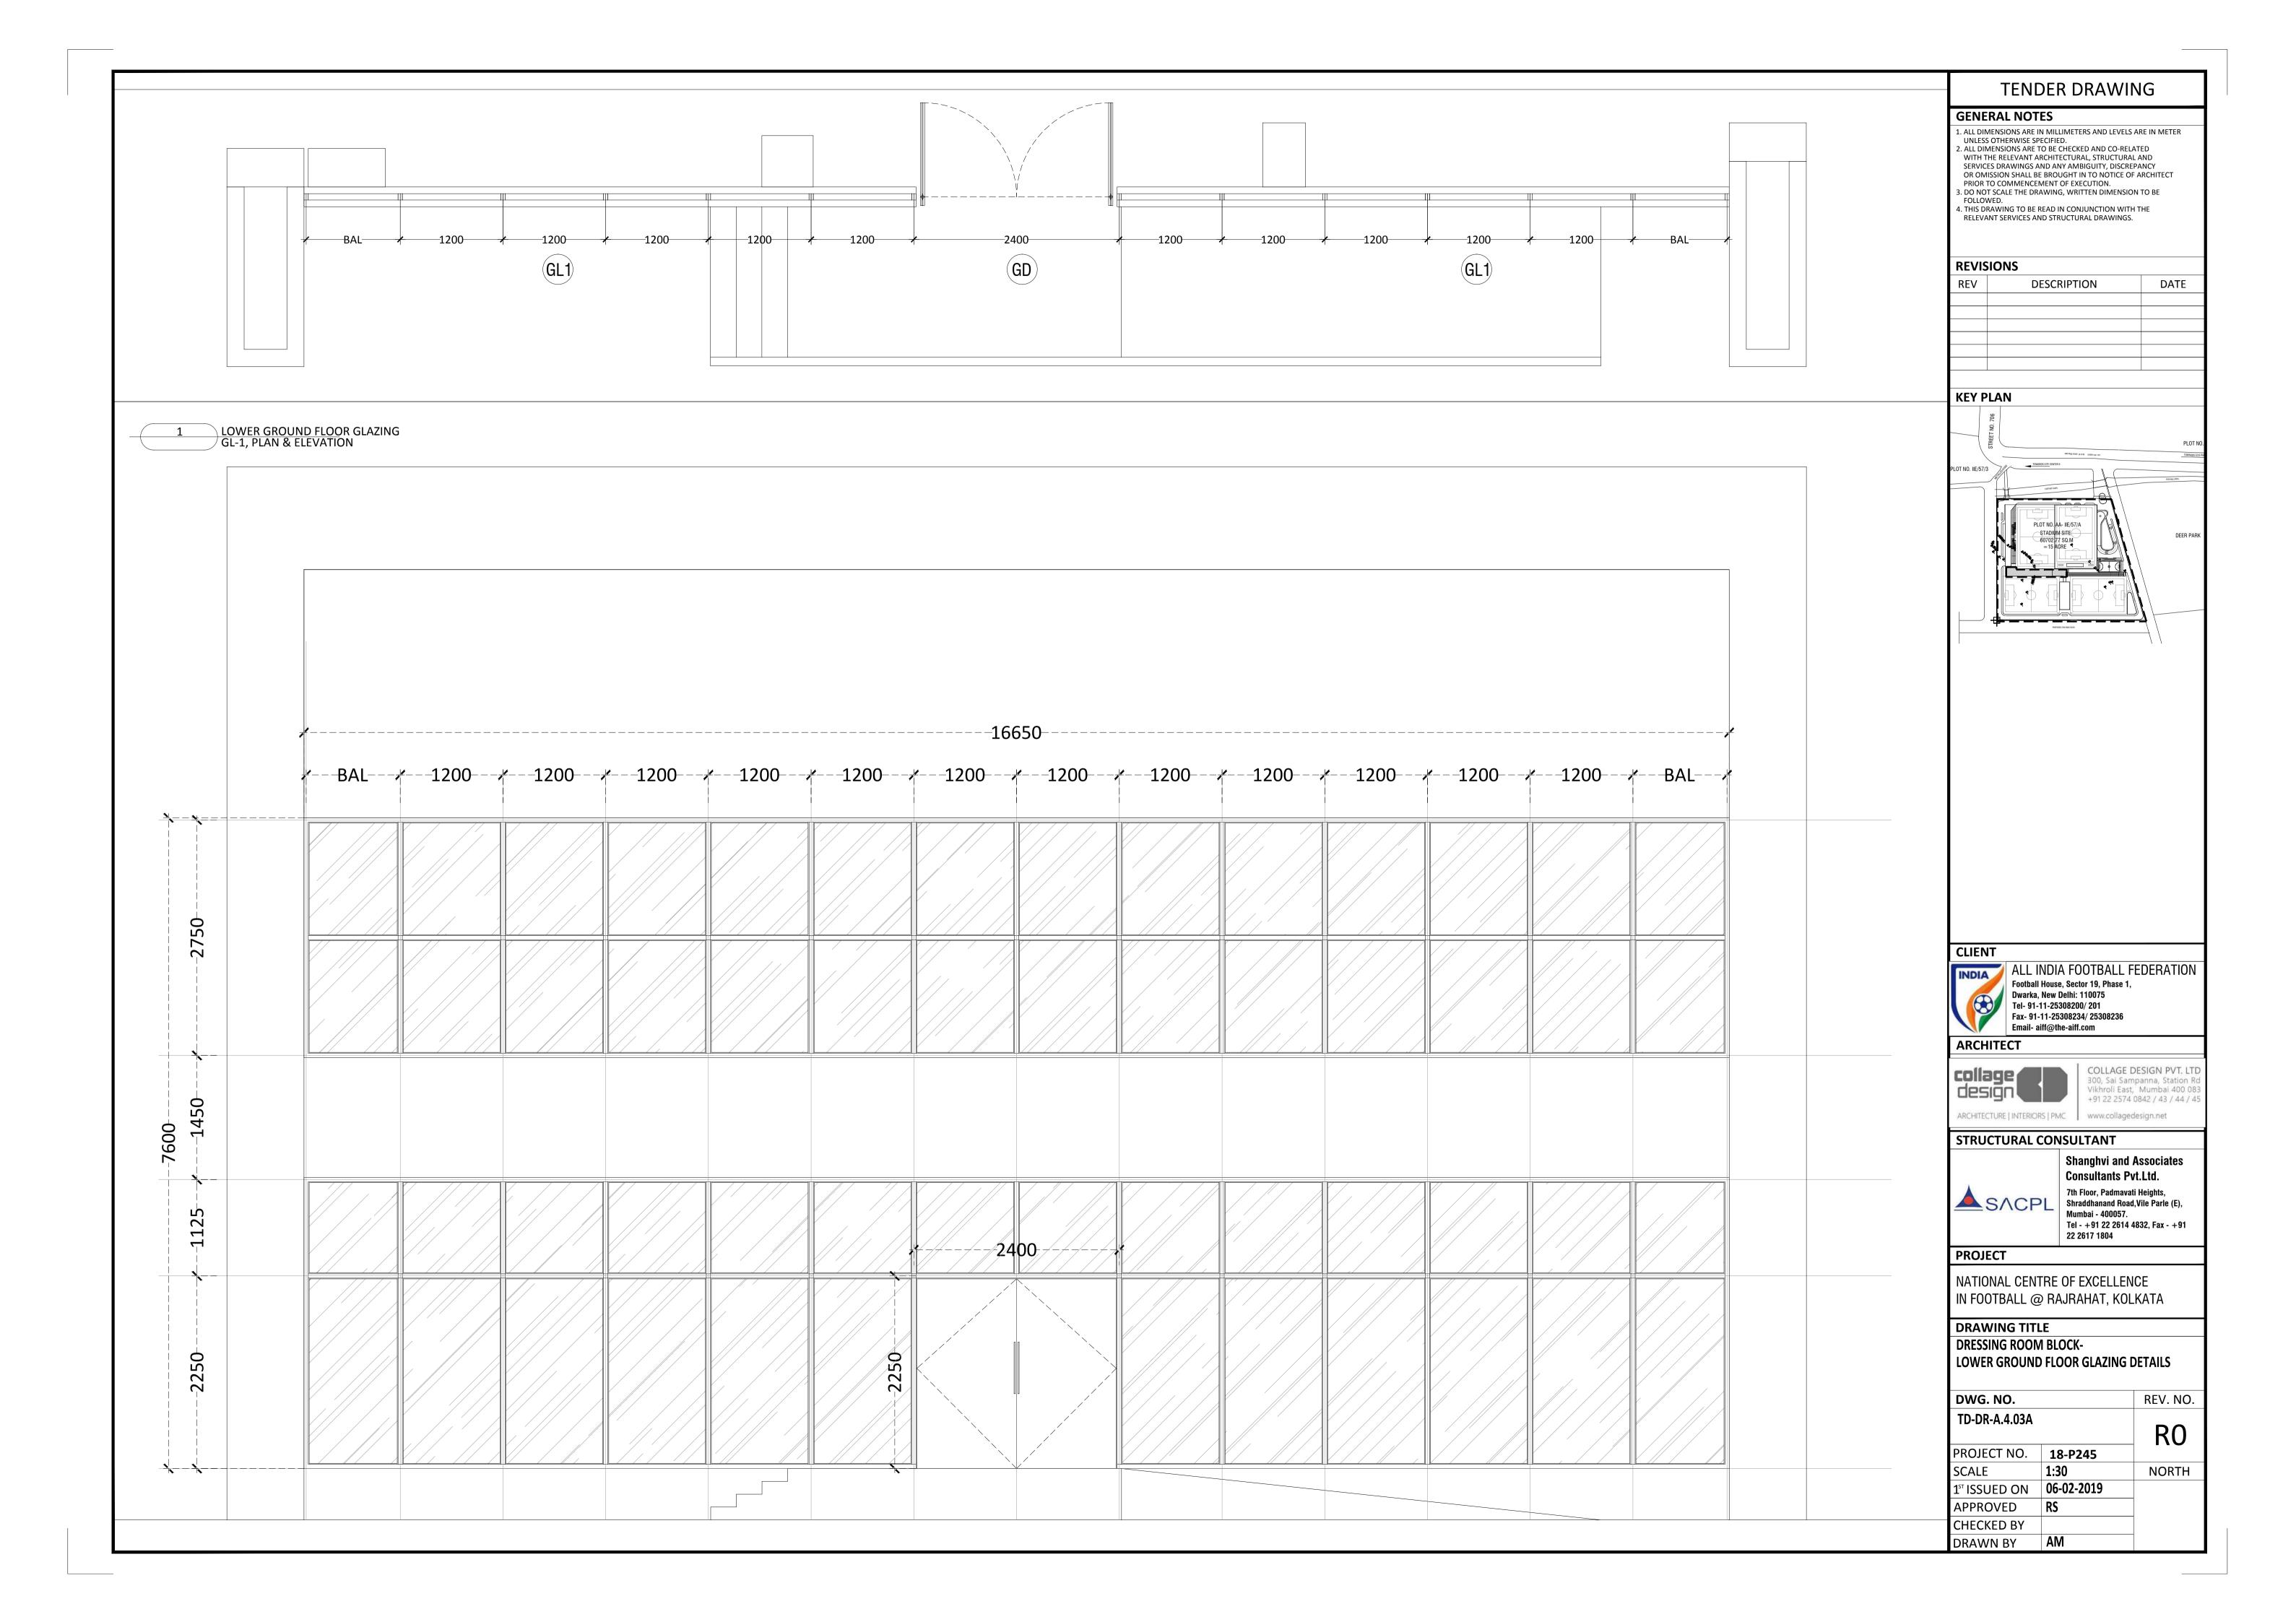


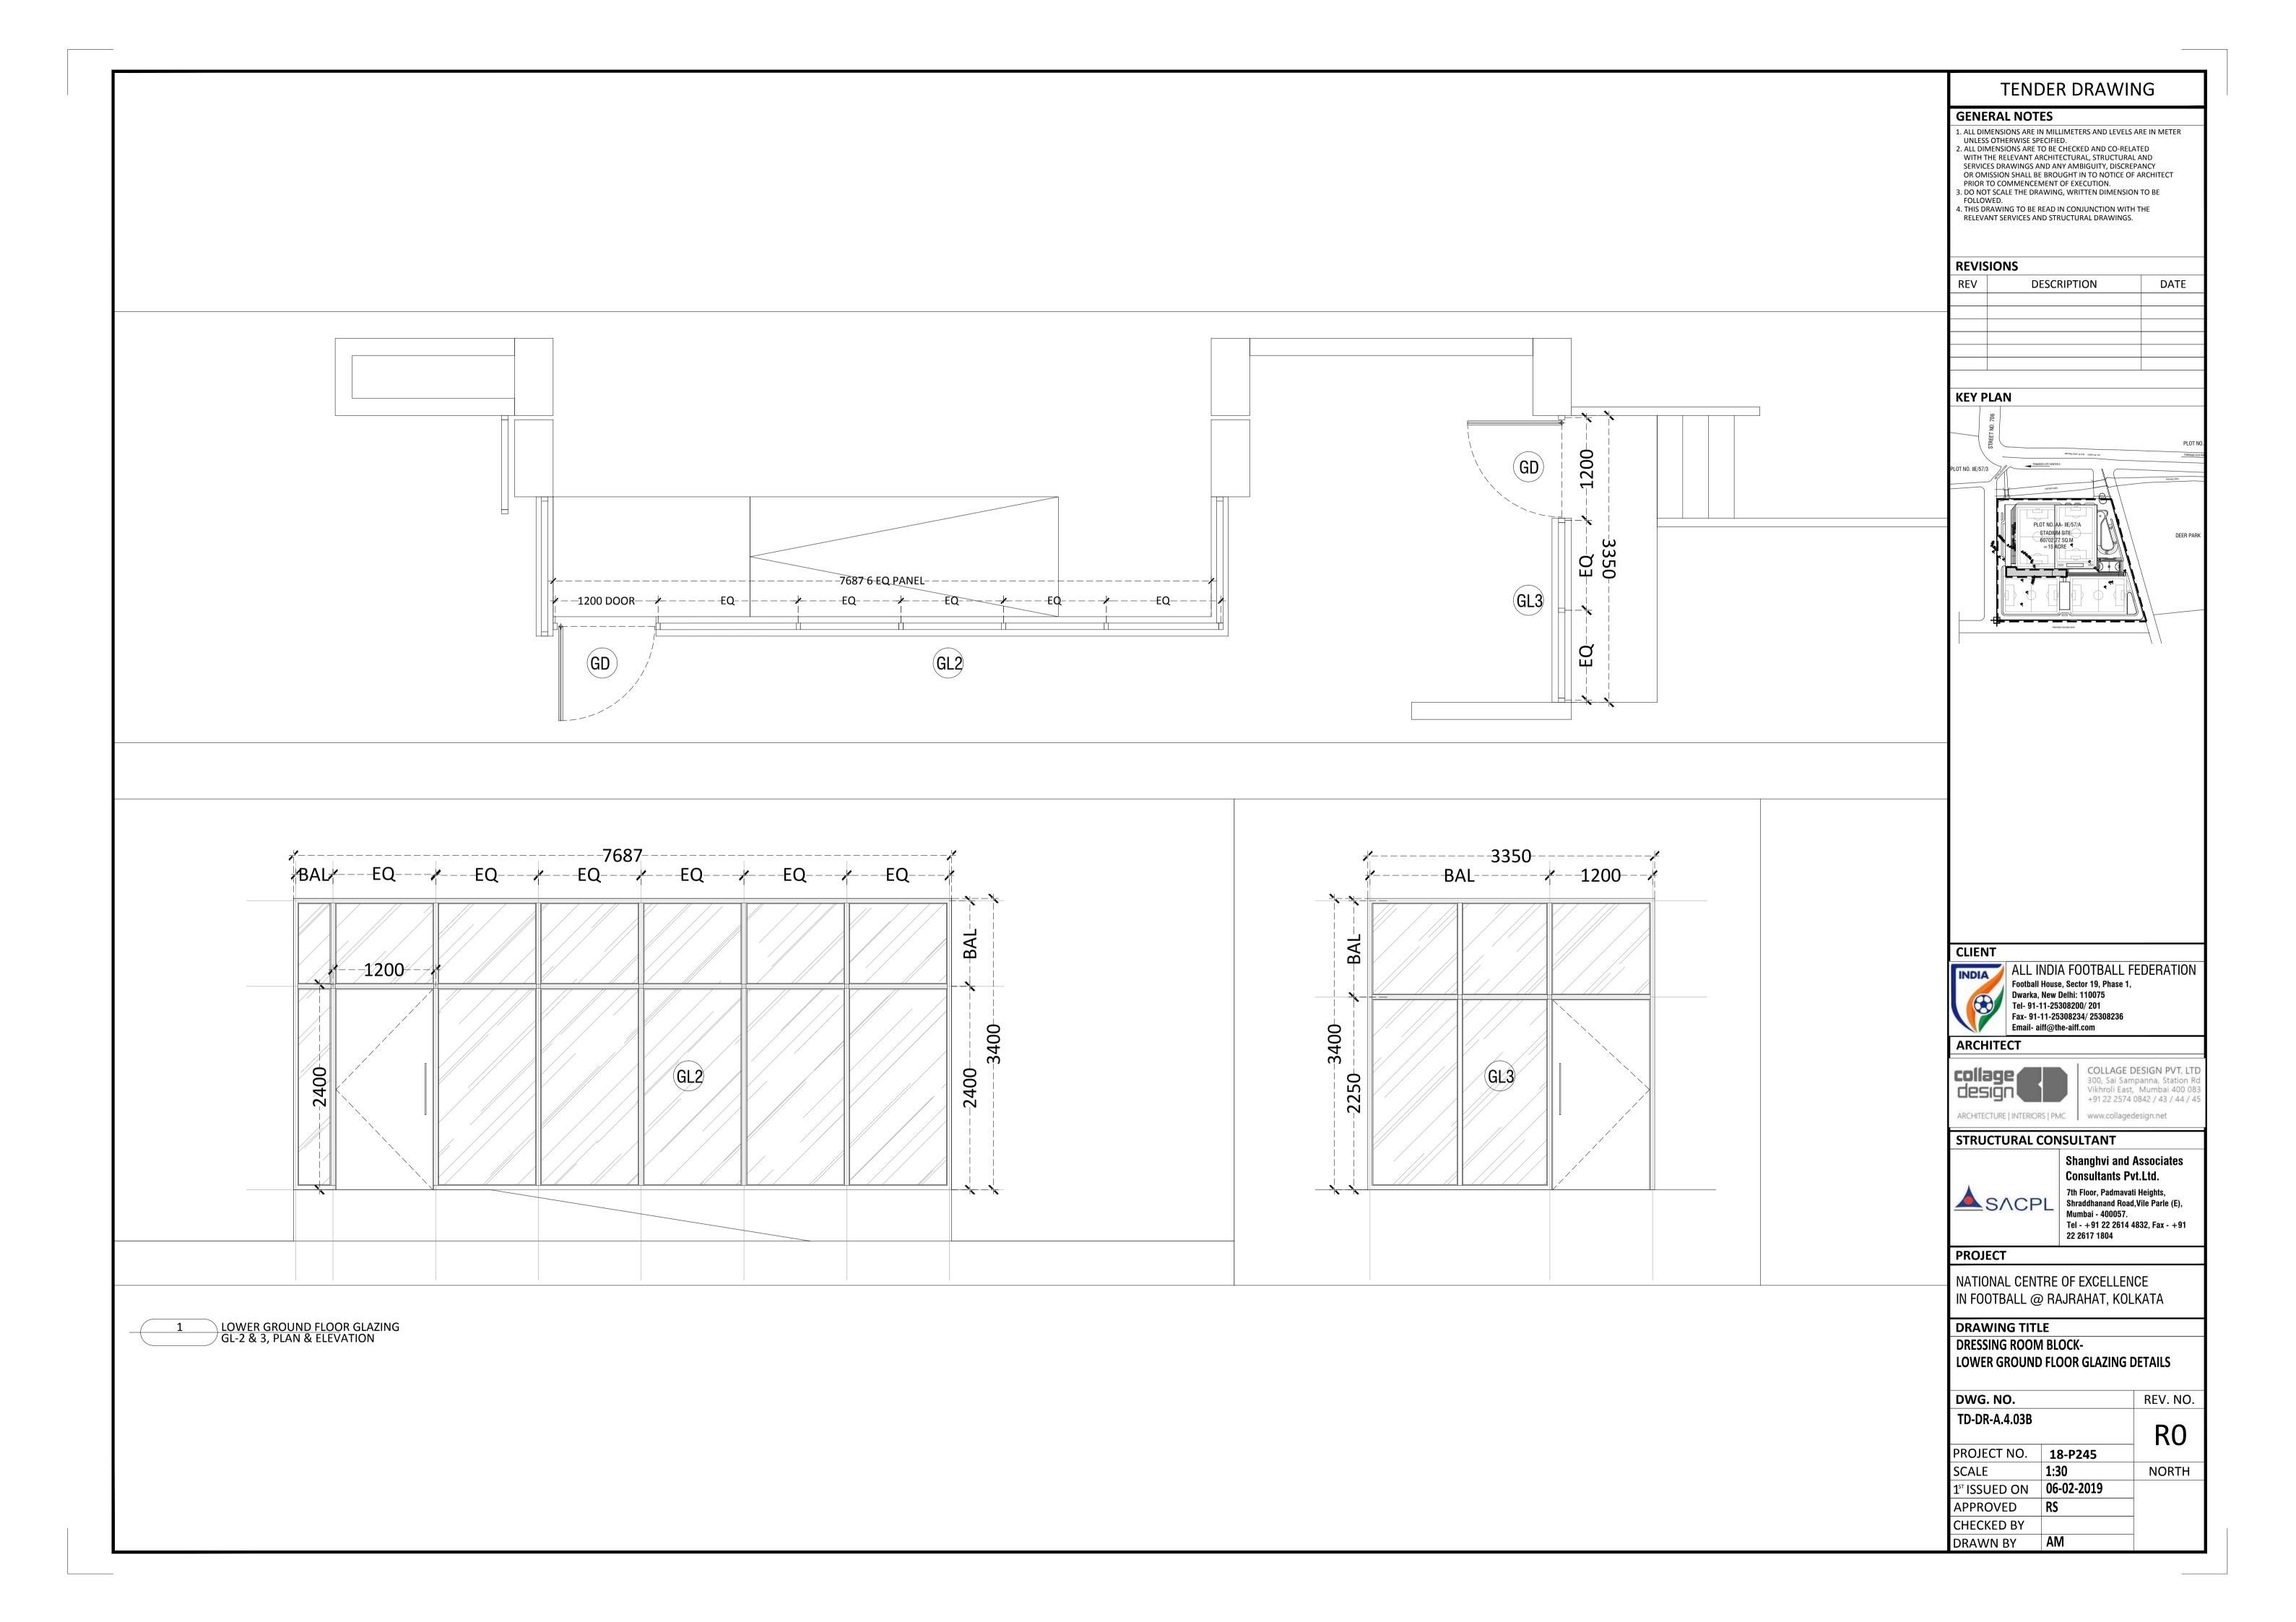


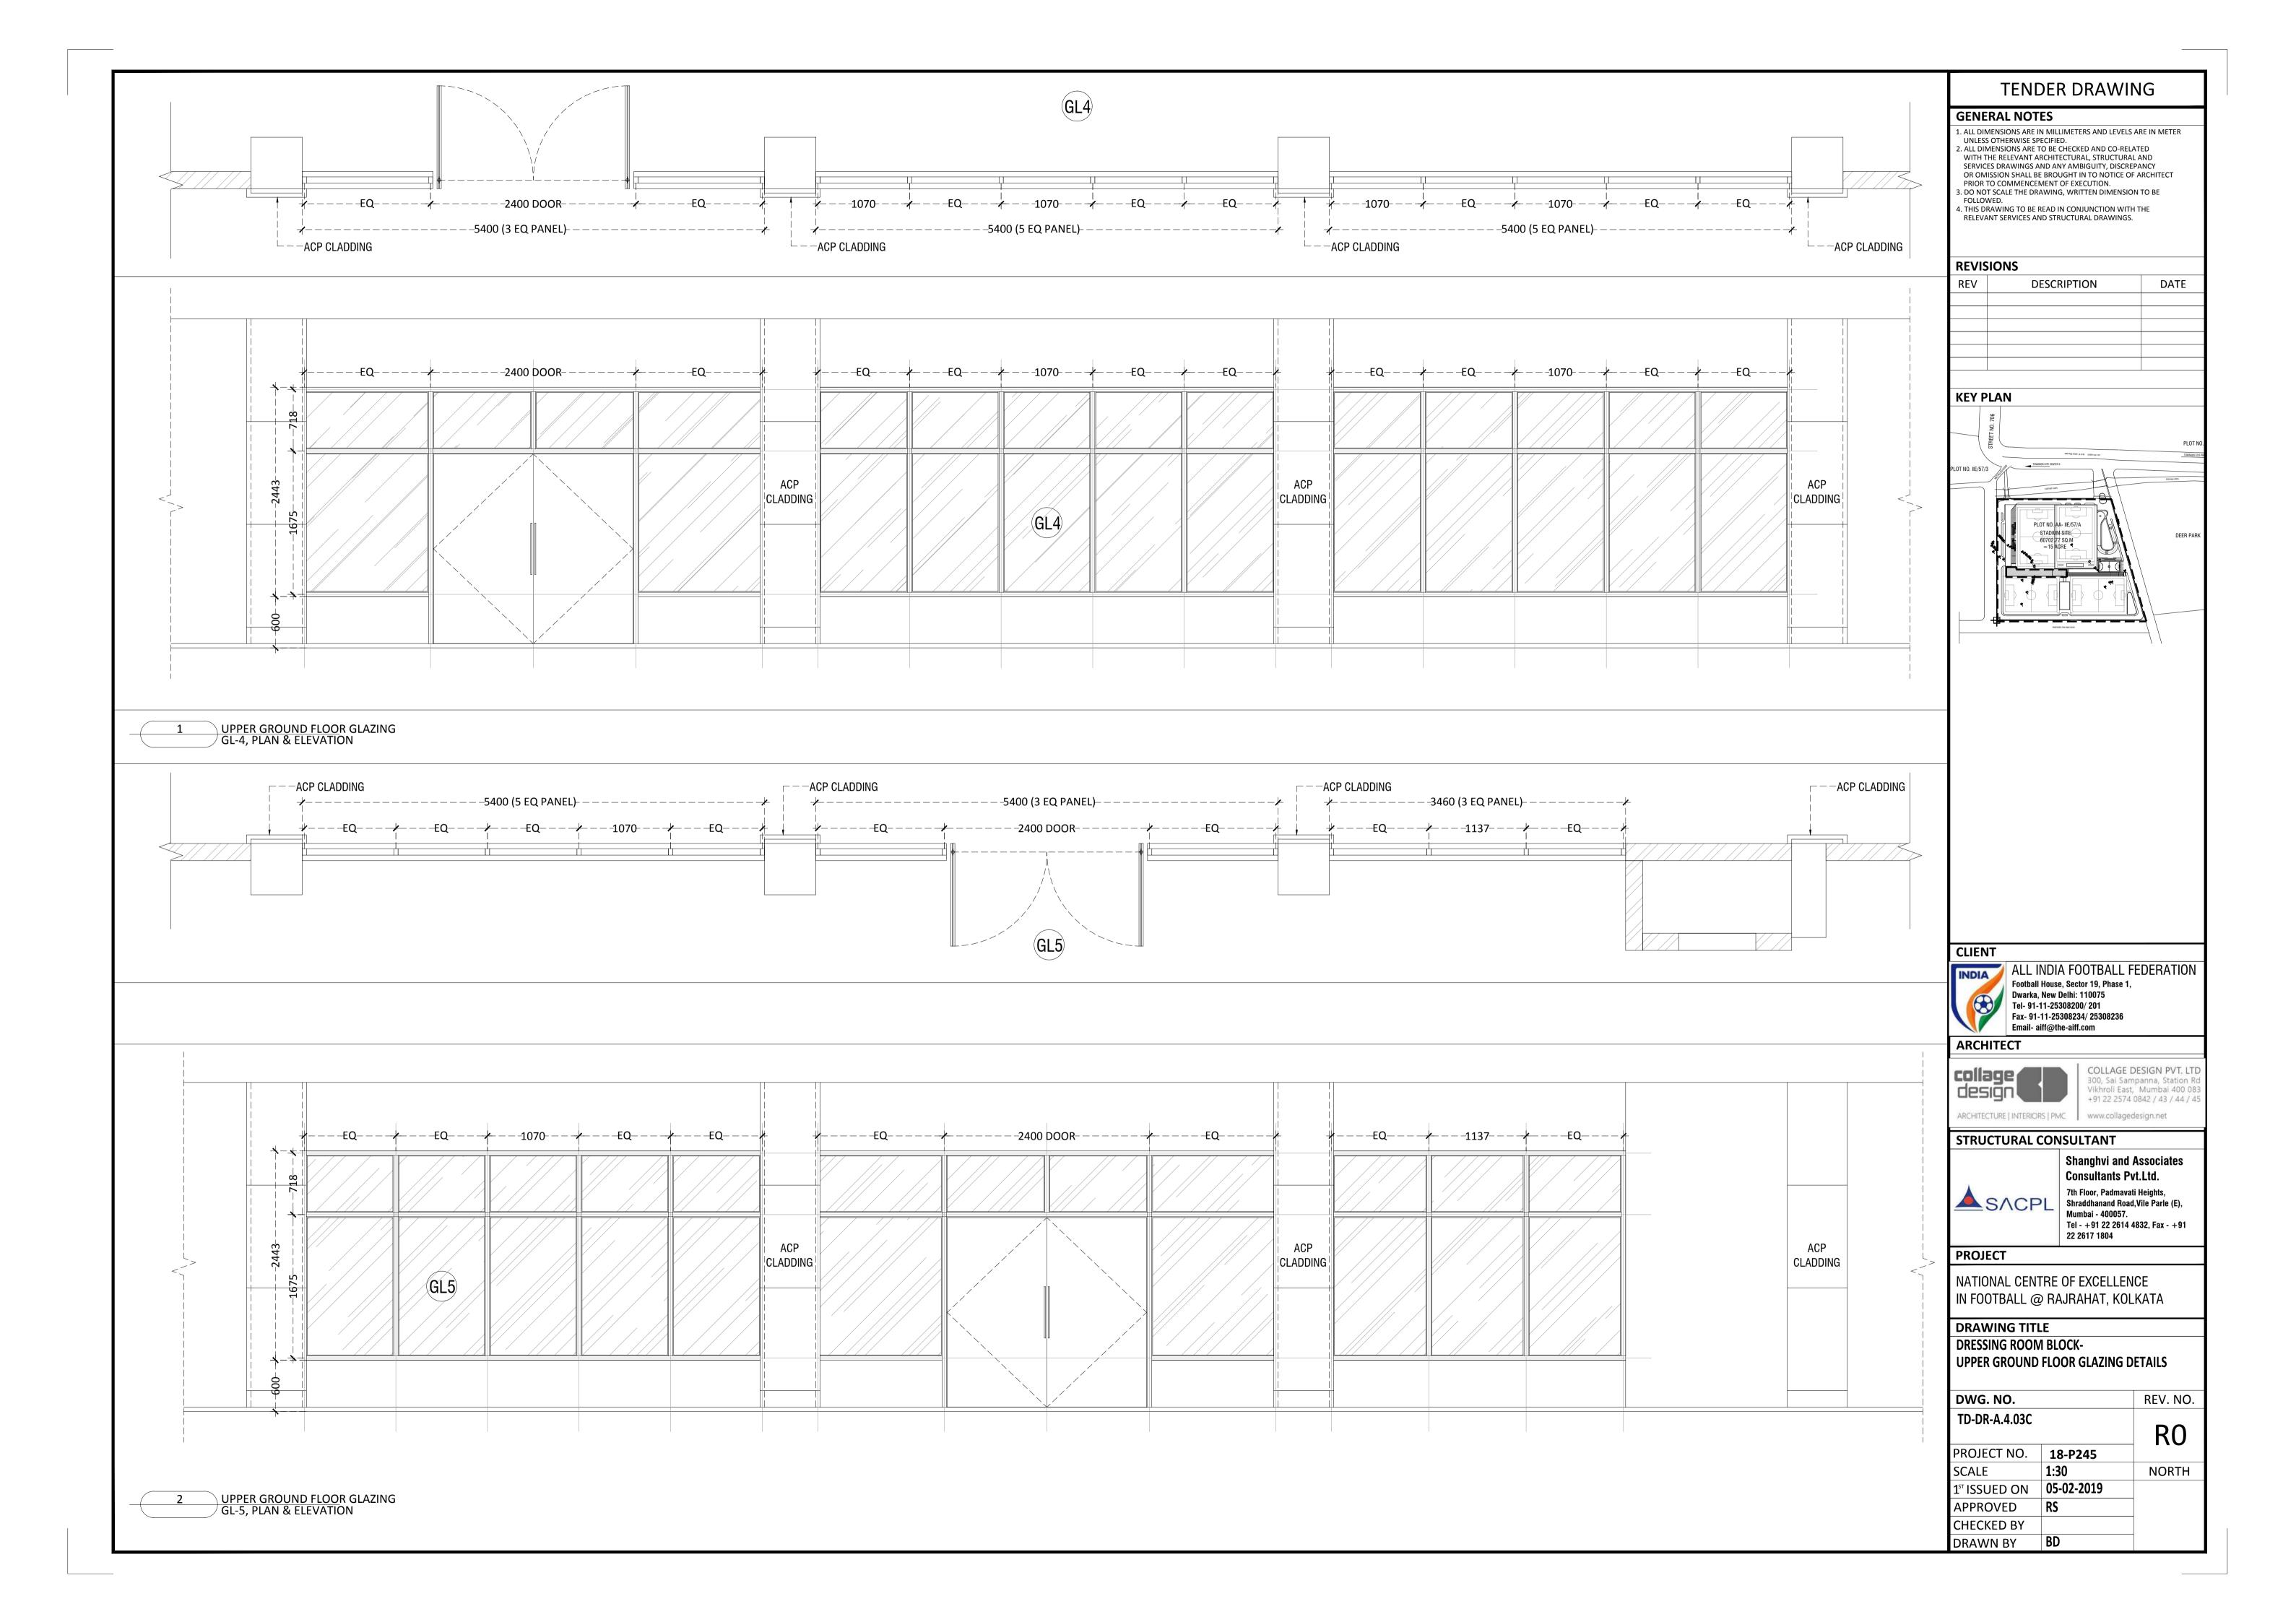


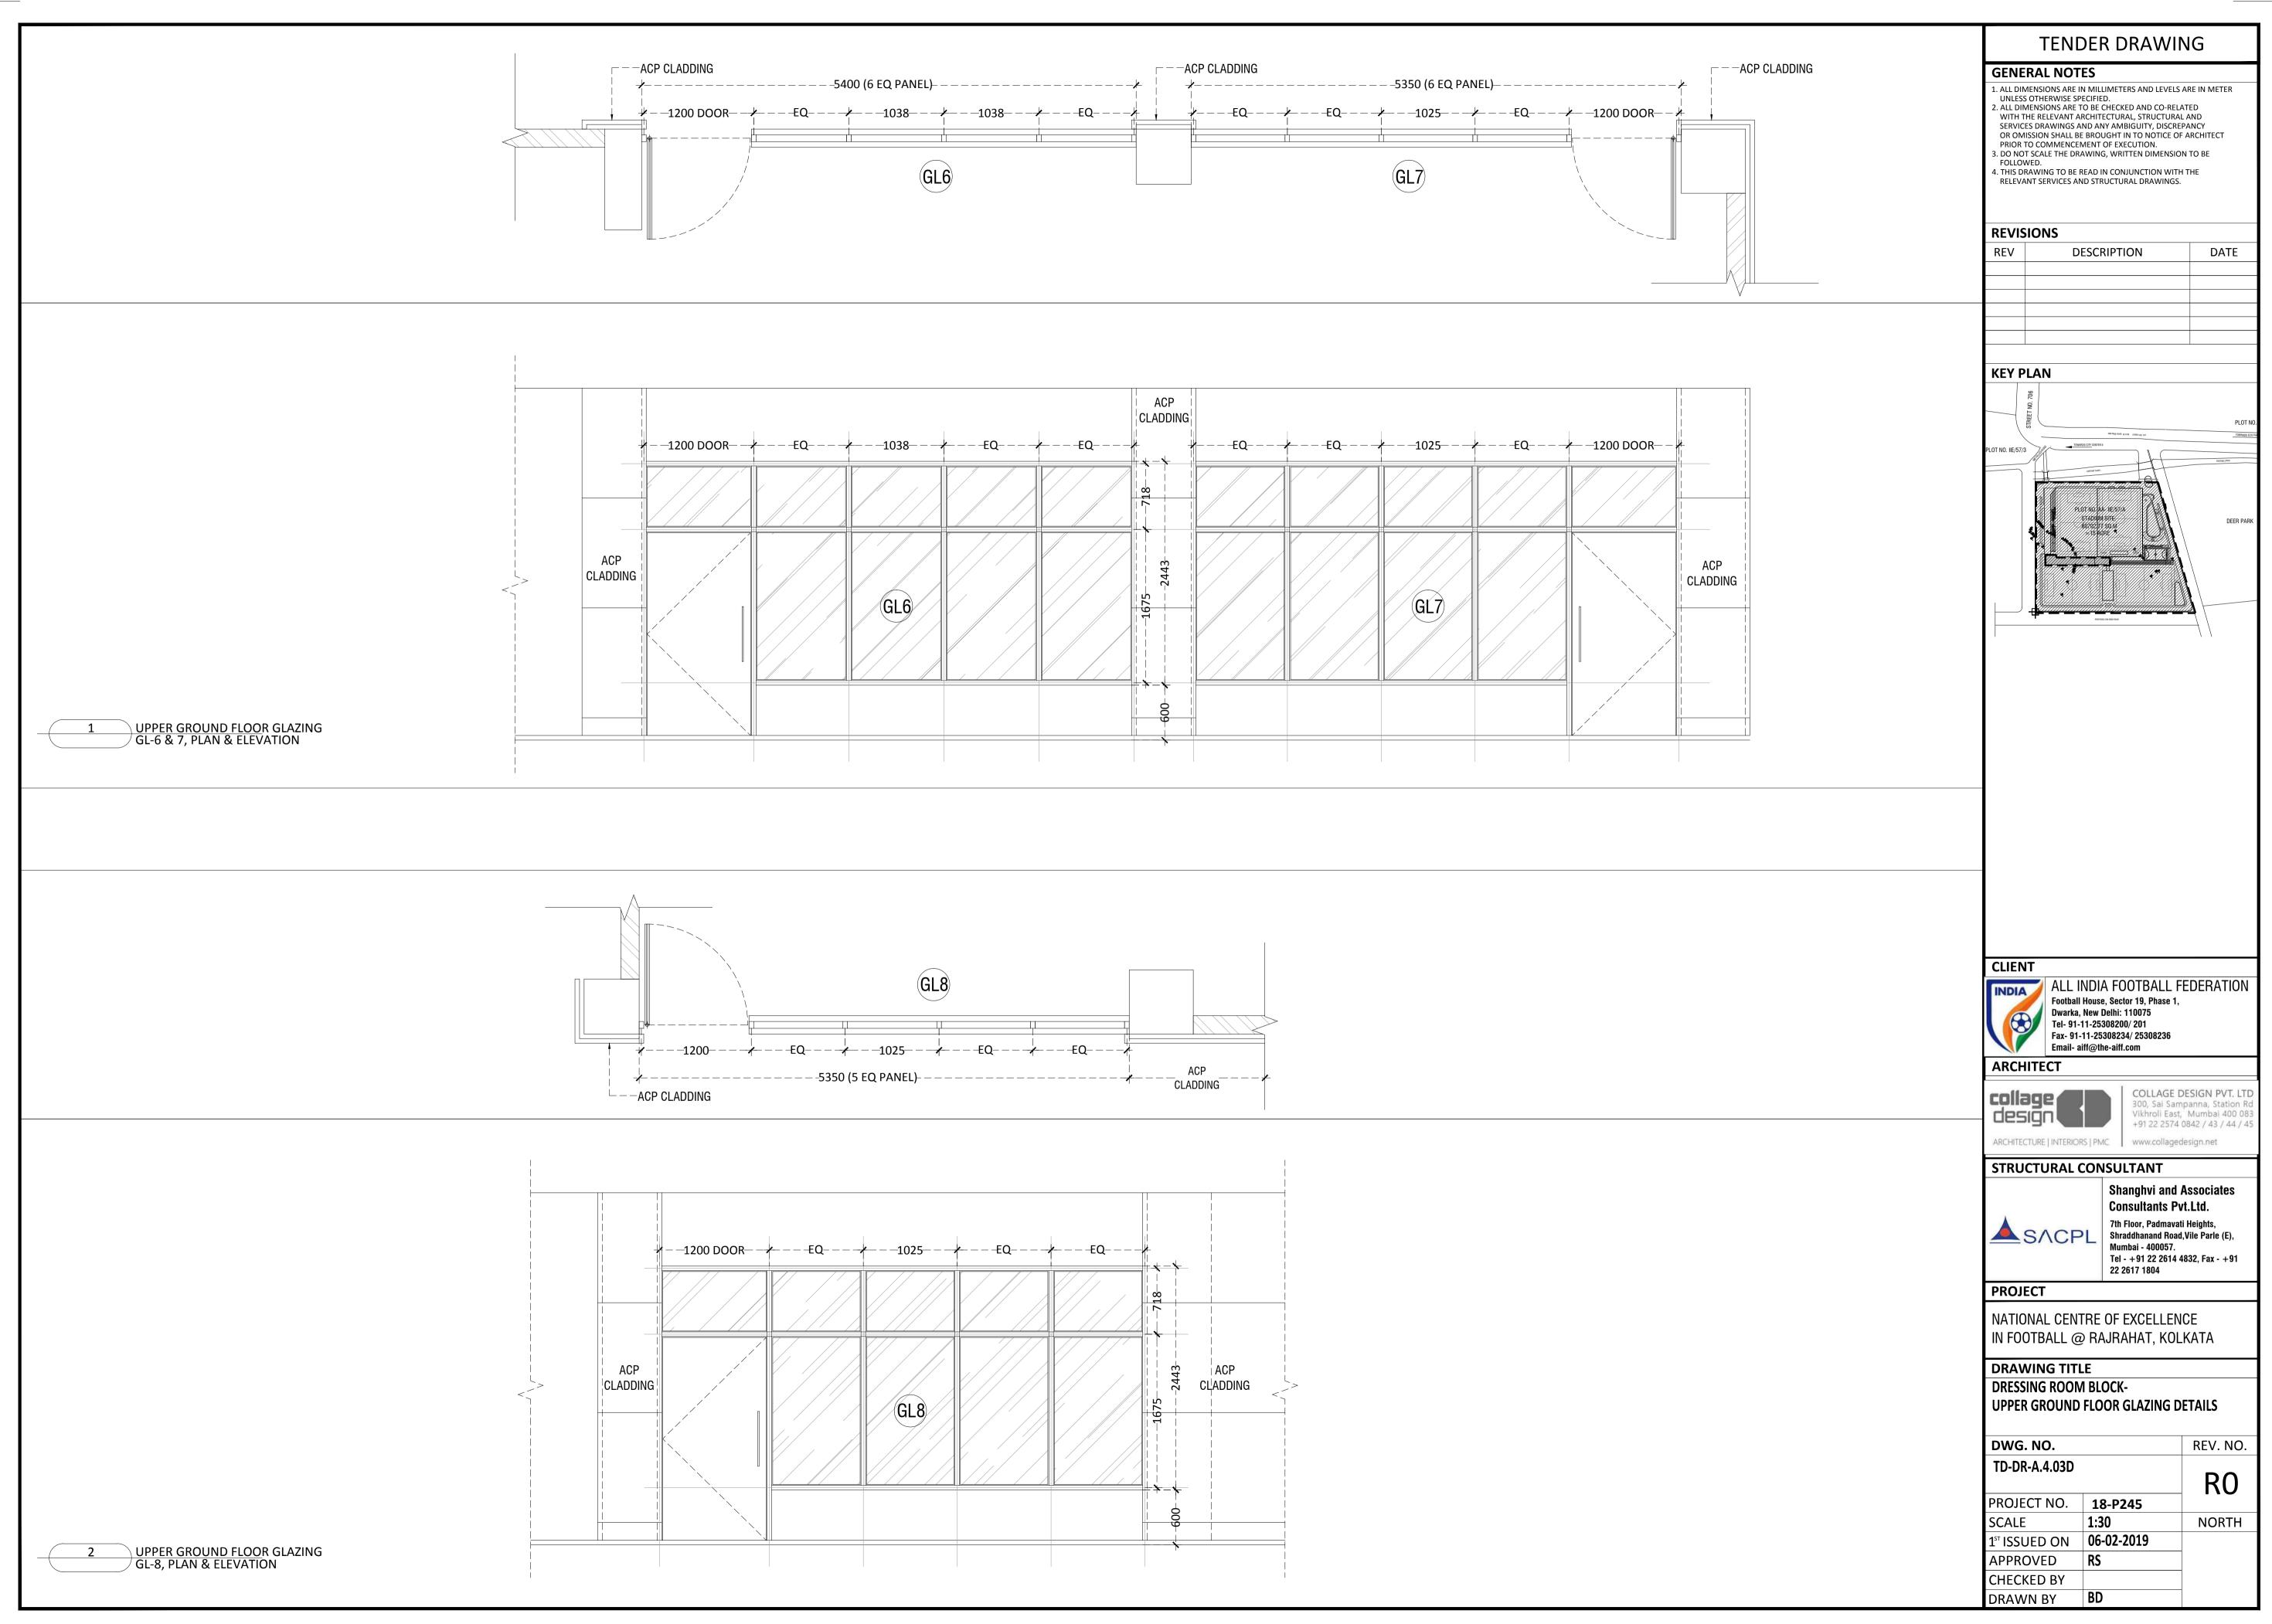


			ACP Cladding					
 <	←−−−EQ−−− <i>→</i>	←EQ	     <b>+</b> - <b>+</b>   	EQ	←−−−EQ−−− <i>→</i>	← — — — 1025— — — ← — — — EQ- — — —	≁——1200 DOOR——-	
GL6			·1675			GL7		ACP CLADDING
			+-+ 009	-				
			<b>`</b> \					

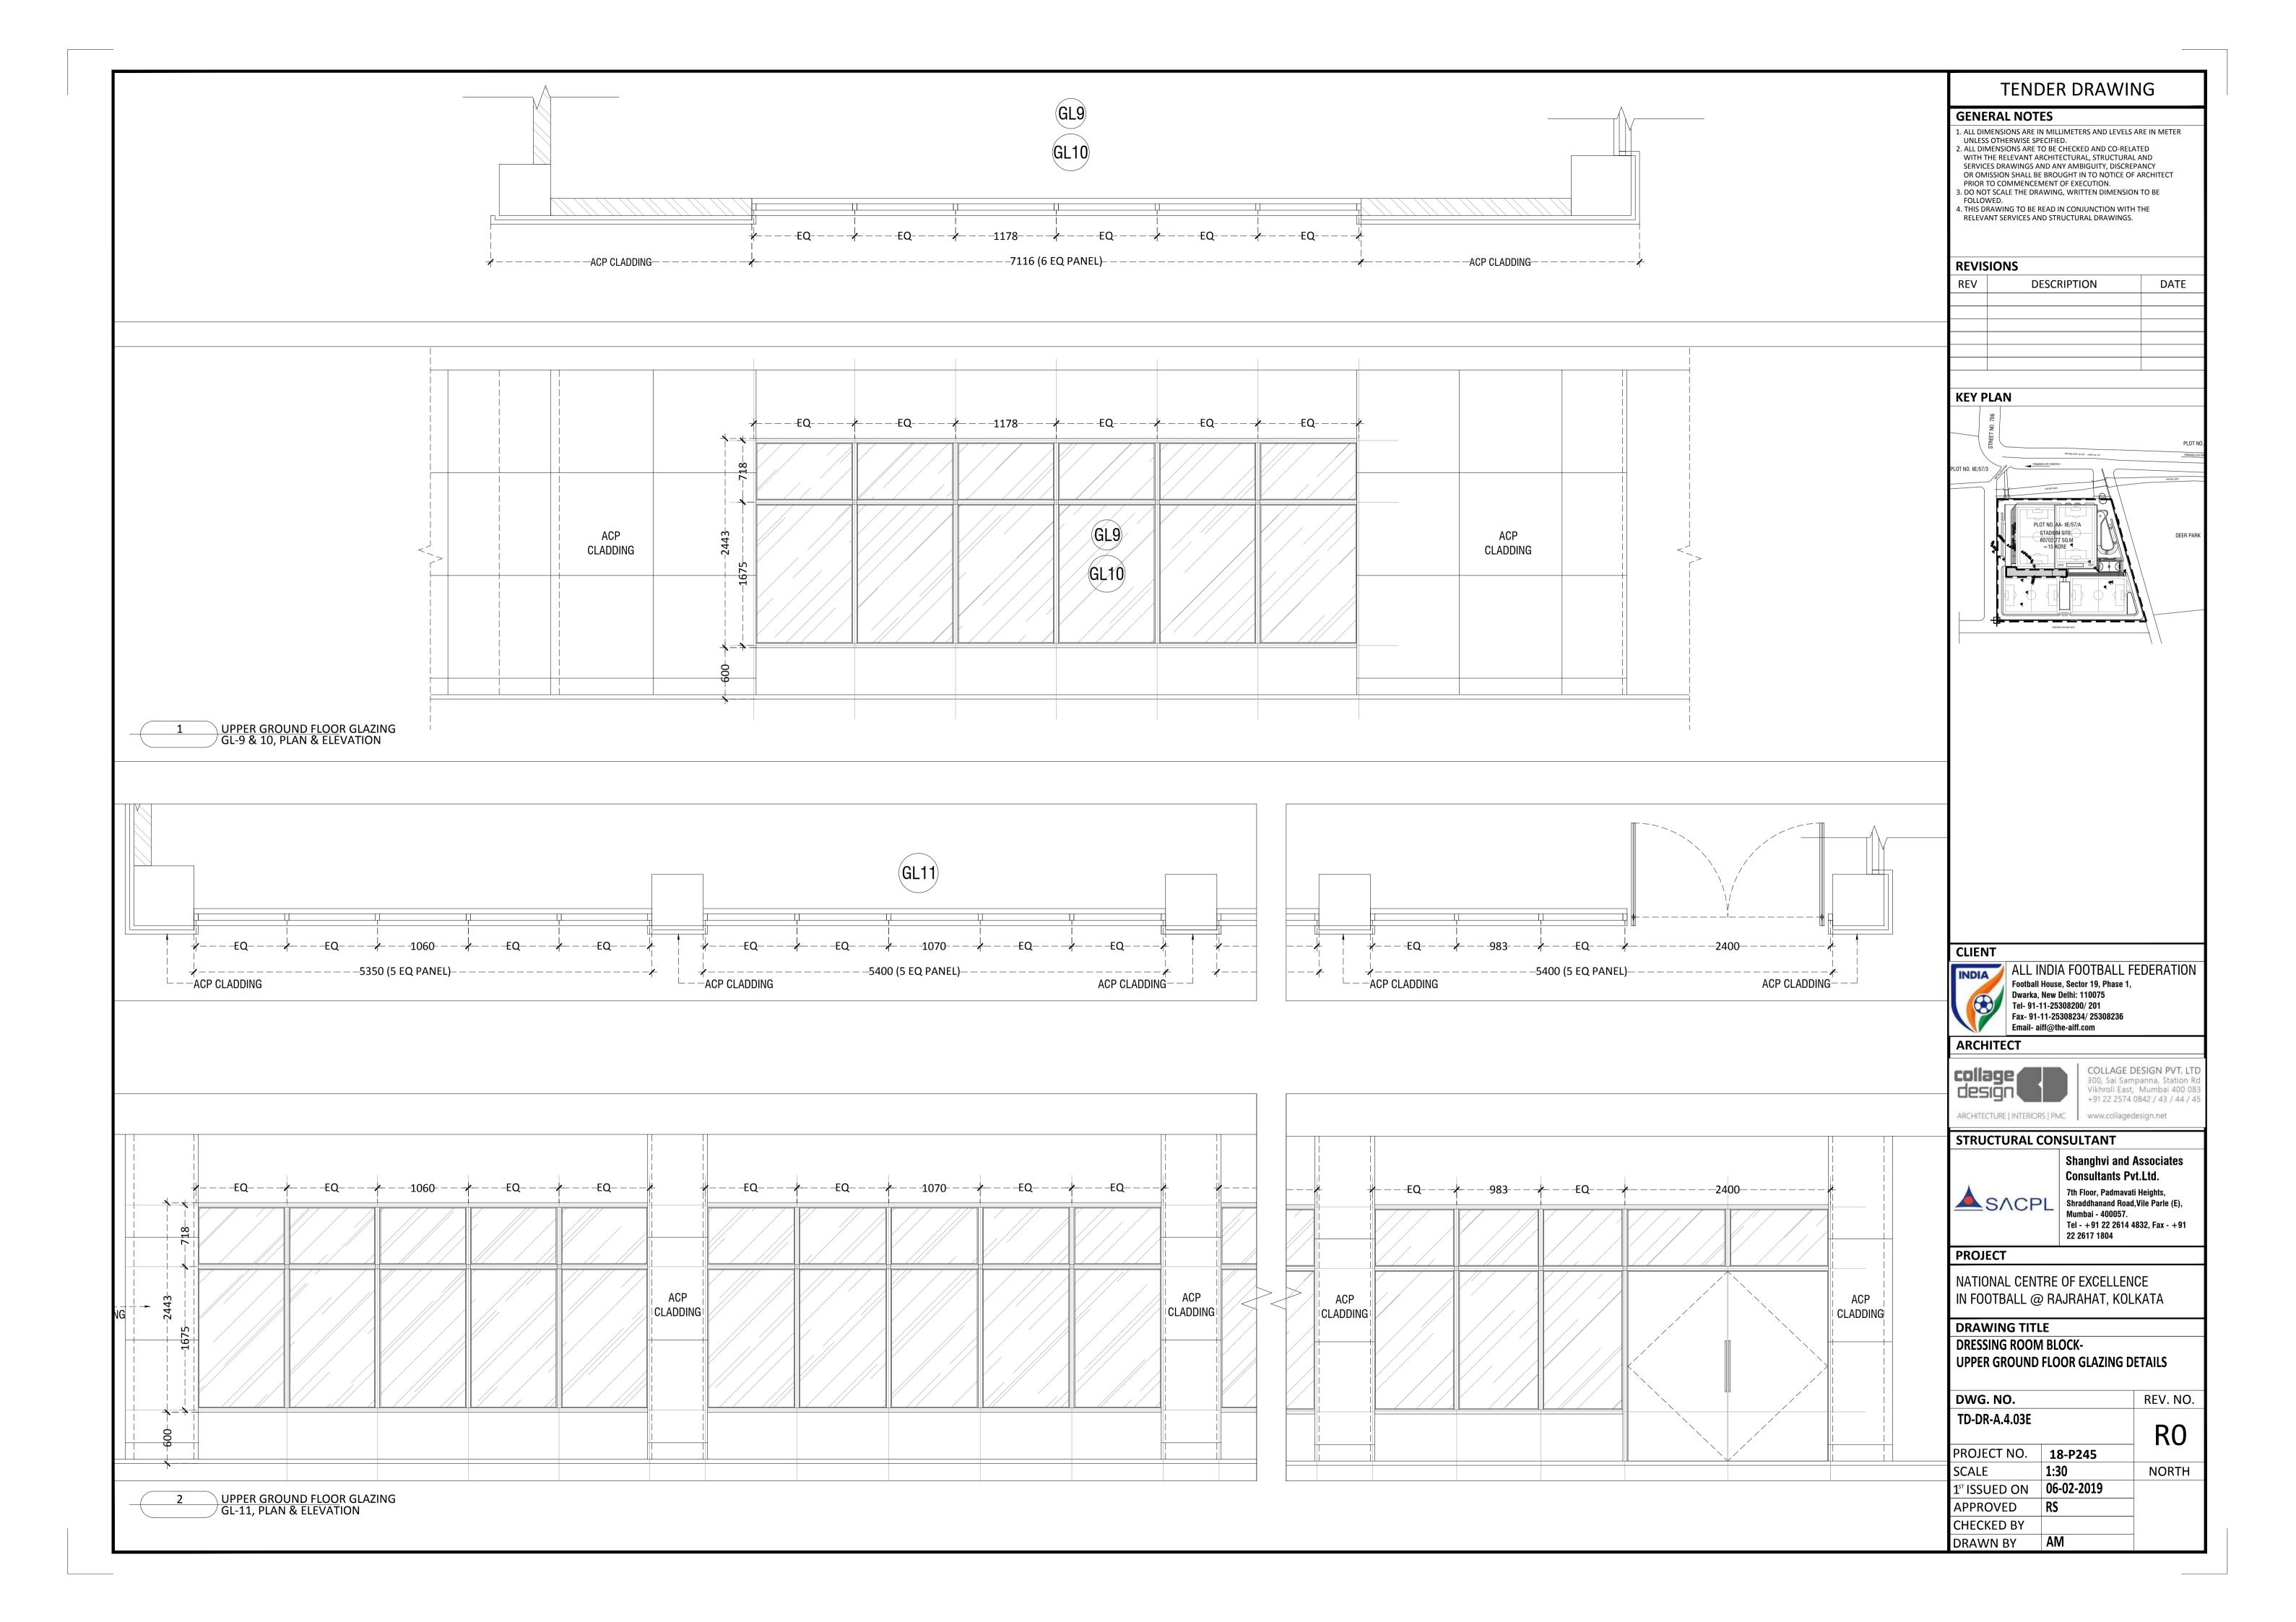

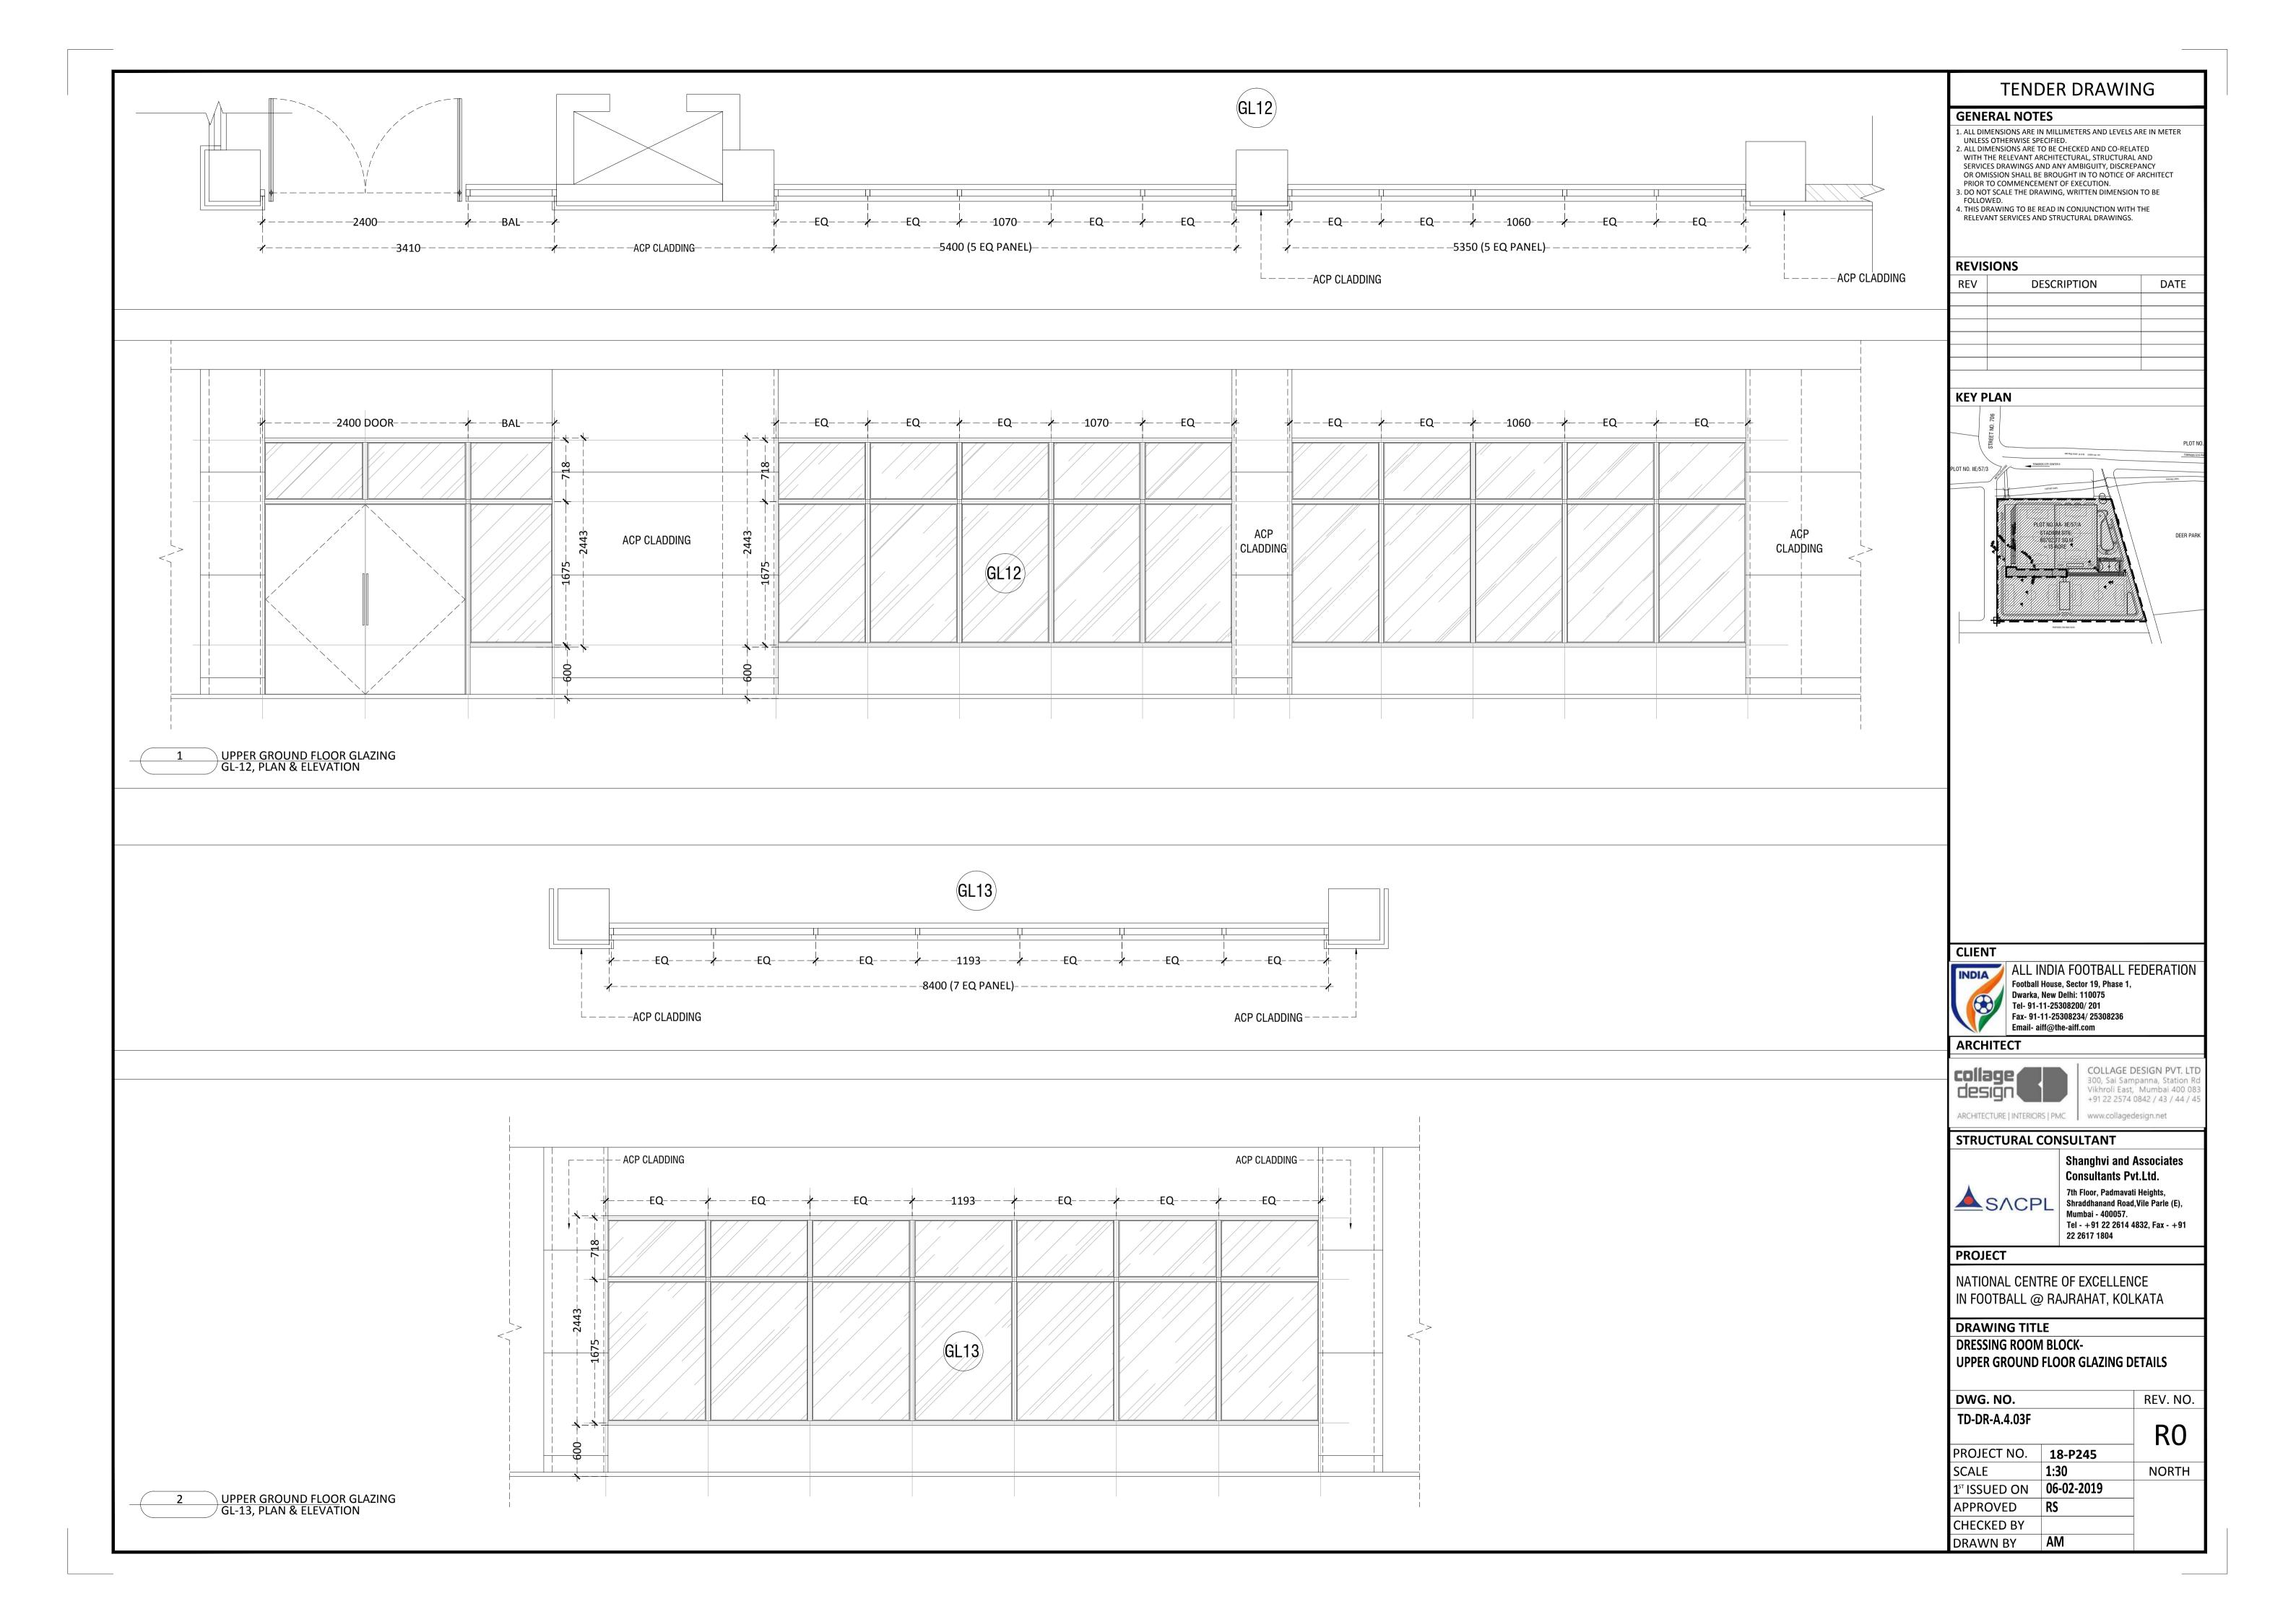


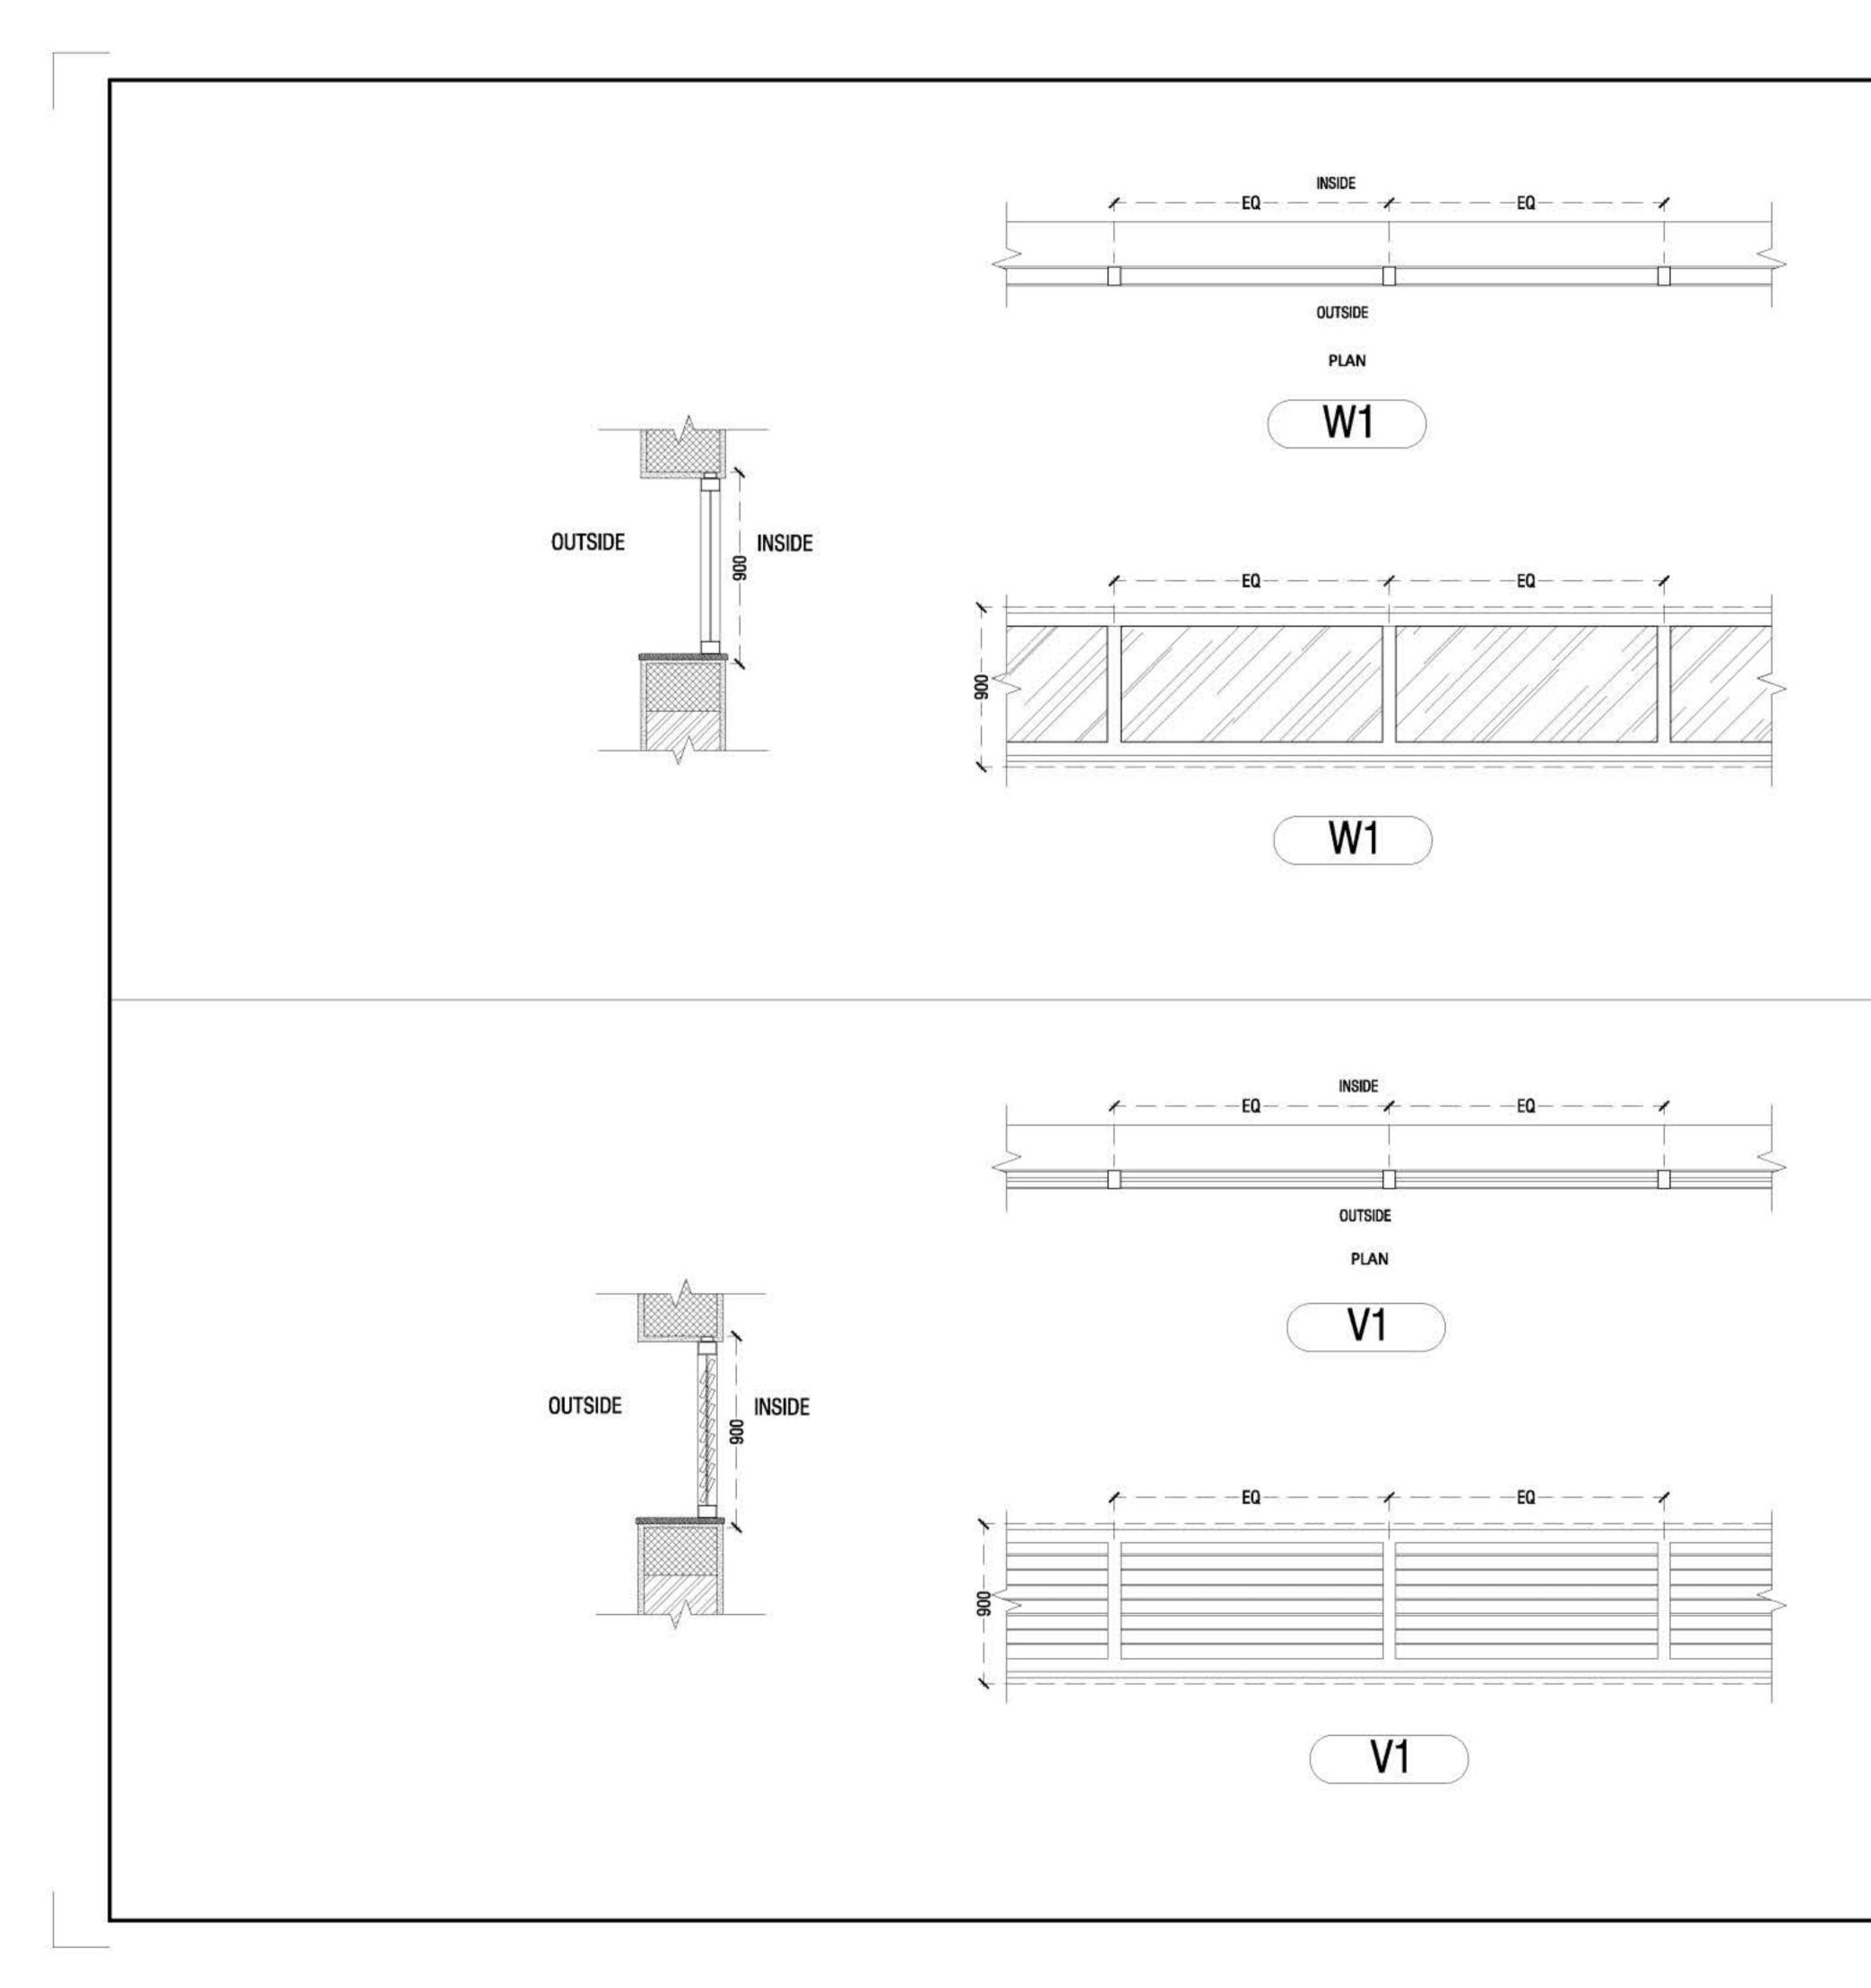


		ER DR		NG
1. ALL DIW UNLESS 2. ALL DIW WITH TH SERVICE OR OMI PRIOR T 3. DO NOT FOLLOW	RAL NOTE IENSIONS ARE IN OTHERWISE SPE IENSIONS ARE TO HE RELEVANT AR ES DRAWINGS AN SSION SHALL BE TO COMMENCEM T SCALE THE DRA VED. IAWING TO BE RE	MILLIMETERS CIFIED. D BE CHECKED. CHITECTURAL, ID ANY AMBIG BROUGHT IN T IENT OF EXECU WING, WRITTE	AND CO-RELA STRUCTURAL UITY, DISCREF O NOTICE OF TION. N DIMENSIOI	TED AND PANCY ARCHITECT N TO BE
	AWING TO BE RI NT SERVICES ANI			THE
REVIS	IONS			I.M.
REV	DE	SCRIPTIO	N	DATE
CLIEN	T			
CLIEN	J ALL IN			EDERATION
	ALL IN Football H Dwarka, N	louse, Sector 1 New Delhi: 110	19, Phase 1, 075	EDERATION
	ALL IN Football H Dwarka, N Tel- 91-1 Fax- 91-1	łouse, Sector 1 New Delhi: 110 1-25308200/ 2 1-25308234/ 2	19, Phase 1, 075 01 25308236	EDERATION
	ALL IN Football H Dwarka, N Tel- 91-1 Fax- 91-1 Email- ait	łouse, Sector 1 New Delhi: 110 1-25308200/ 2	19, Phase 1, 075 01 25308236	EDERATION
ARCH	ALL IN Football H Dwarka, I Tel- 91-1 Fax- 91-1 Email- aif	louse, Sector 1 New Delhi: 110 1-25308200/ 2 1-25308234/ 2 f@the-aiff.com	19, Phase 1, 075 01 25308236 n OLLAGE D	ESIGN PVT. LT
INDIA	ALL IN Football H Dwarka, I Tel- 91-1 Fax- 91-1 Email- aif	louse, Sector 1 New Delhi: 110 1-25308200/ 2 1-25308234/ 2 f@the-aiff.com	19, Phase 1, 075 01 25308236 n OLLAGE D 00, Sei Sam	ESIGN PVT. LT panna, Station 1 Mumbai 400 0
ARCH	ALL IN Football H Dwarka, I Tel- 91-1 Fax- 91-1 Email- aif	louse, Sector 1 New Delhi: 110 1-25308200/ 2 1-25308234/ 2 f@the-aiff.com	19, Phase 1, 075 01 25308236 n OLLAGE D 00, Sei Sam	ESIGN PVT. LT patina, Station f Mumbai 400 0 9842 / 43 /-44 /-
ARCH COLLAR ARCHITEC	ALL IN Football H Dwarka, N Tel- 91-1 Fax- 91-1 Email- aif	louse, Sector 1 New Delhi: 110 1-25308200/ 2 1-25308234/ 2 f@the-aiff.com	9, Phase 1, 075 01 25308236 n OLLAGE D 00, Sei Sam Noroll East 91 22 2574 (	ESIGN PVT. LT patina, Station f Mumbai 400 0 9842 / 43 /-44 /-
ARCH COLLAR ARCHITEC	ALL IN Football H Dwarka, N Tel-91-1 Fax-91-1 Email- aid	louse, Sector 1 New Delhi: 110 1-25308200/ 2 1-25308234/ 2 f@the-aiff.com	9, Phase 1, 075 01 25308236 n COLLAGE D 00, Sei Sem Netroli Sent 91 22 2574 ( www.collaged ANT ghvi and A	ESIGN PVT. LT pattina, Station f Mumbai 400 0 9842 / 43 / 44 / 4 esign net
ARCH	ALL IN Football H Dwarka, N Tel-91-1 Fax-91-1 Email- aid ITECT	louse, Sector 1 New Delhi: 110 1-25308200/2 1-25308234/2 f@the-aiff.com	19, Phase 1, 075 01 25308236 n OLLAGE D 00, 54 54m 191 22 2574 ( MWY collaged ANT ghvi and <i>A</i> Iltants Pv	ESIGN PVT. LT patrina, Station f Mumbal 400 0 0842 / 43 / 44 / 4 esign net Associates t.Ltd.
ARCH	ALL IN Football H Dwarka, N Tel-91-1 Fax-91-1 Email- aid	iouse, Sector 7 New Delhi: 110 1-25308200/ 2 1-25308234/ 2 f@the-aiff.com ONSULT ONSULT Shang Consu 7th Floc Shradd	9, Phase 1, 075 01 25308236 n OLLAGE D 00, Sei Sem Nerroll East 91 22 2574 ( www.collaged ANT ghvi and A ultants Pv or, Padmavati	ESIGN PVT. LT patrina, Station f Mumbal 400 0 0842 / 43 / 44 / 4 esign net Associates t.Ltd.
ARCH	ALL IN Football H Dwarka, N Tel-91-1 Fax-91-1 Email- aid ITECT	louse, Sector 1 New Delhi: 110 1-25308200/ 2 1-25308234/ 2 f@the-aiff.com ONSULT ONSULT Shang Consu 7th Floo Shradd Mumba	19, Phase 1, 075 01 25308236 n OLLAGE D COLLAGE D COLLAG	ESIGN PVT. LT pattina, Station f Mumbal 400 0 0842 / 43 / 44 / 4 esign nat Associates t.Ltd. i Heights,
ARCH	ALL IN Football H Dwarka, N Tel-91-1 Fax-91-1 Email- aid ITECT	louse, Sector 1 New Delhi: 110 1-25308200/2 1-25308234/2 f@the-aiff.com ONSULT ONSULT Shang Consu 7th Floc Shraddl Mumba Tel - +	19, Phase 1, 075 01 25308236 n OLLAGE D COLLAGE D COLLAG	ESIGN PVT. LT parma, Station P Mumba 1400 0 1942 / 43 / 44 / 4 asign net Associates t.Ltd. i Heights, Vile Parle (E),
ARCH COLLES ACOULT STRUC	ALL IN Football H Dwarka, N Tel-91-1 Fax-91-1 Email- aid ITECT	louse, Sector 1 New Delhi: 110 1-25308200/2 1-25308234/2 f@the-aiff.com ONSULT ONSULT Shang Consu 7th Floc Shraddl Mumba Tel - + 22 2617	19, Phase 1, 075 01 25308236 n OLLAGE D 00 54 54 91 22 2574 0 WW COLOCE D 00 54 54 91 22 2574 0 WW COLOCE D 00 54 54 91 22 2574 0 WW COLOCE D 01 25 25 25 0 WW COLOCE D 01 25 25 25 0 WW COLOCE D 01 25 25 25 25 25 25 25 25 25 25 25 25 25	ESIGN PVT. LT panna, Station 1 Mumbal 400 0 1942 / 43 / 44 / 4 Esign net Associates t.Ltd. Heights, Vile Parle (E), 832, Fax - +91
ARCH COLLES ARCH STRUC STRUC PROJE NATIO	ALL IN Football H Dwarka, N Tel-91-1 Fax-91-1 Email- aid ITECT	Aouse, Sector 1 New Delhi: 110 1-25308200/ 2 1-25308234/ 2 f@the-aiff.com ONSULT ONSULT Shang Consu 7th Floc Shraddl Mumba Tel - + 22 2617 RE OF EX	19, Phase 1, 075 01 25308236 n OLLAGE D 00 54 54 91 22 2574 0 ANT ghvi and A iltants Pv or, Padmavati nanand Road, i - 400057. 91 22 2614 4 7 1804	ESIGN PVT. LT parma, Station 1 Mumbal 400 0 2942 / 43 / 44 / 4 esignmet Associates t.Ltd. i Heights, Vile Parle (E), 832, Fax - +91 CE
ARCH COLLA COLLA C	ALL IN Football H Dwarka, N Tel-91-1 Fax-91-1 Email- aid ITECT	Aouse, Sector 1 New Delhi: 110 1-25308200/ 2 1-25308234/ 2 f@the-aiff.com ONSULT ONSULT Shang Consu 7th Floc Shraddl Mumba Tel - + 22 2617 RE OF EX RAJRAH	19, Phase 1, 075 01 25308236 n OLLAGE D 00 54 54 91 22 2574 0 ANT ghvi and A iltants Pv or, Padmavati nanand Road, i - 400057. 91 22 2614 4 7 1804	ESIGN PVT. LT parma, Station 1 Mumbal 400 0 2942 / 43 / 44 / 4 esignmet Associates t.Ltd. i Heights, Vile Parle (E), 832, Fax - +91 CE
ARCH COLLES ARCH STRUE STRUE PROJE NATIO IN FOC DRAW DRES	ALL IN Football H Dwarka, M Tel-91-1 Fax-91-1 Email- aid ITECT ISF (C) CTURAL C SACP SACP SACP SACP SACP ING TITL SING RC	Aouse, Sector 1 New Delhi: 110 1-25308200/2 1-25308234/2 f@the-aiff.com ONSULT ONSULT Shang Consu 7th Floc Shraddl Mumba Tel - + 22 2617 RE OF EX RAJRAH E DOM BL	IIIIIIIIIIIIIIIIIIIIIIIIIIIIIIIIIIIIII	ESIGN PVT. LT Mumbal 400 0 1942 / 43 / 44 / 1 1942 / 43 / 44 / 1 1944
ARCH COLLES ARCH STRUE STRUE STRUE PROJE NATIO IN FOO DRAW DRES TYPIC	ALL IN Football H Dwarka, M Tel-91-1 Fax-91-1 Email- aid ITECT ISF (C) CTURAL C CTURAL C SACP CTURAL CENT DTBALL @ VING TITL SING RC CAL WIN	Aouse, Sector 1 New Delhi: 110 1-25308200/2 1-25308234/2 f@the-aiff.com ONSULT ONSULT Shang Consu 7th Floc Shraddl Mumba Tel - + 22 2617 RE OF EX RAJRAH E DOM BL	IIIIIIIIIIIIIIIIIIIIIIIIIIIIIIIIIIIIII	ESIGN PVT. LT Mumbal 400 0 1942 / 43 / 44 / 1 1942 / 43 / 44 / 1 1944
ARCH	ALL IN Football F Dwarka, P Tel-91-1 Fax-91-1 Email- aid ITECT ISF (C) CTURAL C CTURAL C SACP CTURAL C SACP CTURAL CENT DTBALL @ VING TITL SING RC CAL WIN ILS	Aouse, Sector 1 New Delhi: 110 1-25308200/2 1-25308234/2 f@the-aiff.com ONSULT ONSULT Shang Consu 7th Floc Shraddl Mumba Tel - + 22 2617 RE OF EX RAJRAH E DOM BL	IIIIIIIIIIIIIIIIIIIIIIIIIIIIIIIIIIIIII	ESIGN PVT. LT Mumbal 400 0 1942 / 43 / 44 / Esign net Associates t.Ltd. Heights, Vile Parle (E), 832, Fax - +91 CE KATA /ERS
ARCH	ALL IN Football F Dwarka, P Tel-91-1 Fax-91-1 Email- aid ITECT ISF (C) CTURAL C CTURAL C SACP CTURAL C SACP CTURAL CENT DTBALL @ VING TITL SING RC CAL WIN ILS	Aouse, Sector 1 New Delhi: 110 1-25308200/ 2 1-25308234/ 2 f@the-aiff.com ONSULT Shang Consu 7th Floc Shraddl Mumba Tel - + 22 2617 RE OF EX RAJRAH E DOM BL DOW 8	IIIIIIIIIIIIIIIIIIIIIIIIIIIIIIIIIIIIII	ESIGN PVT. LT parina, Station 1 Mumbal 400 0 1042 / 43 / 44 / Esign ret Associates t.Ltd. Heights, Vile Parle (E), 832, Fax - +91 CE KATA ZERS REV. NO
ARCH COLLES ARCH COLLES ARCH COLLES ARCH STRUC STRUC STRUC STRUC DETA DRAW DRES TYPIC DETA DWG. TD-D	ALL IN Football H Dwarka, M Tel-91-1 Fax-91-1 Email- aid ITECT ISC (C) CTURAL C CTURAL C CTURAL C CTURAL C CTURAL C CTURAL C CTURAL C C CTURAL C C C C C C C C C C C C C C C C C C C	Aouse, Sector 1 New Delhi: 110 1-25308200/2 1-25308234/2 f@the-aiff.con ONSULT Shang Consu 7th Floc Shraddl Mumba Tel - + 22 2612 RE OF EX RAJRAH E DOM BL DOW 8	9, Phase 1, 075 01 253082336 n OLLAGE D 00 Set Sent 91 22 2574 ( ANT 91 22 2574 ( ANT 91 22 2574 ( ANT 91 22 2614 4 7 1804 CELLEN AT, KOL OCK- 2 LOUV	ESIGN PVT. LT Mumbal 400 0 1942 / 43 / 44 / Esign net Associates t.Ltd. Heights, Vile Parle (E), 832, Fax - +91 CE KATA /ERS
ARCH	ALL IN Football F Dwarka, N Tel-91-1 Fax-91-1 Email- aid ITECT ISF (C) CTURAL C CTURAL C CTURAL C CTURAL C CTURAL C ECT NAL CENT DTBALL @ VING TITL SING RC CAL WIN ALS NO.	Aouse, Sector 1 New Delhi: 110 1-25308200/2 1-25308234/2 f@the-aiff.com ONSULT Shang Consu 7th Floc Shraddl Mumba Tel - + 22 2617 RE OF EX RAJRAH E DOM BL DOW 8 1A 18-P24	9, Phase 1, 075 01 253082336 n OLLAGE D 00 Set Sent 91 22 2574 ( ANT 91 22 2574 ( ANT 91 22 2574 ( ANT 91 22 2614 4 7 1804 CELLEN AT, KOL OCK- 2 LOUV	ESIGN PVT. LT Mumbal 400 0 1942 / 43 / 44 / Esign ret Associates t.Ltd. Heights, Vile Parle (E), 832, Fax - +91 CE KATA ZERS REV. NO RO
ARCH COLLE ARCH COLLE	ALL IN Football H Dwarka, M Tel-91-1 Fax-91-1 Email- aid ITECT ISC (C) CTURAL C CTURAL C CTURAL C CTURAL C CTURAL C CTURAL C CTURAL C C CTURAL C C C C C C C C C C C C C C C C C C C	Aouse, Sector 1 New Delhi: 110 1-25308200/2 1-25308234/2 f@the-aiff.con ONSULT Shang Consu 7th Floc Shraddl Mumba Tel - + 22 2612 RE OF EX RAJRAH E DOM BL DOW 8	9, Phase 1, 075 01 25308236 n OLLAGE D 00 54 54 01 22 2574 01 22 2574	ESIGN PVT. LT parina, Station 1 Mumbal 400 0 1042 / 43 / 44 / Esign ret Associates t.Ltd. Heights, Vile Parle (E), 832, Fax - +91 CE KATA ZERS REV. NO
ARCH	ALL IN Football H Dwarka, N Tel-91-1 Fax-91-1 Email- aid ITECT ISCORE CTURAL C CTURAL C SACP CTURAL CENT DTBALL @ VING TITL SING RC CAL WIN ALS NO. R-A.4.04 CT NO. JED ON	Aouse, Sector 1 New Delhi: 110 1-25308230/2 1-25308234/2 f@the-aiff.com ONSULT Shang Consu 7th Floc Shraddl Mumba Tel - + 22 2617 RE OF EX RAJRAH E DOM BL DOW 8 AA 18-P24 1:30	9, Phase 1, 075 01 25308236 n OLLAGE D 00 54 54 01 22 2574 01 22 2574	ESIGN PVT. LT Mumbal 400 0 1942 / 43 / 44 / Esign ret Associates t.Ltd. Heights, Vile Parle (E), 832, Fax - +91 CE KATA ZERS REV. NO RO
ARCH	ALL IN Football H Dwarka, M Tel-91-1 Fax-91-1 Email- aid ITECT ISC (C) CTURAL C CTURAL C CTURAL C CTURAL C CTURAL C CTURAL CENT OTBALL @ VING TITL SING RC CAL WIN OTBALL @ VING TITL SING RC CAL WIN OTBALL @ CAL WIN	Aouse, Sector 1 New Delhi: 110 1-253082300/2 1-25308234/2 f@the-aiff.con ONSULT Shang Consu 7th Floc Shraddl Mumba Tel - + 22 2612 RE OF EX RAJRAH E DOM BL DOW 8 18-P24 1:30 06-02-2	9, Phase 1, 075 01 25308236 n OLLAGE D 00 54 54 01 22 2574 01 20 20 01 20 20	ESIGN PVT. LT Mumbal 400 0 1942 / 43 / 44 / Esign ret Associates t.Ltd. Heights, Vile Parle (E), 832, Fax - +91 CE KATA ZERS REV. NO RO

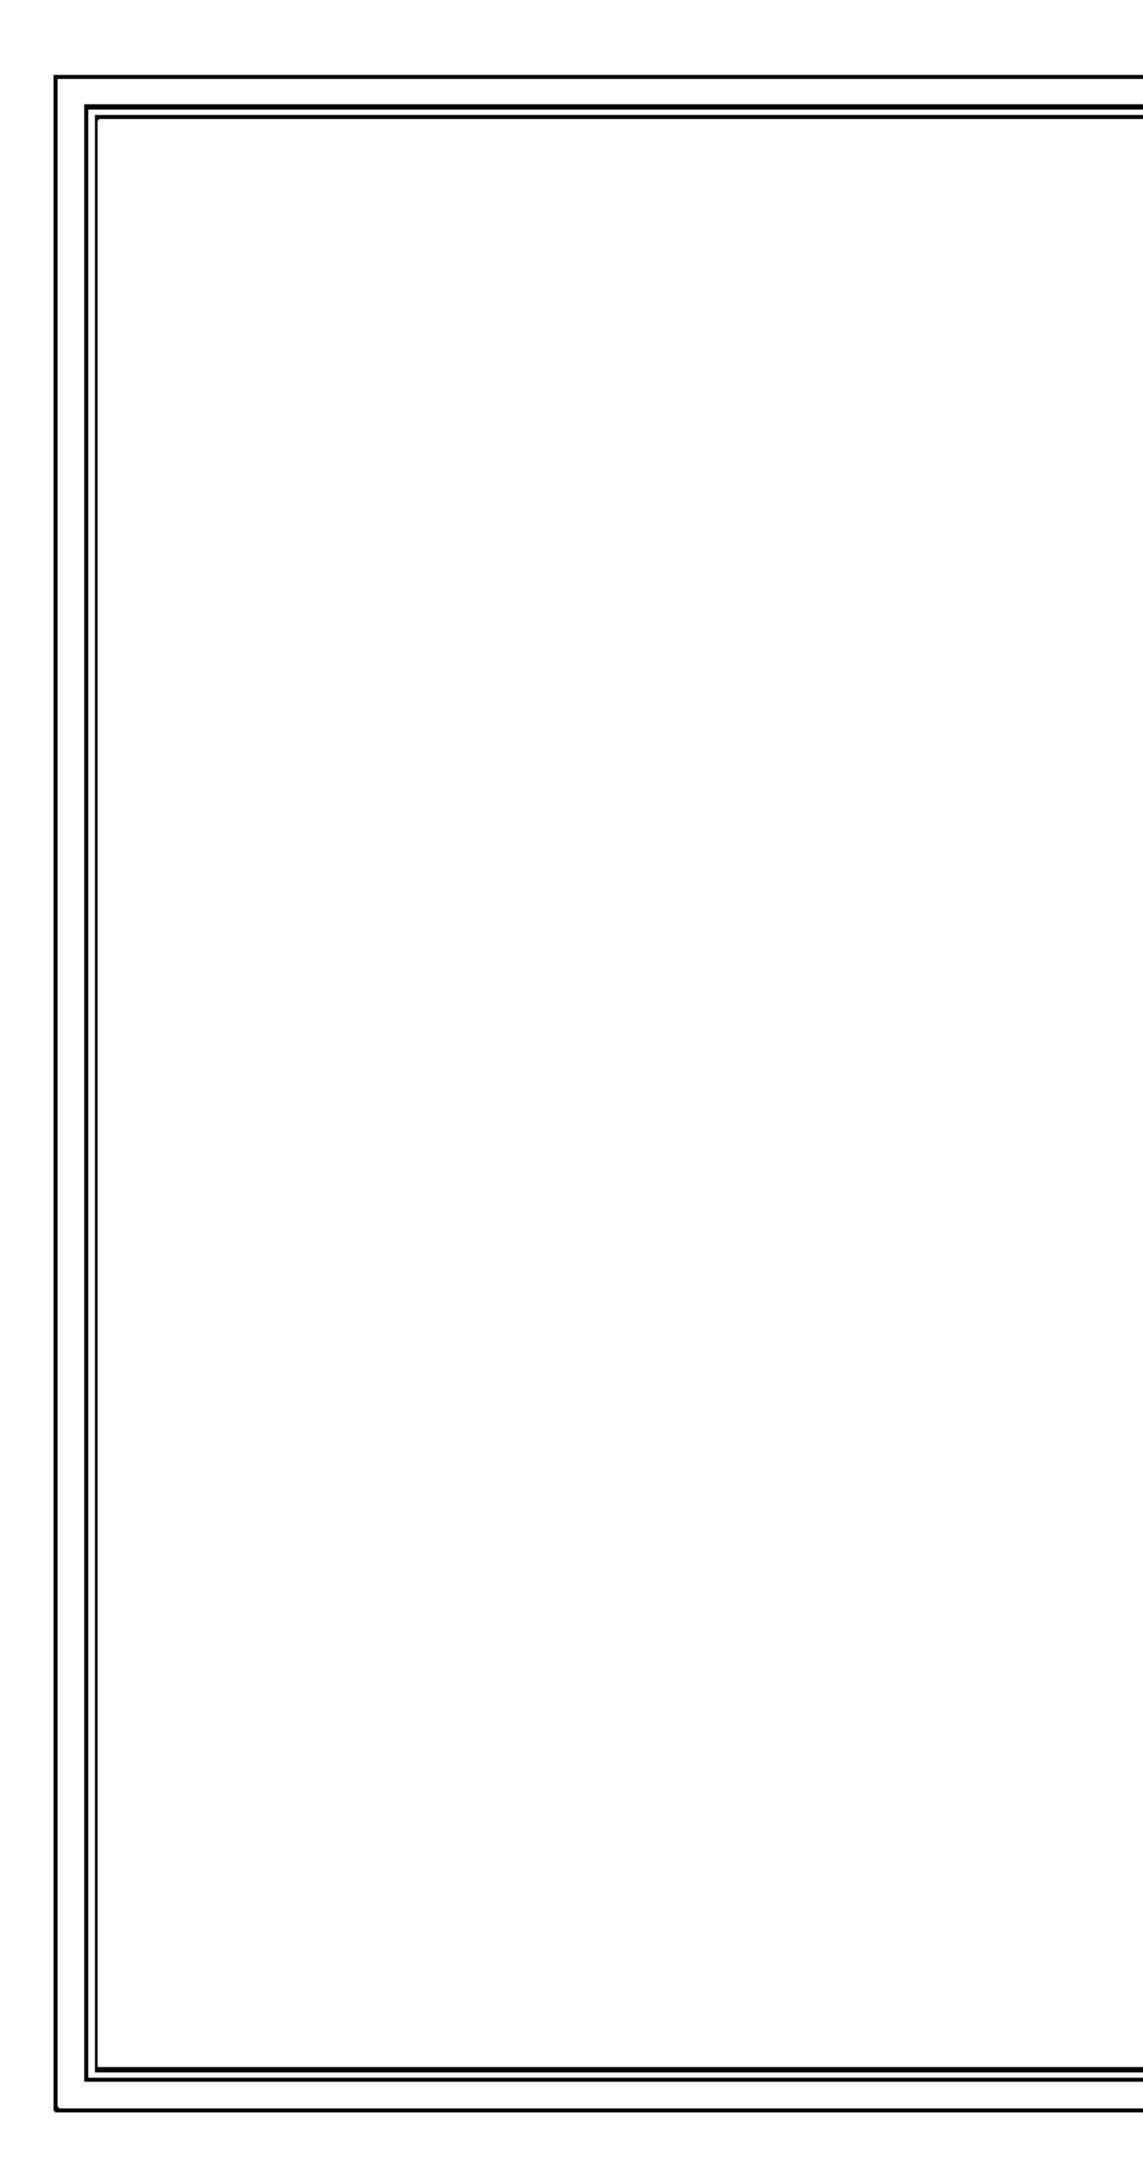



### • STRUCTURAL DRAWINGS

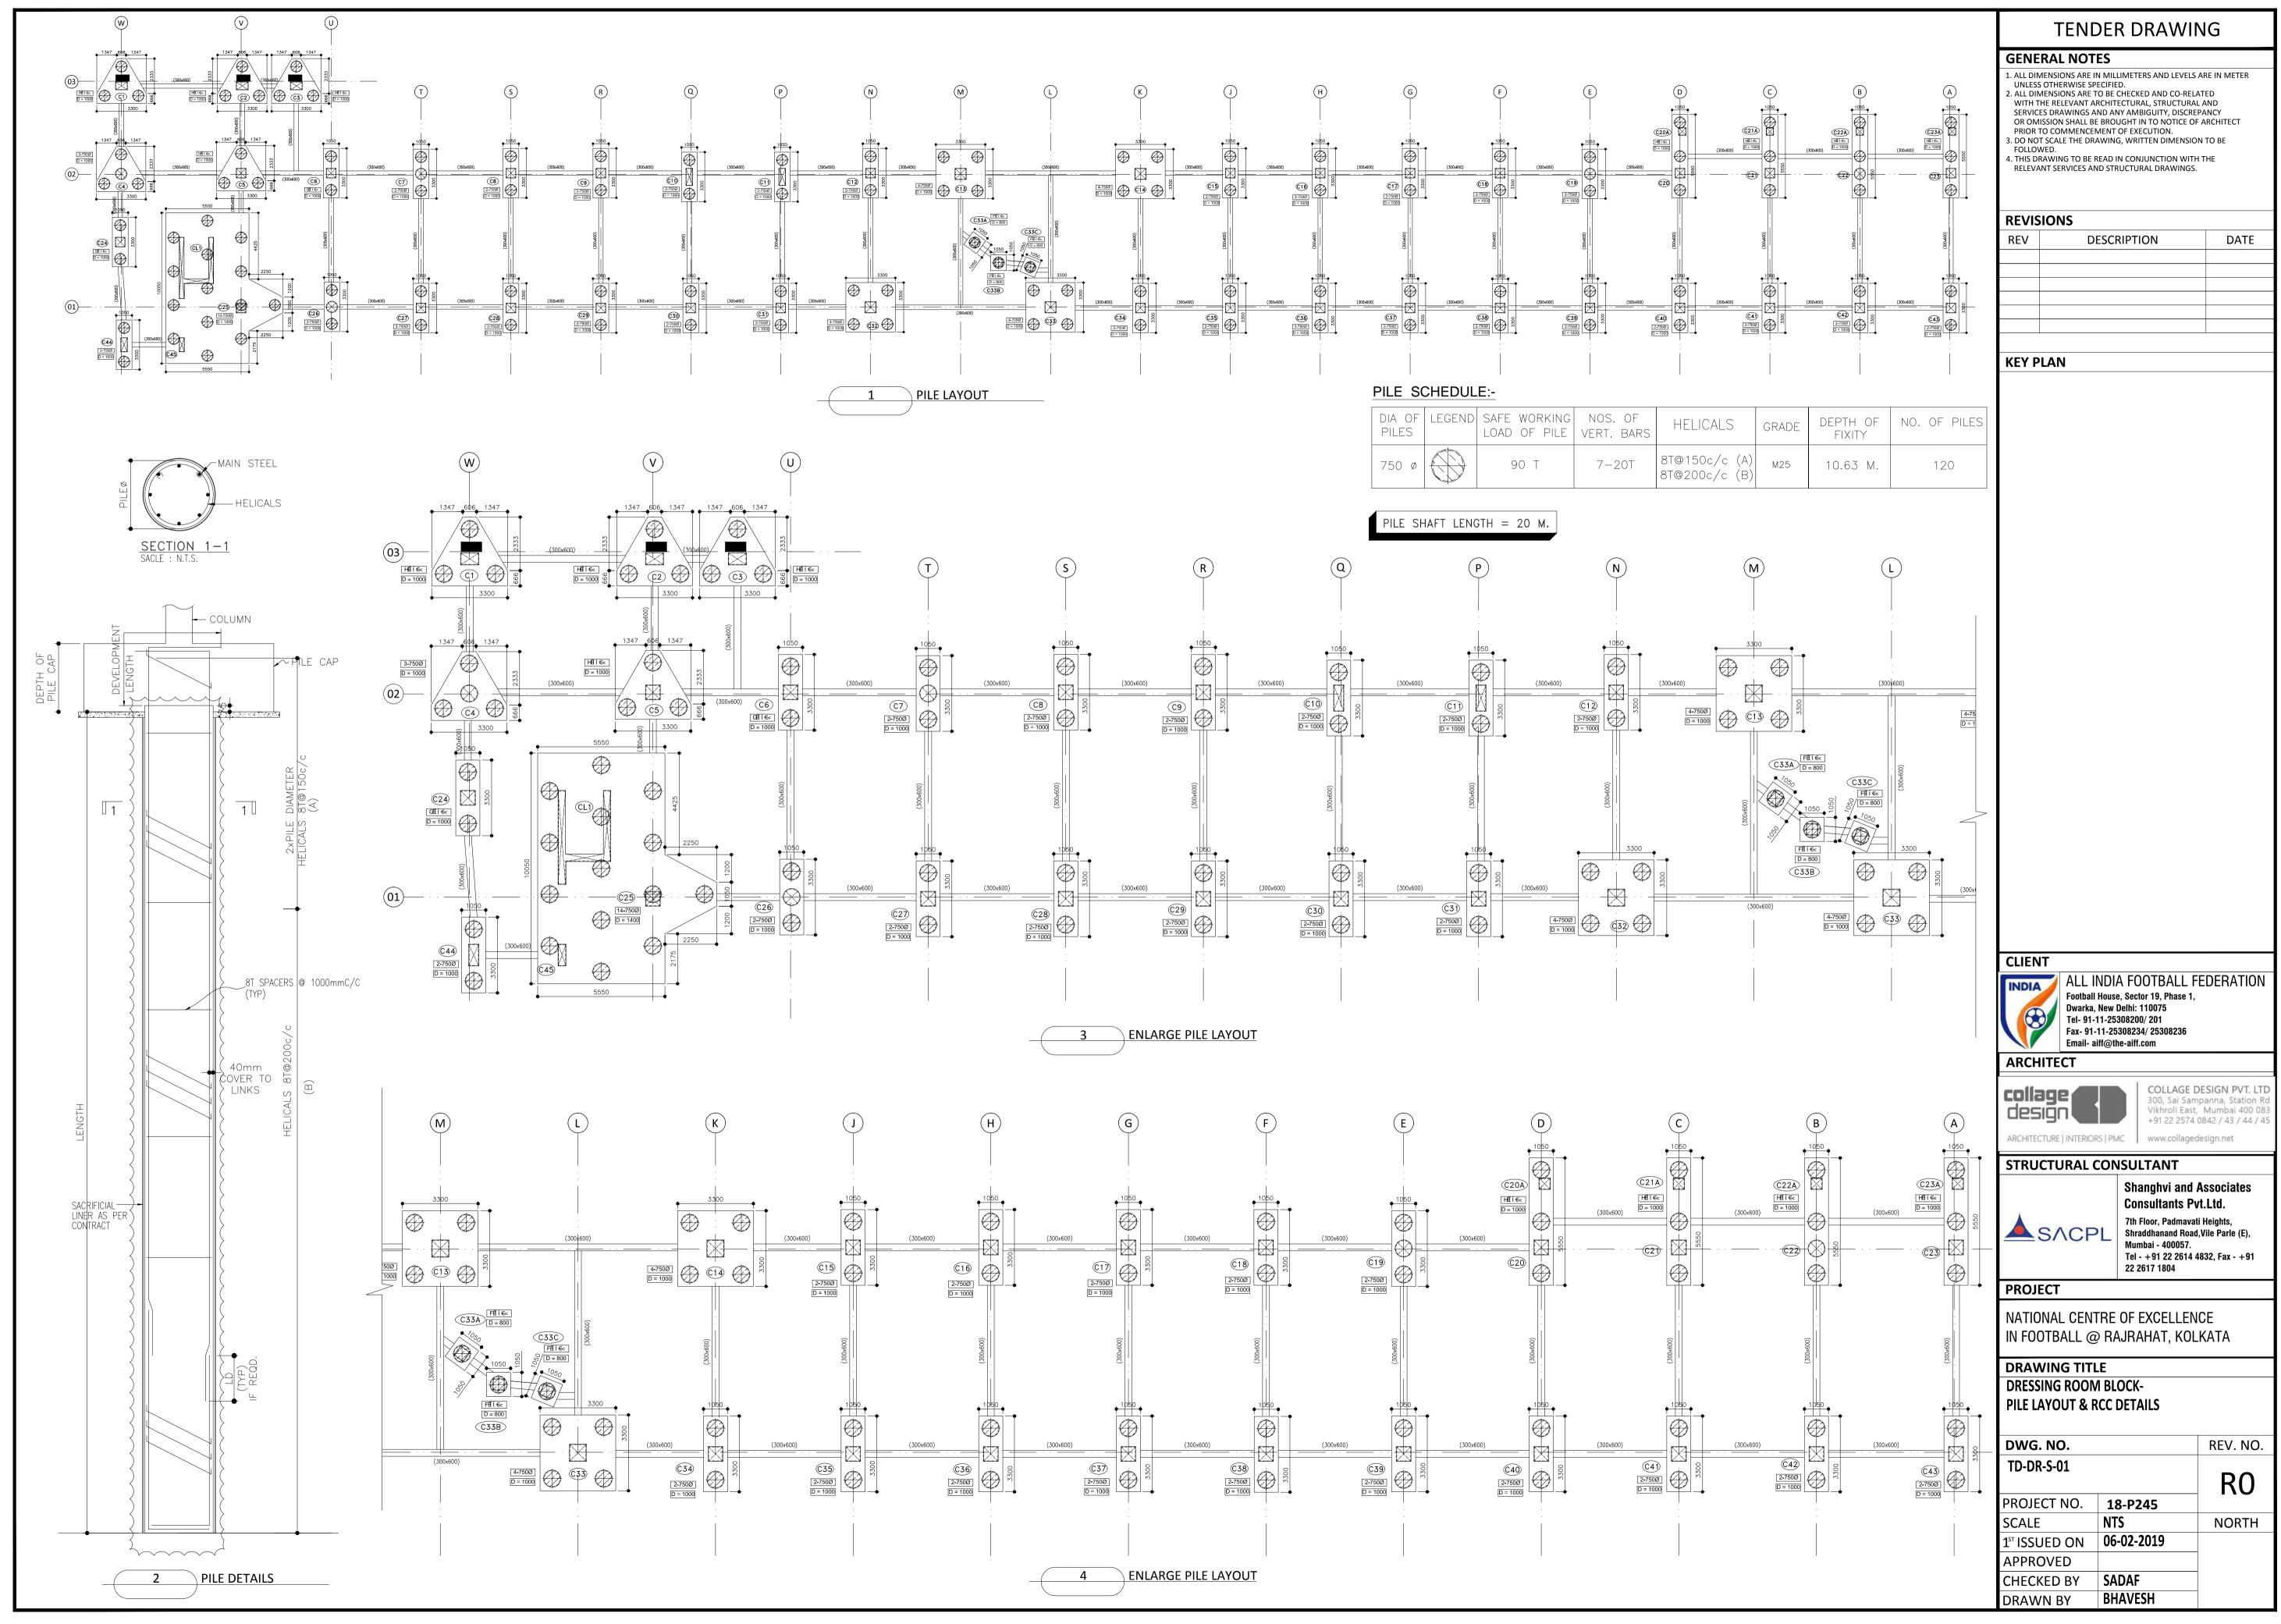


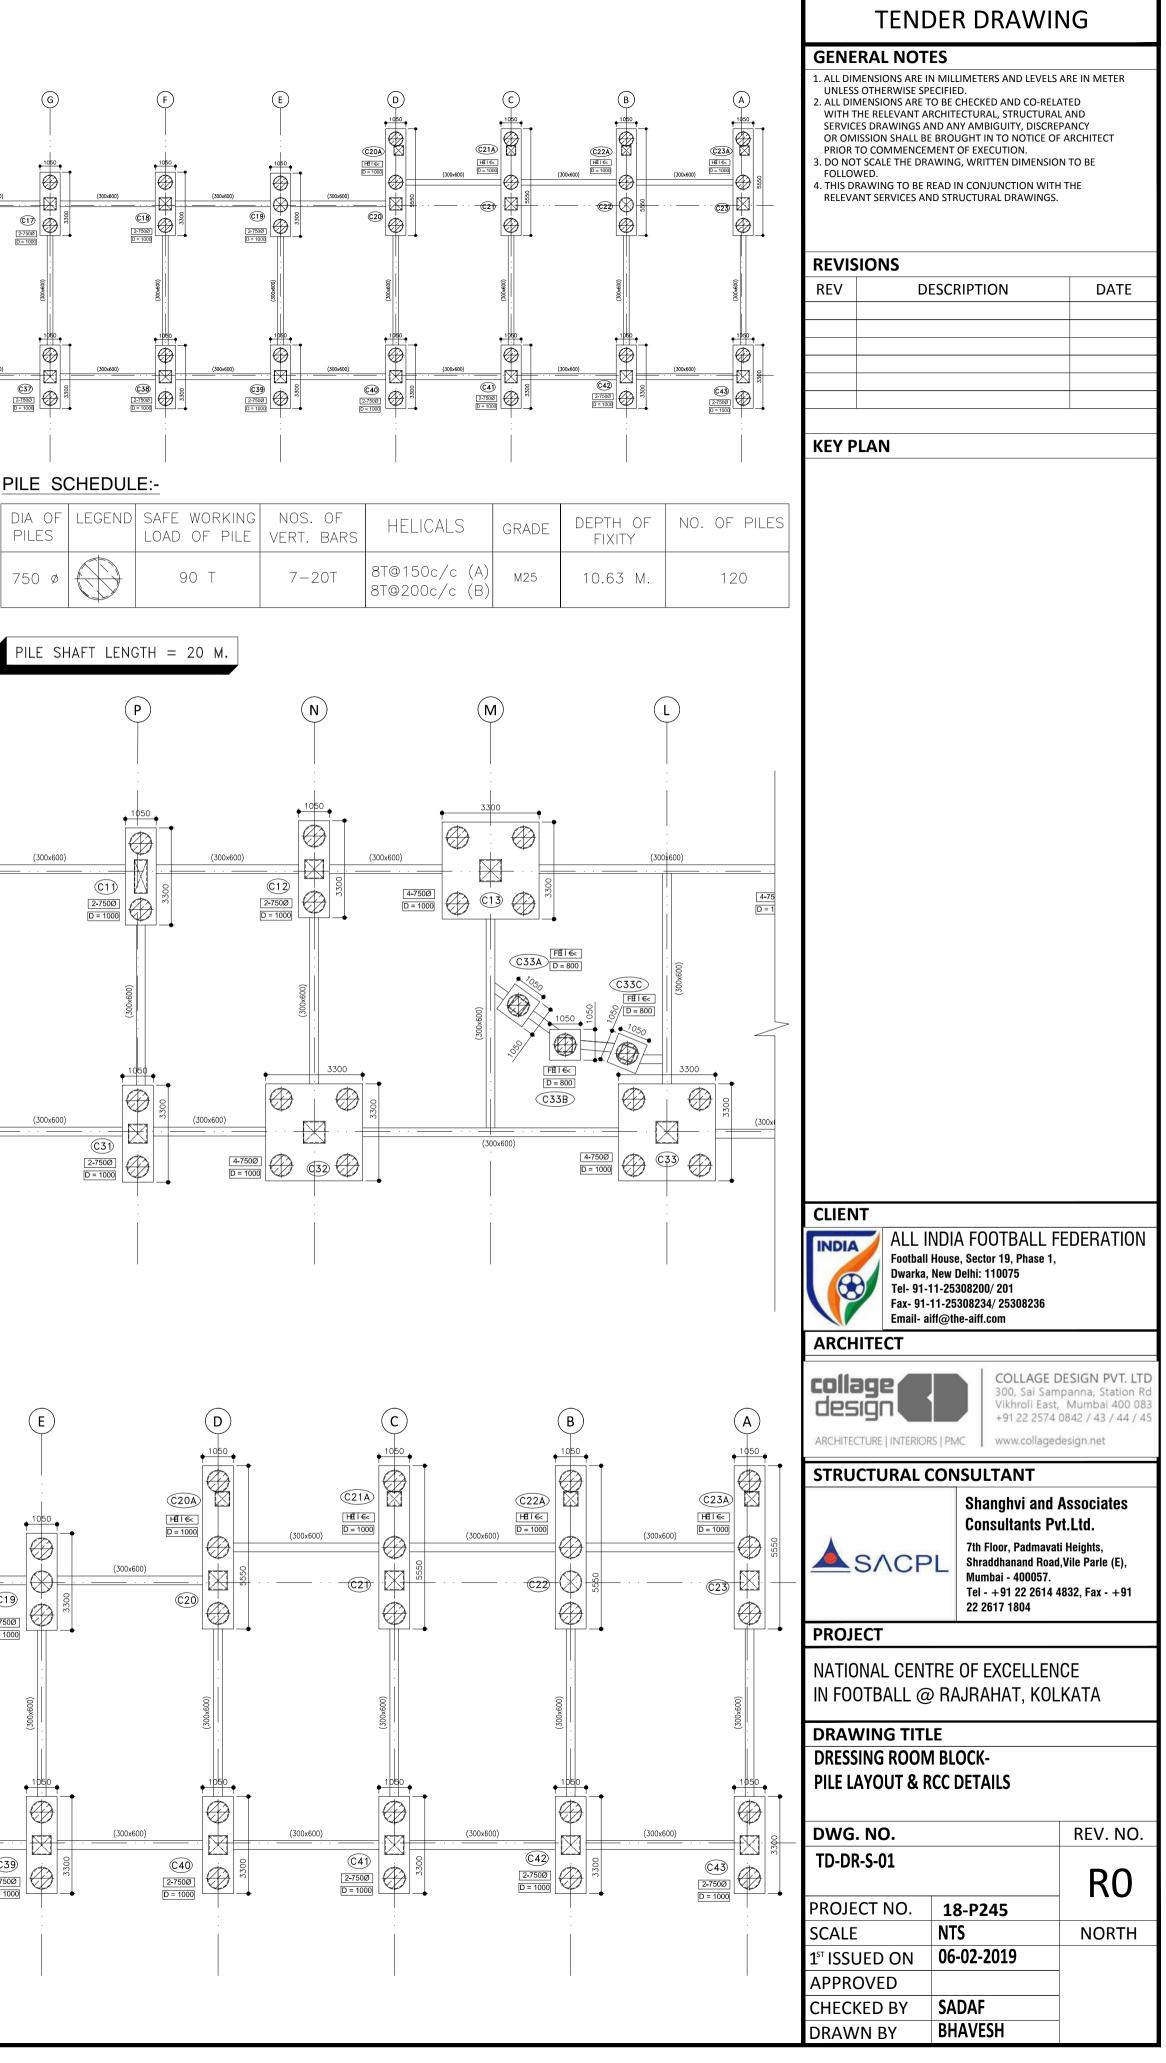


DIA OF PILES	LEGEND	SAFE WORKING LOAD OF PILE		HELICALS	
750 Ø		90 T	7-20T	8T@150c/c (A) 8T@200c/c (B)	

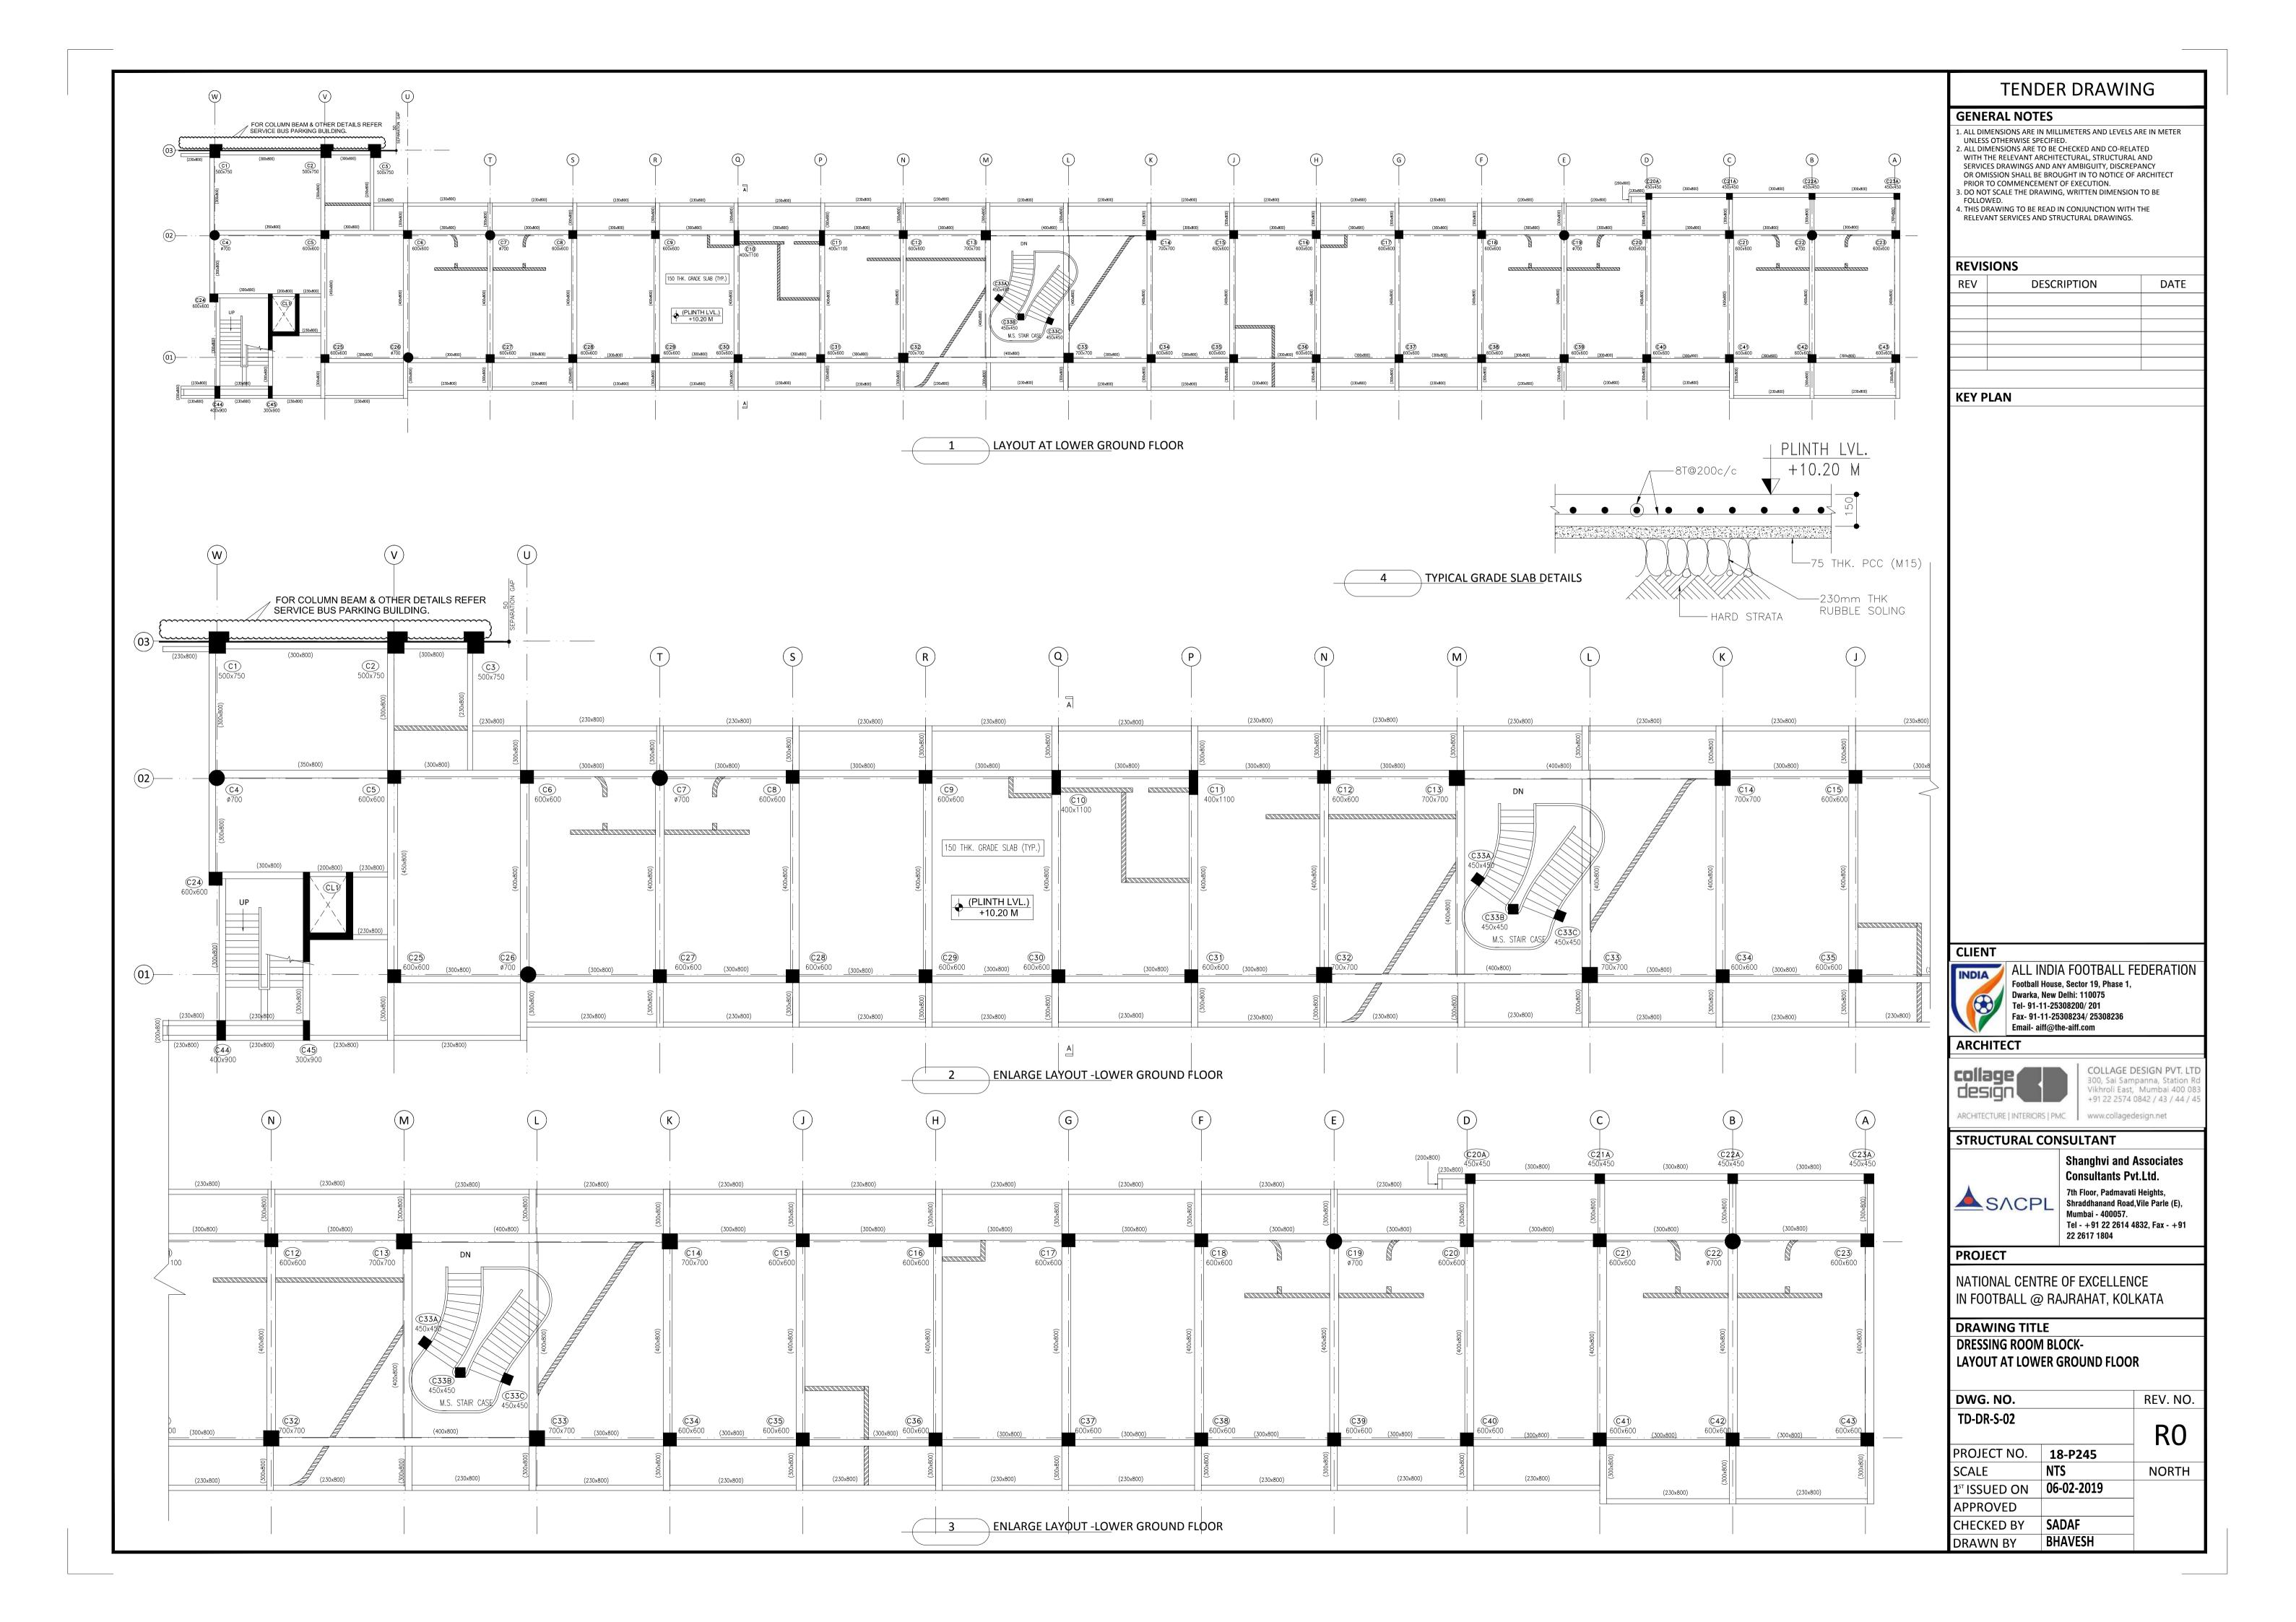


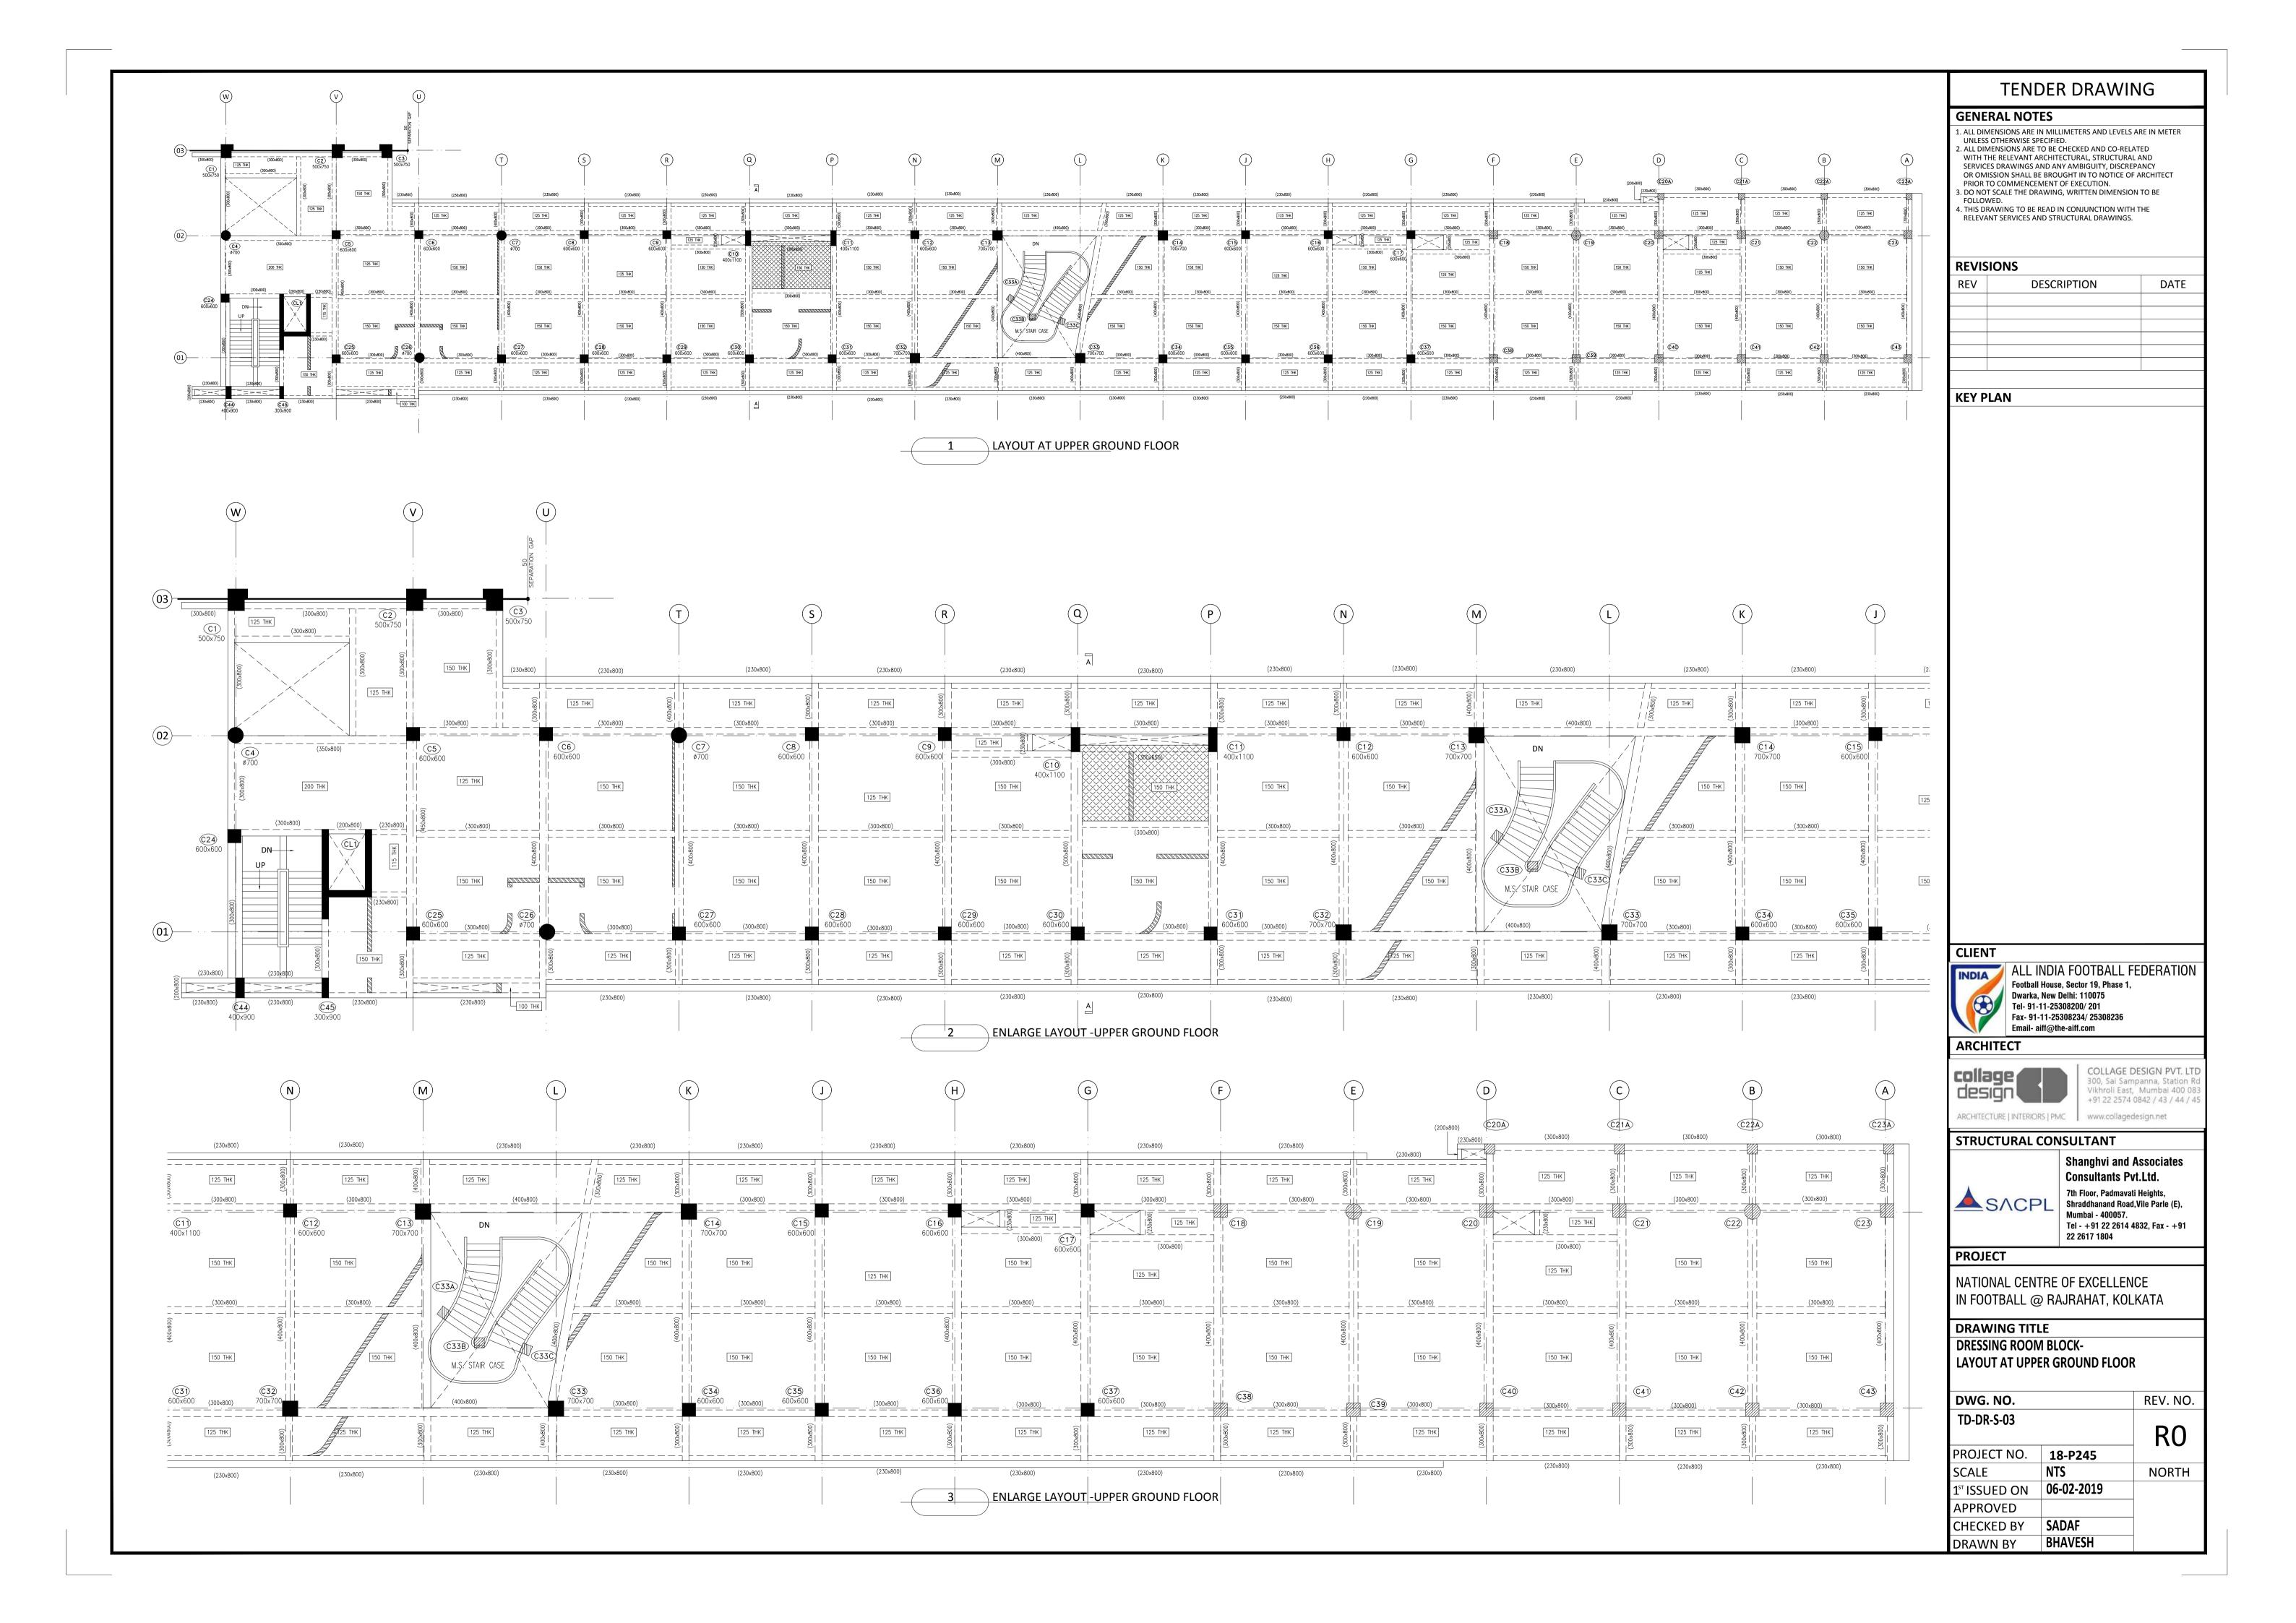


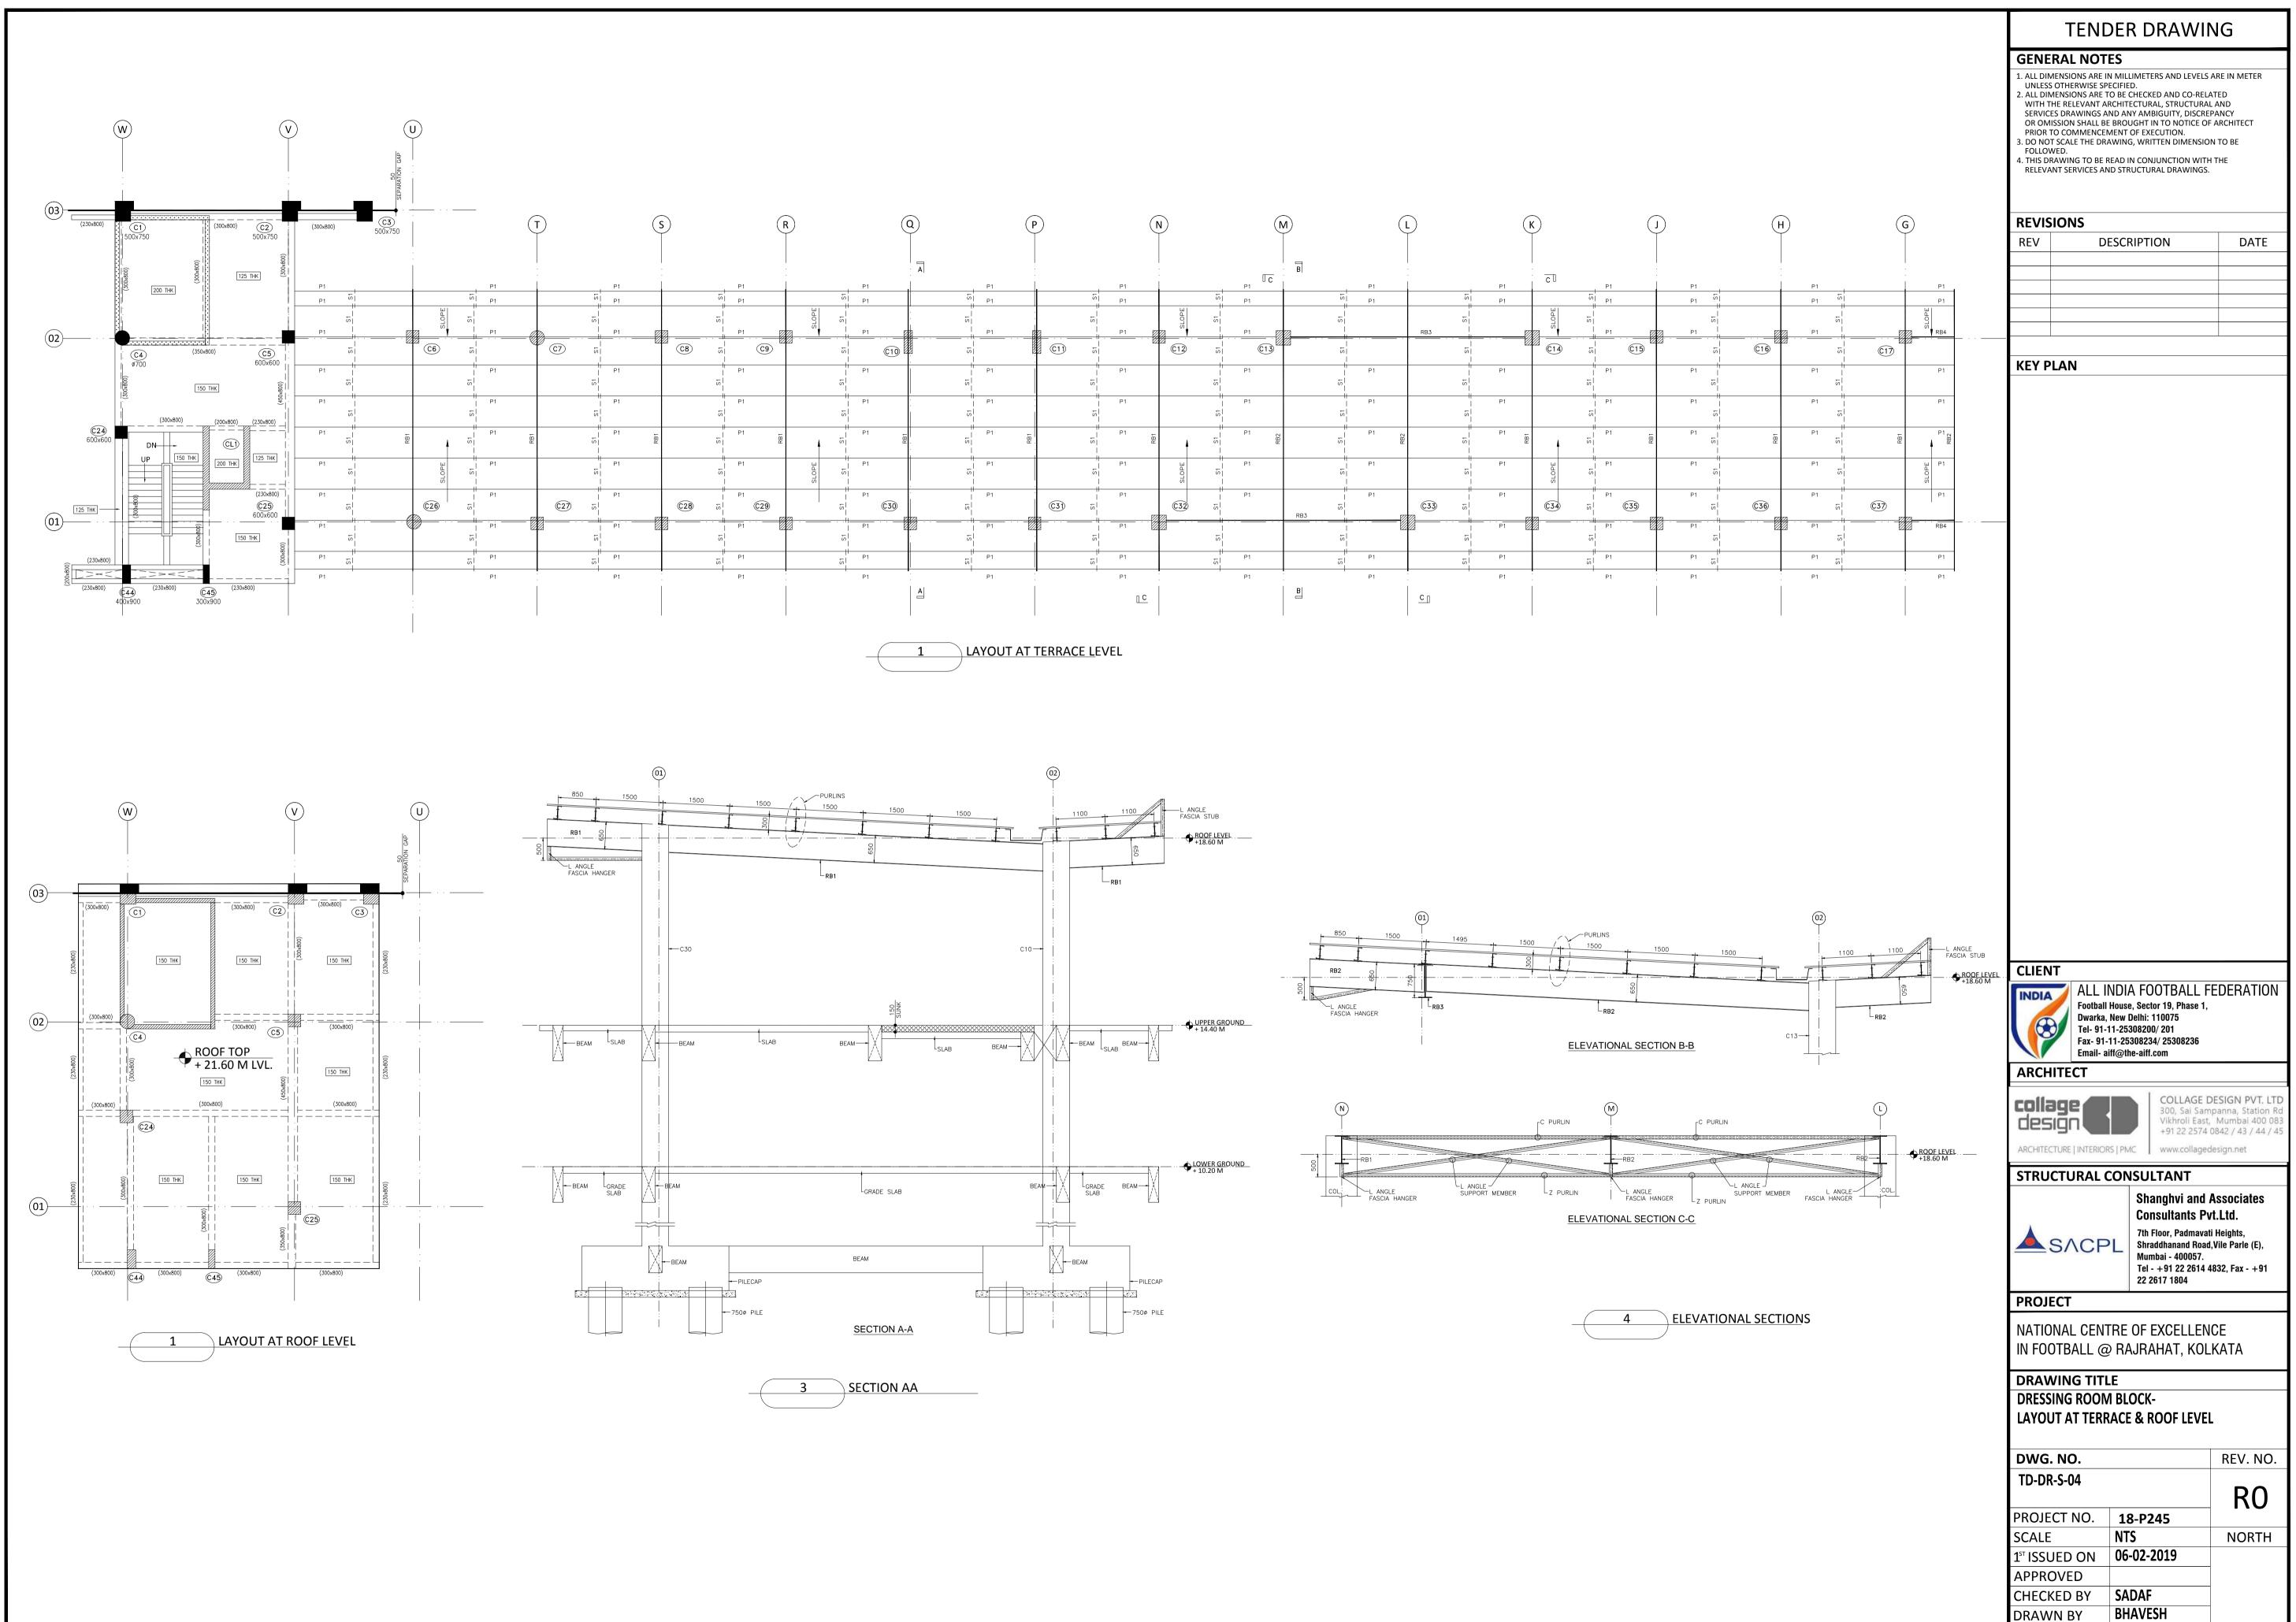


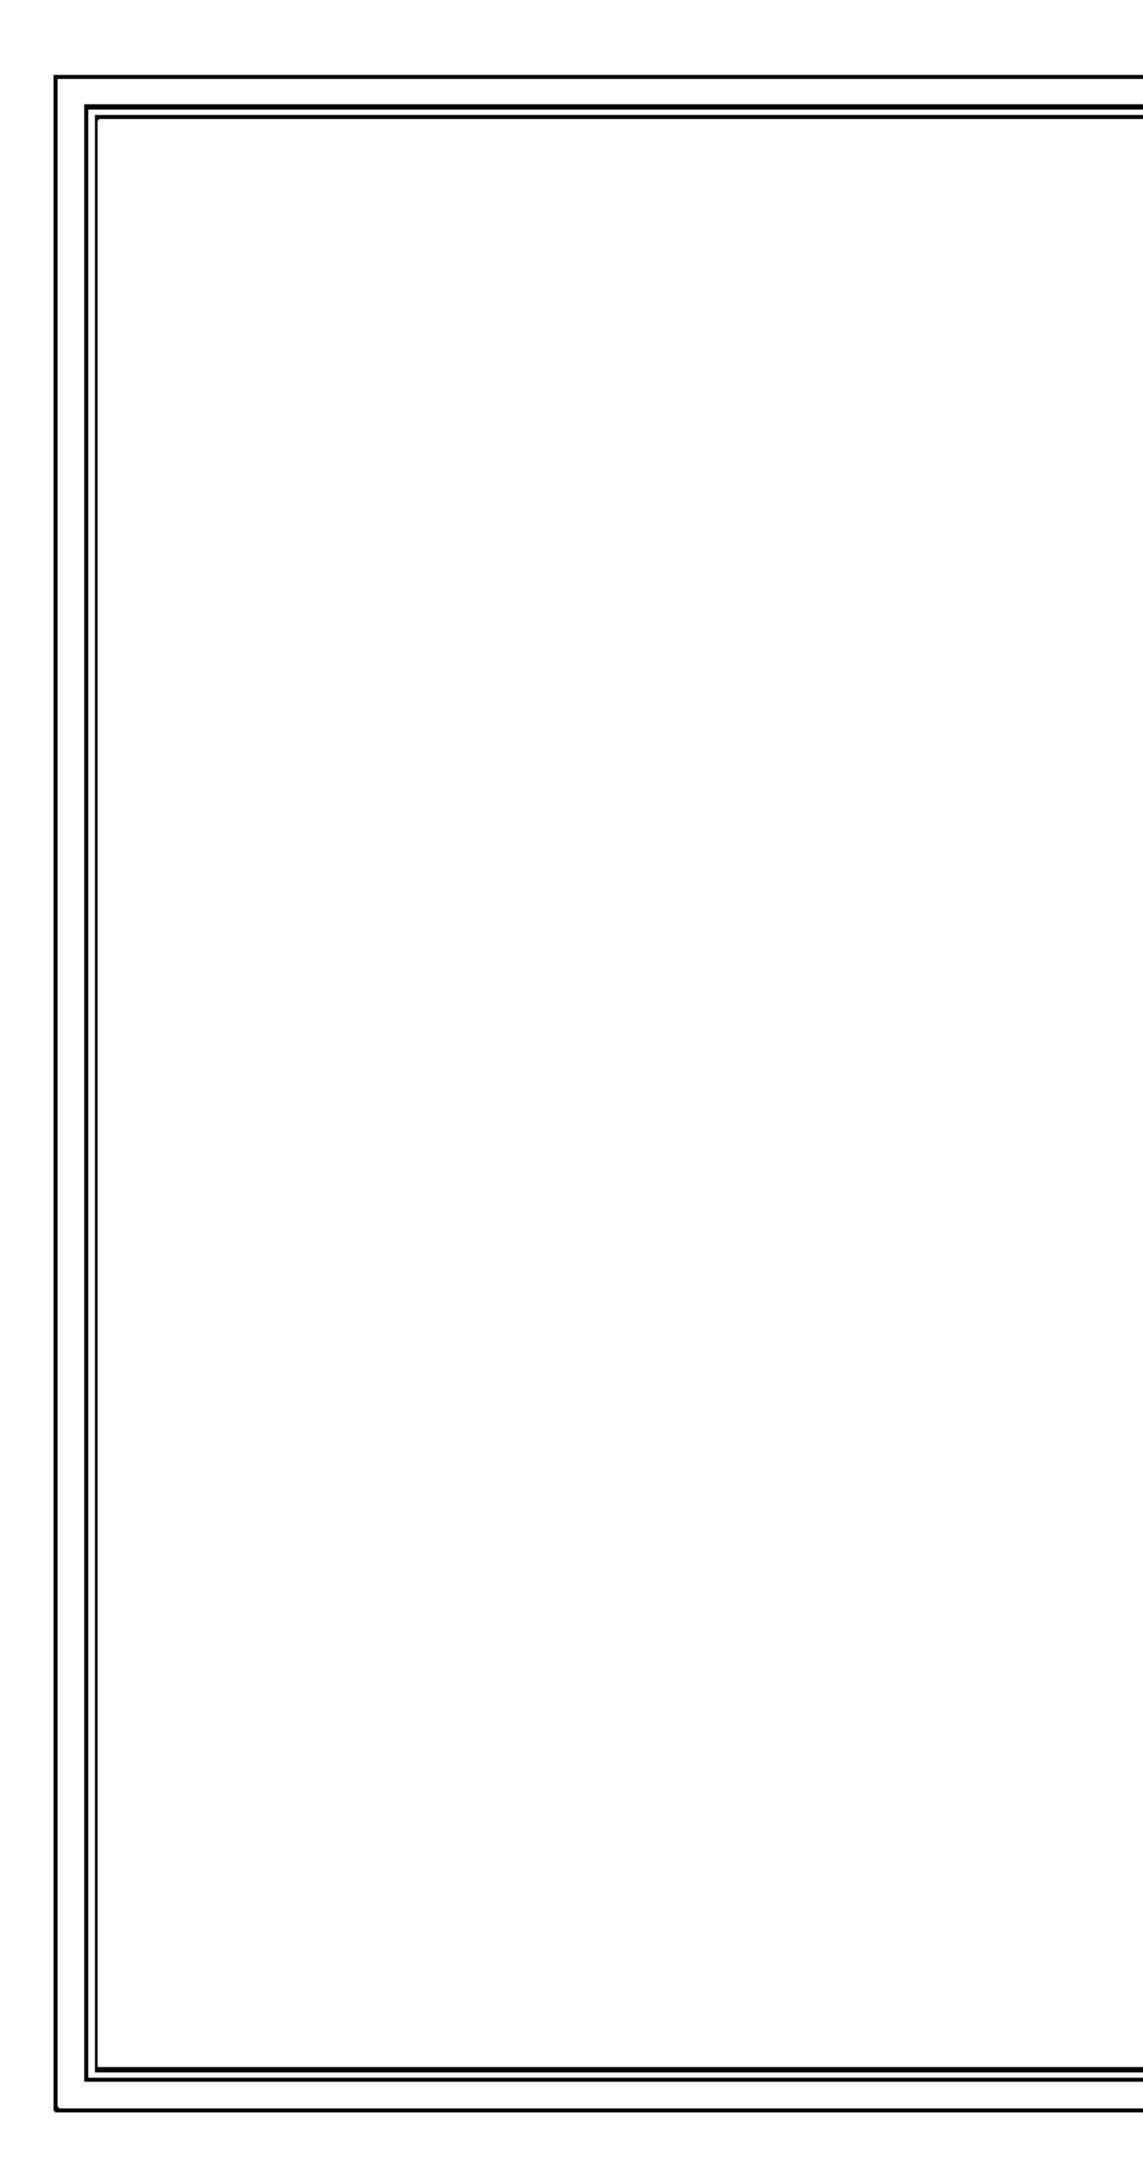



## MEP DRAWINGS

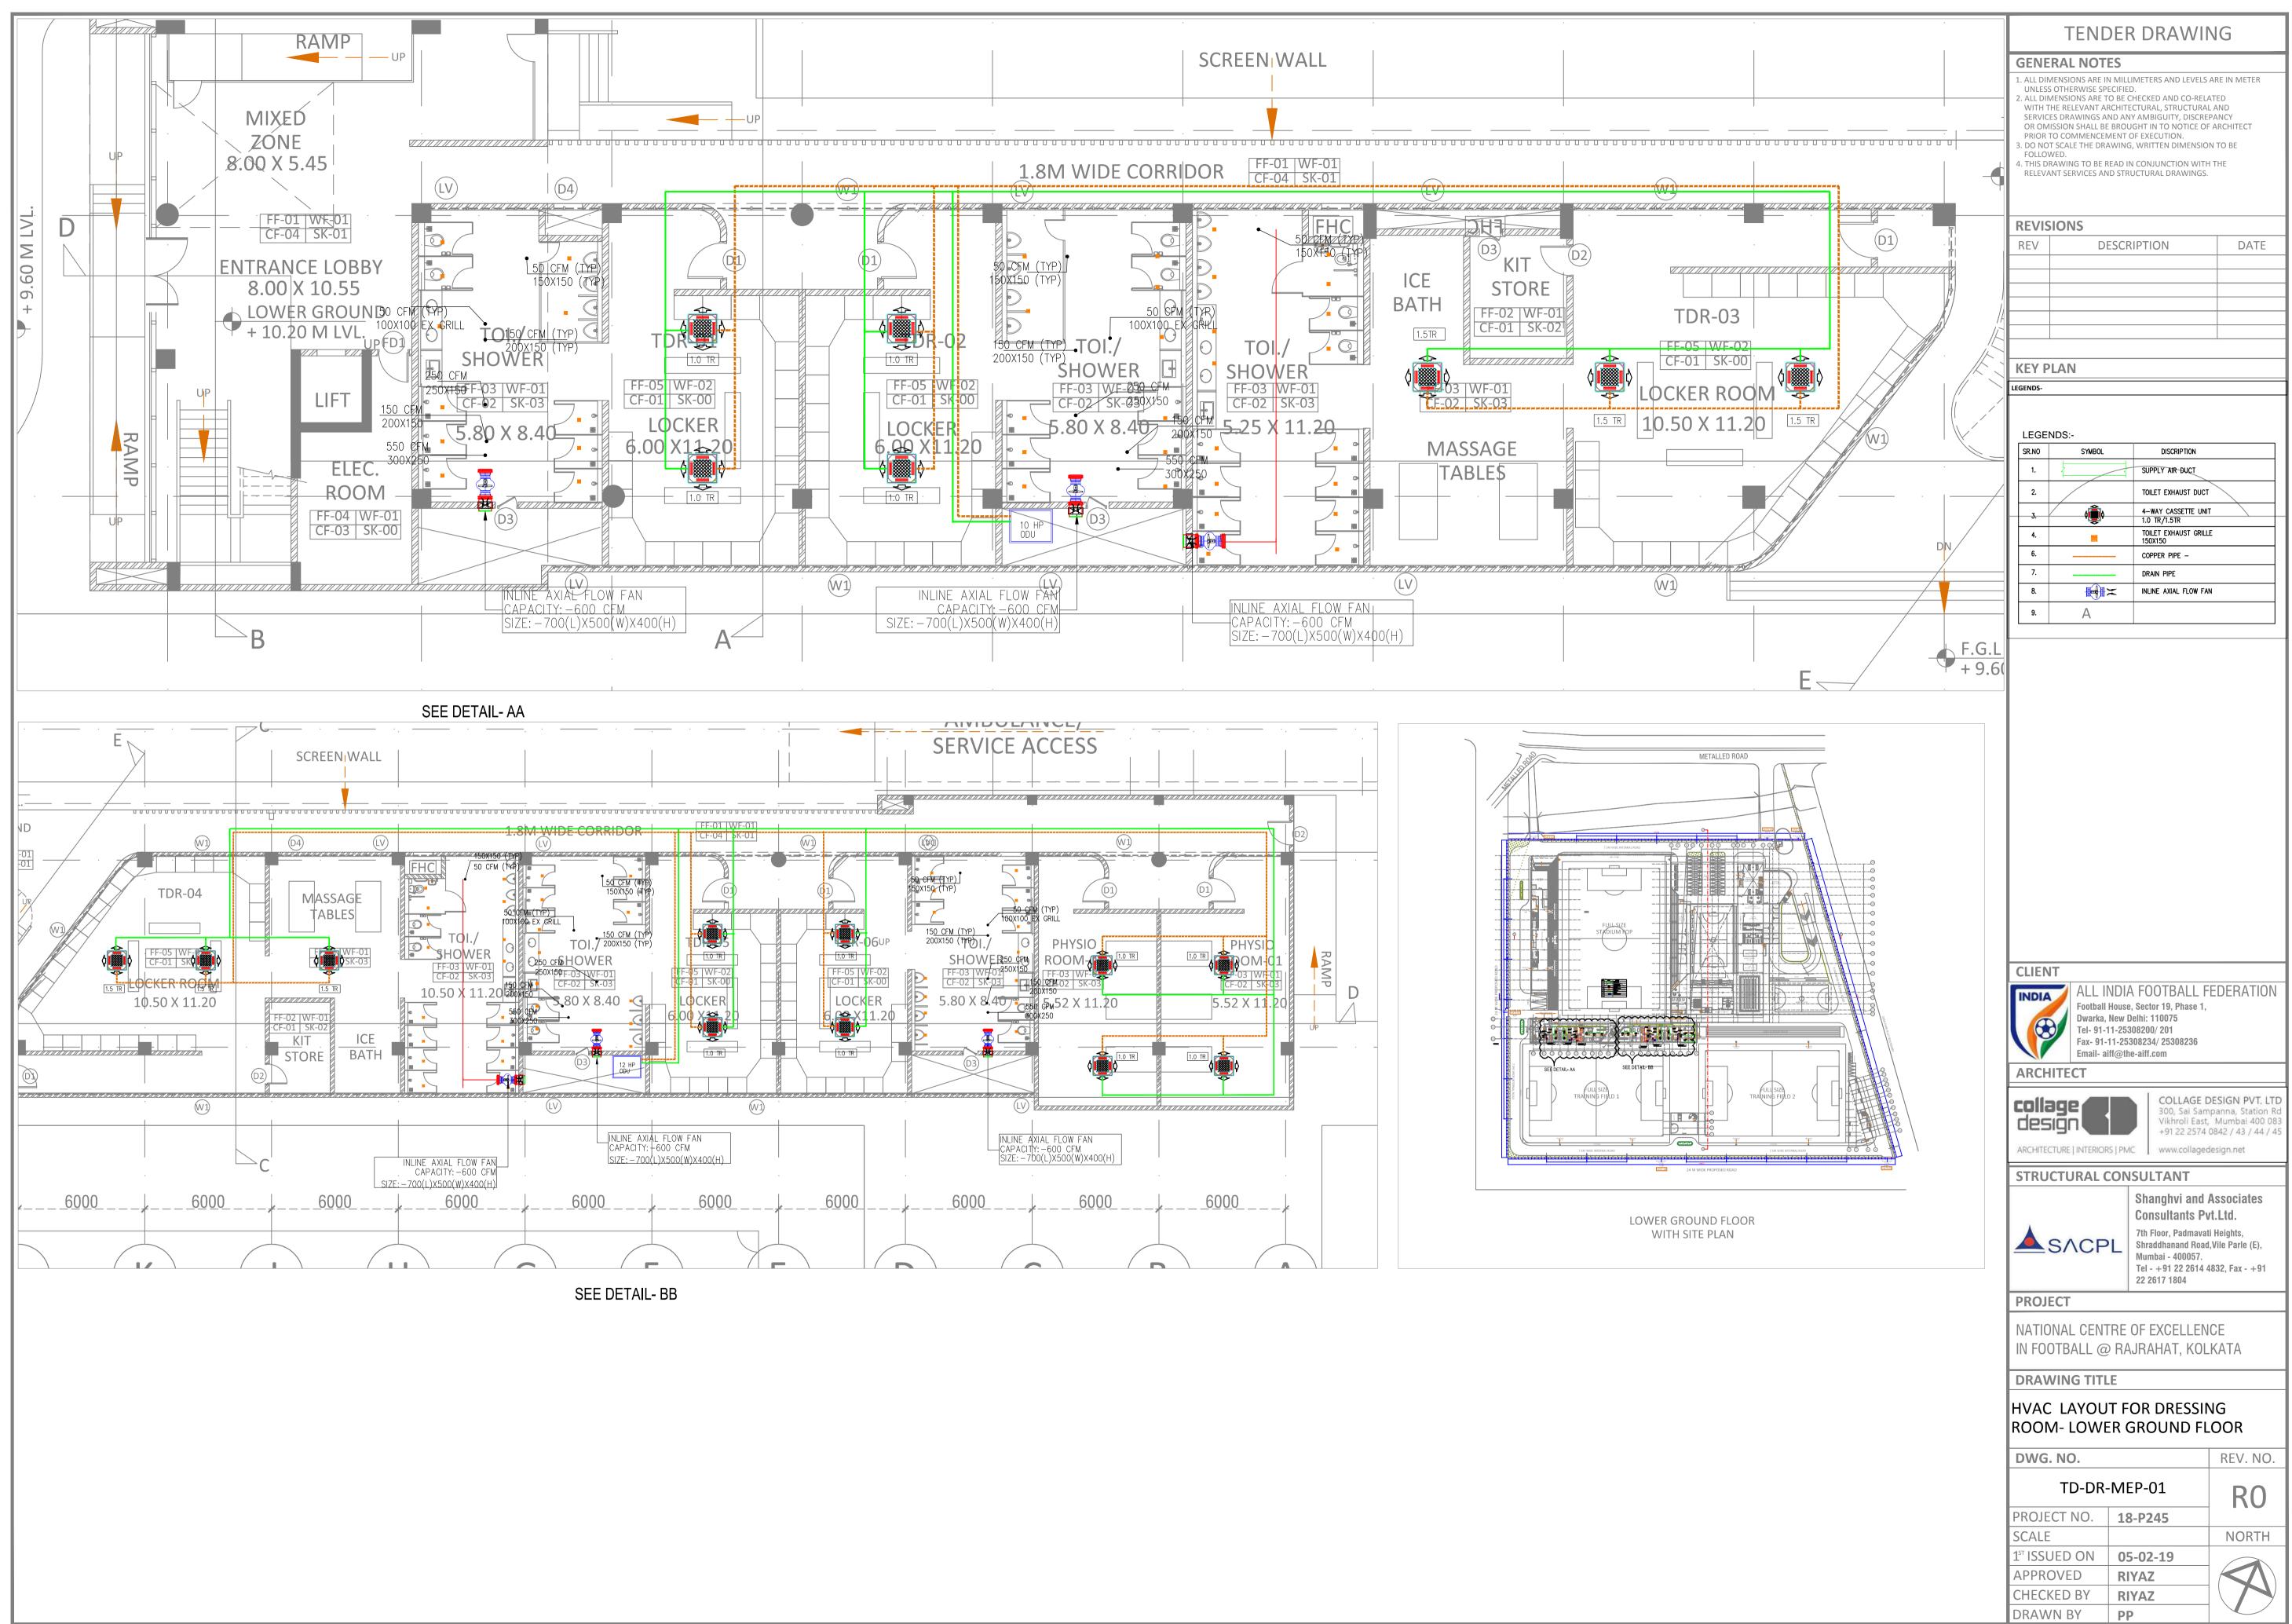


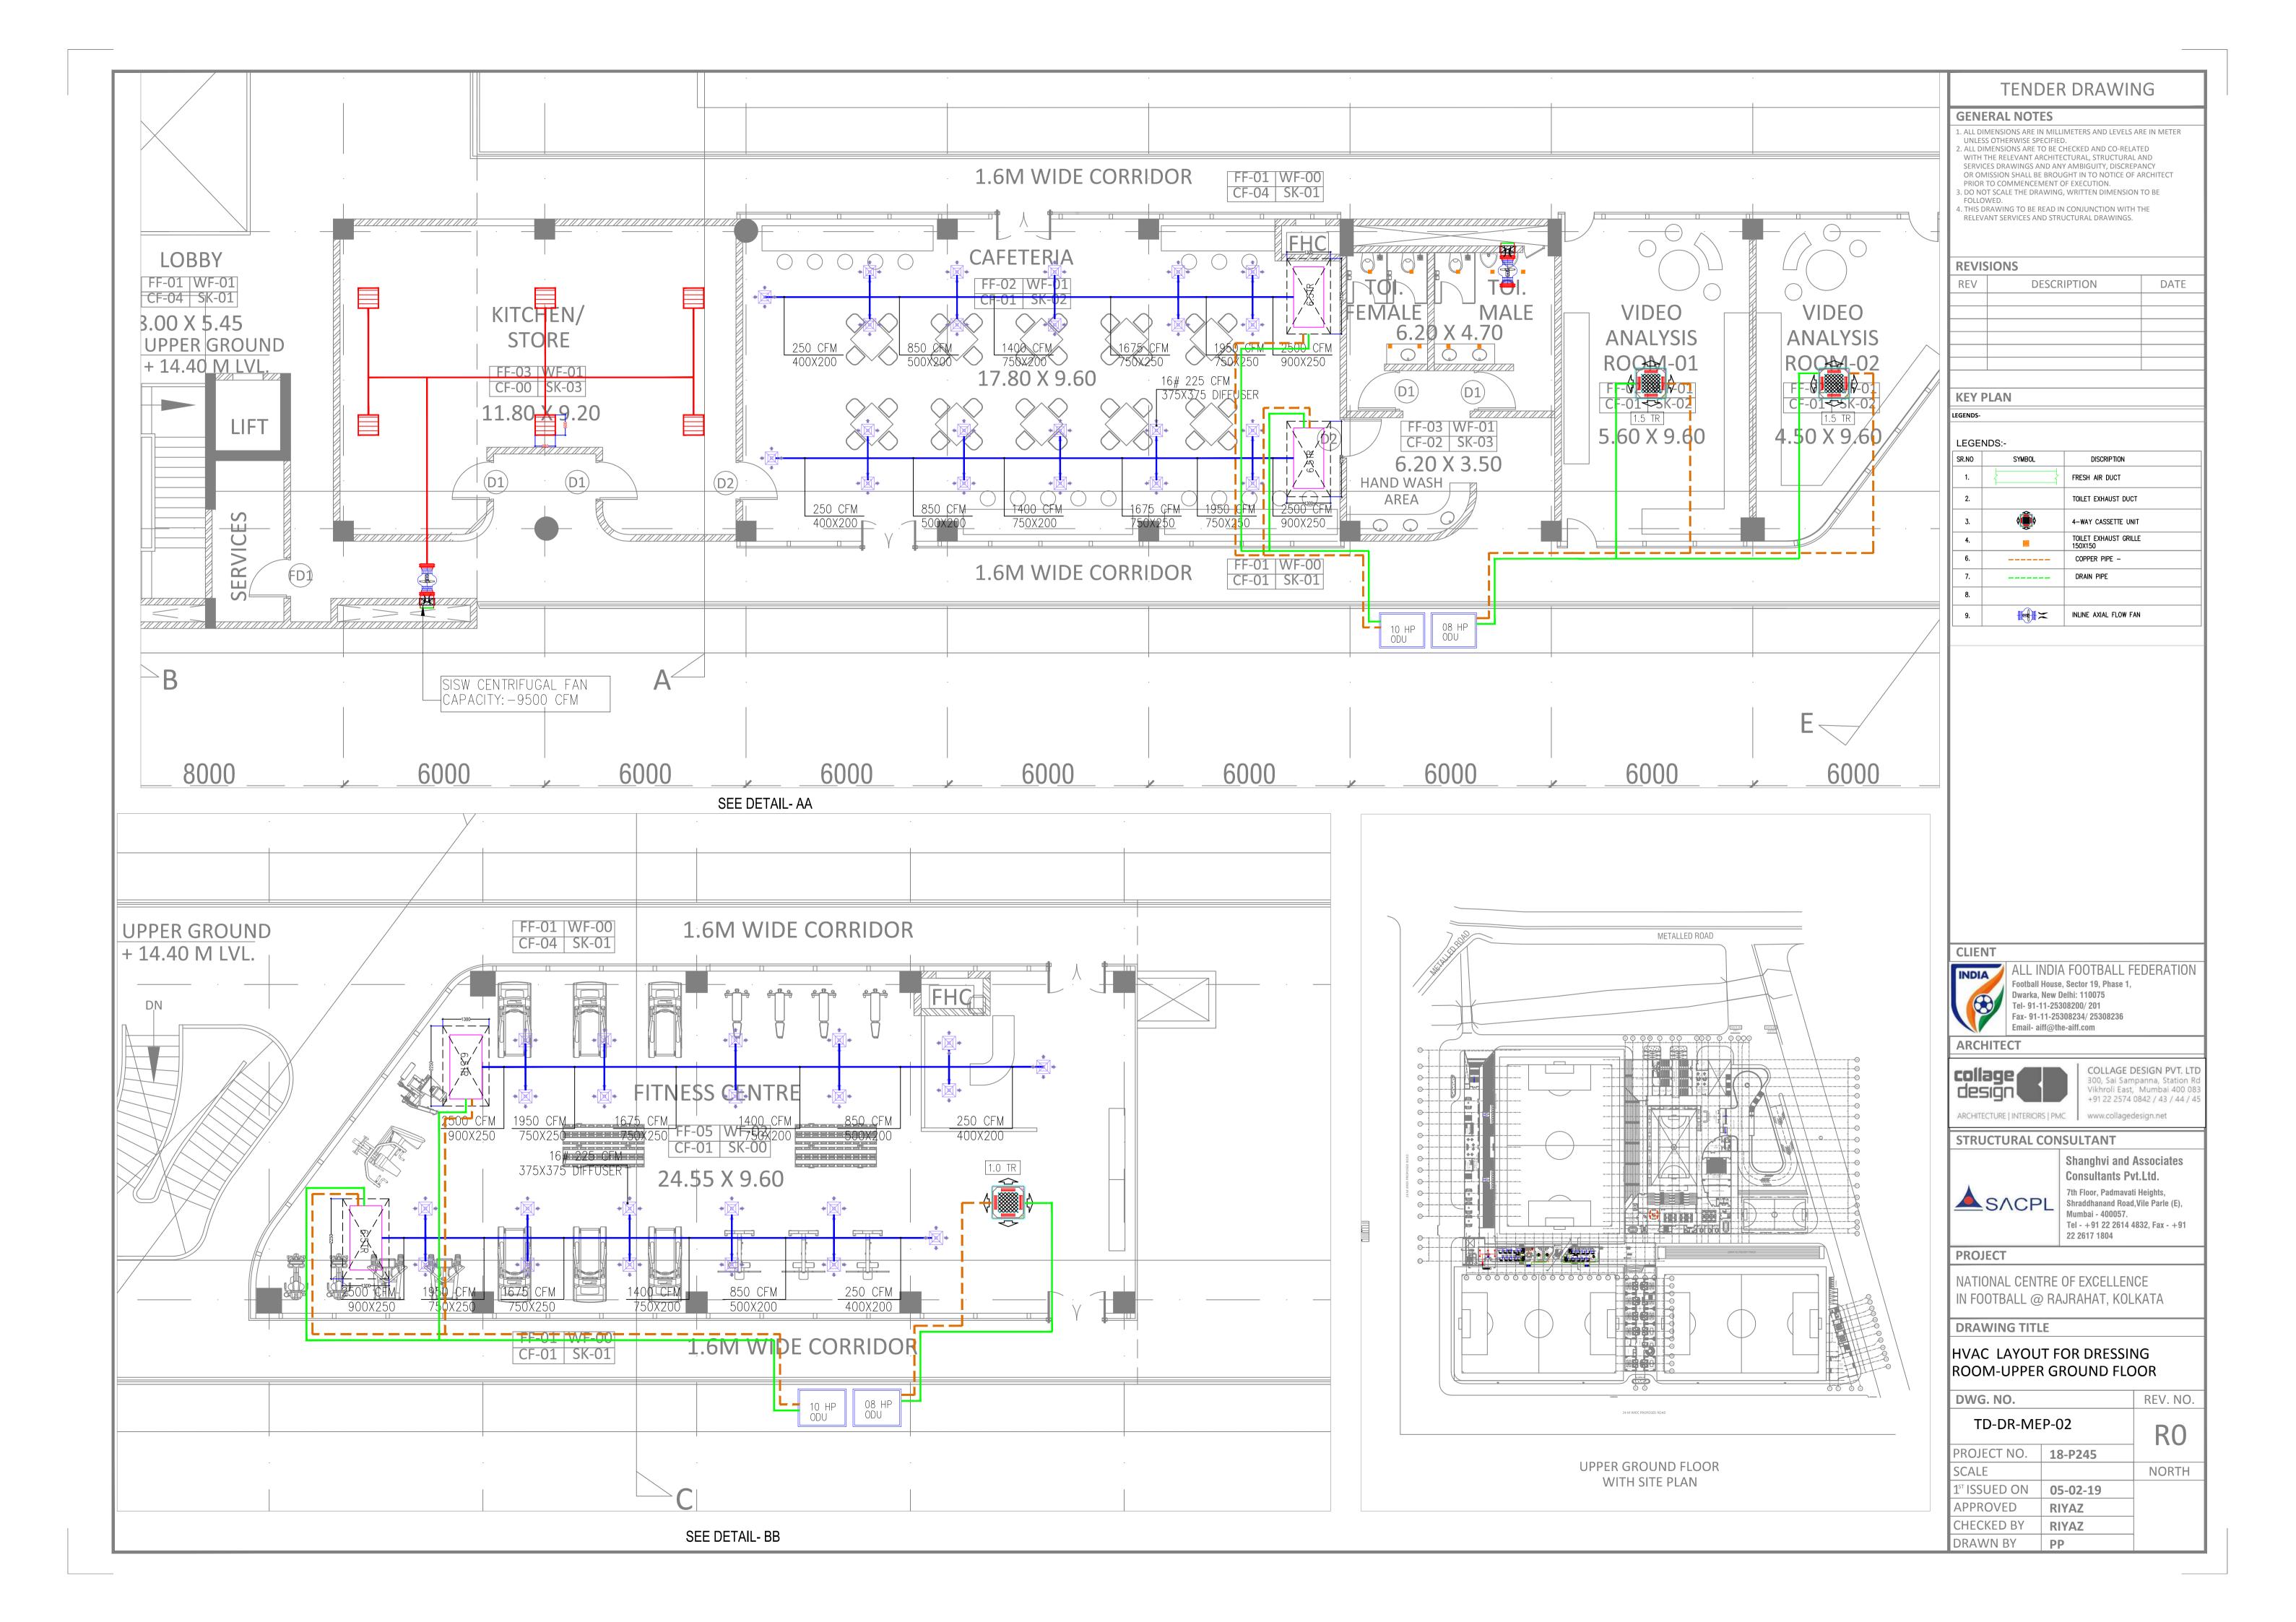


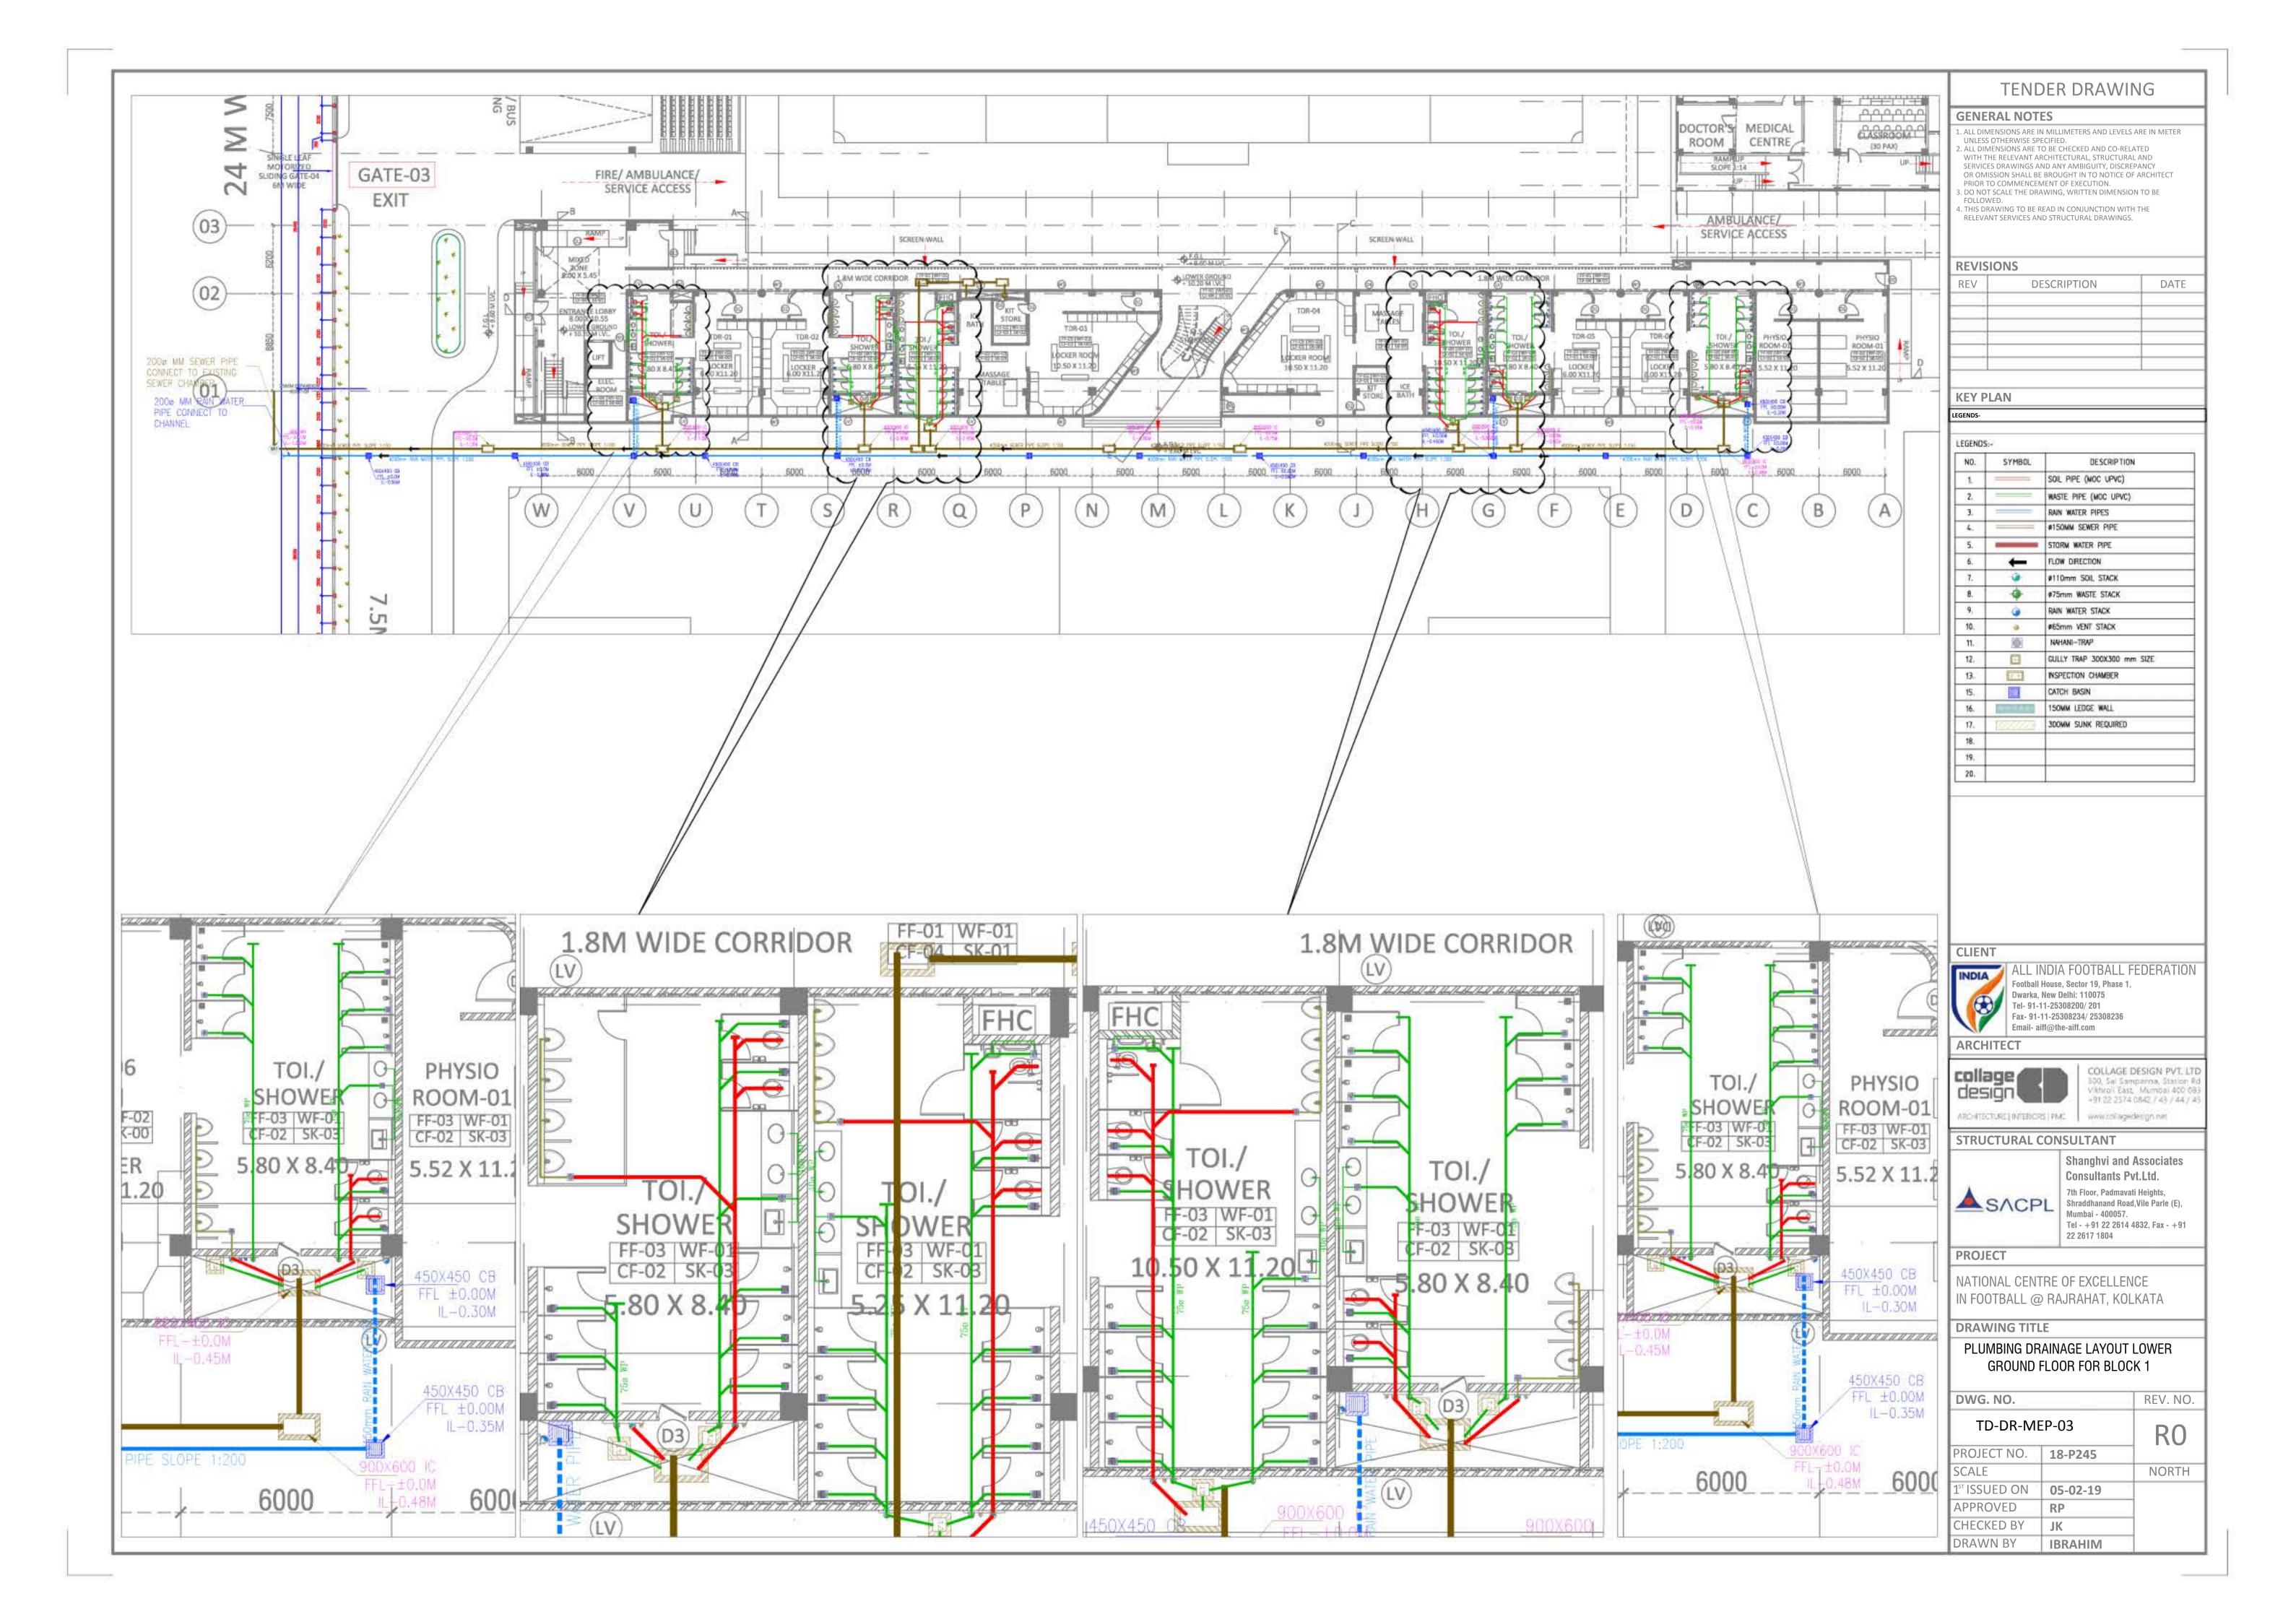


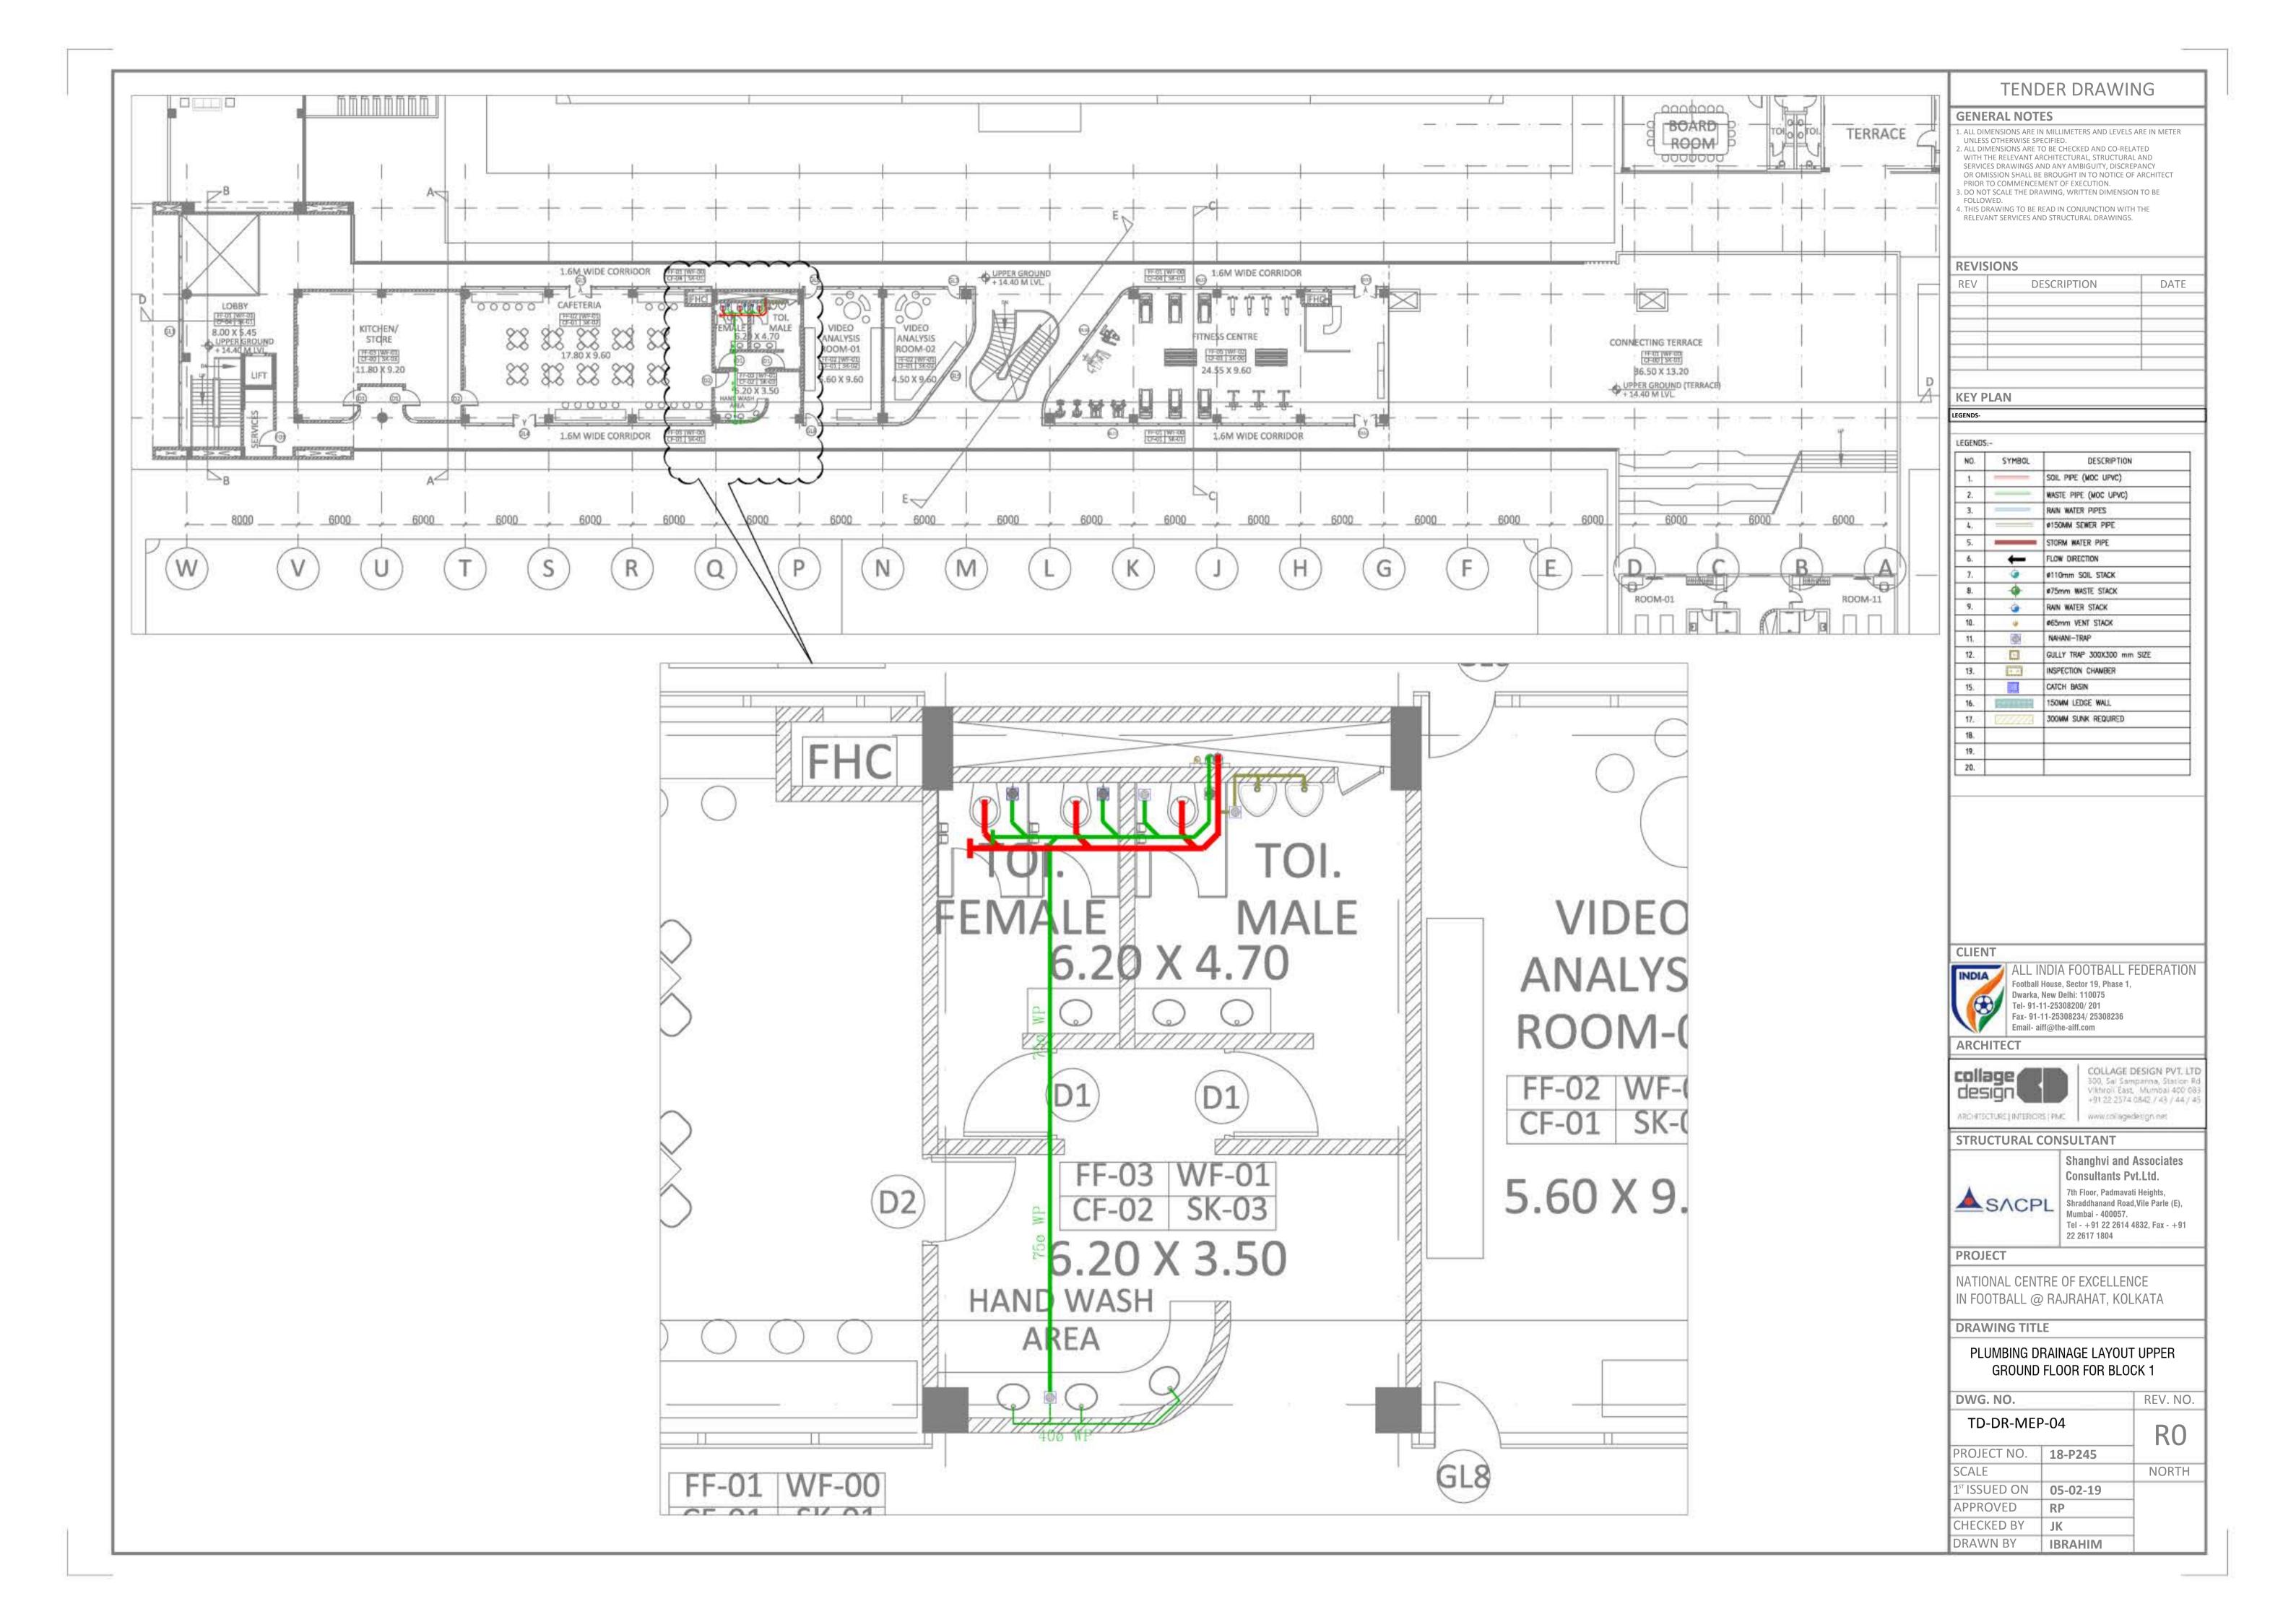


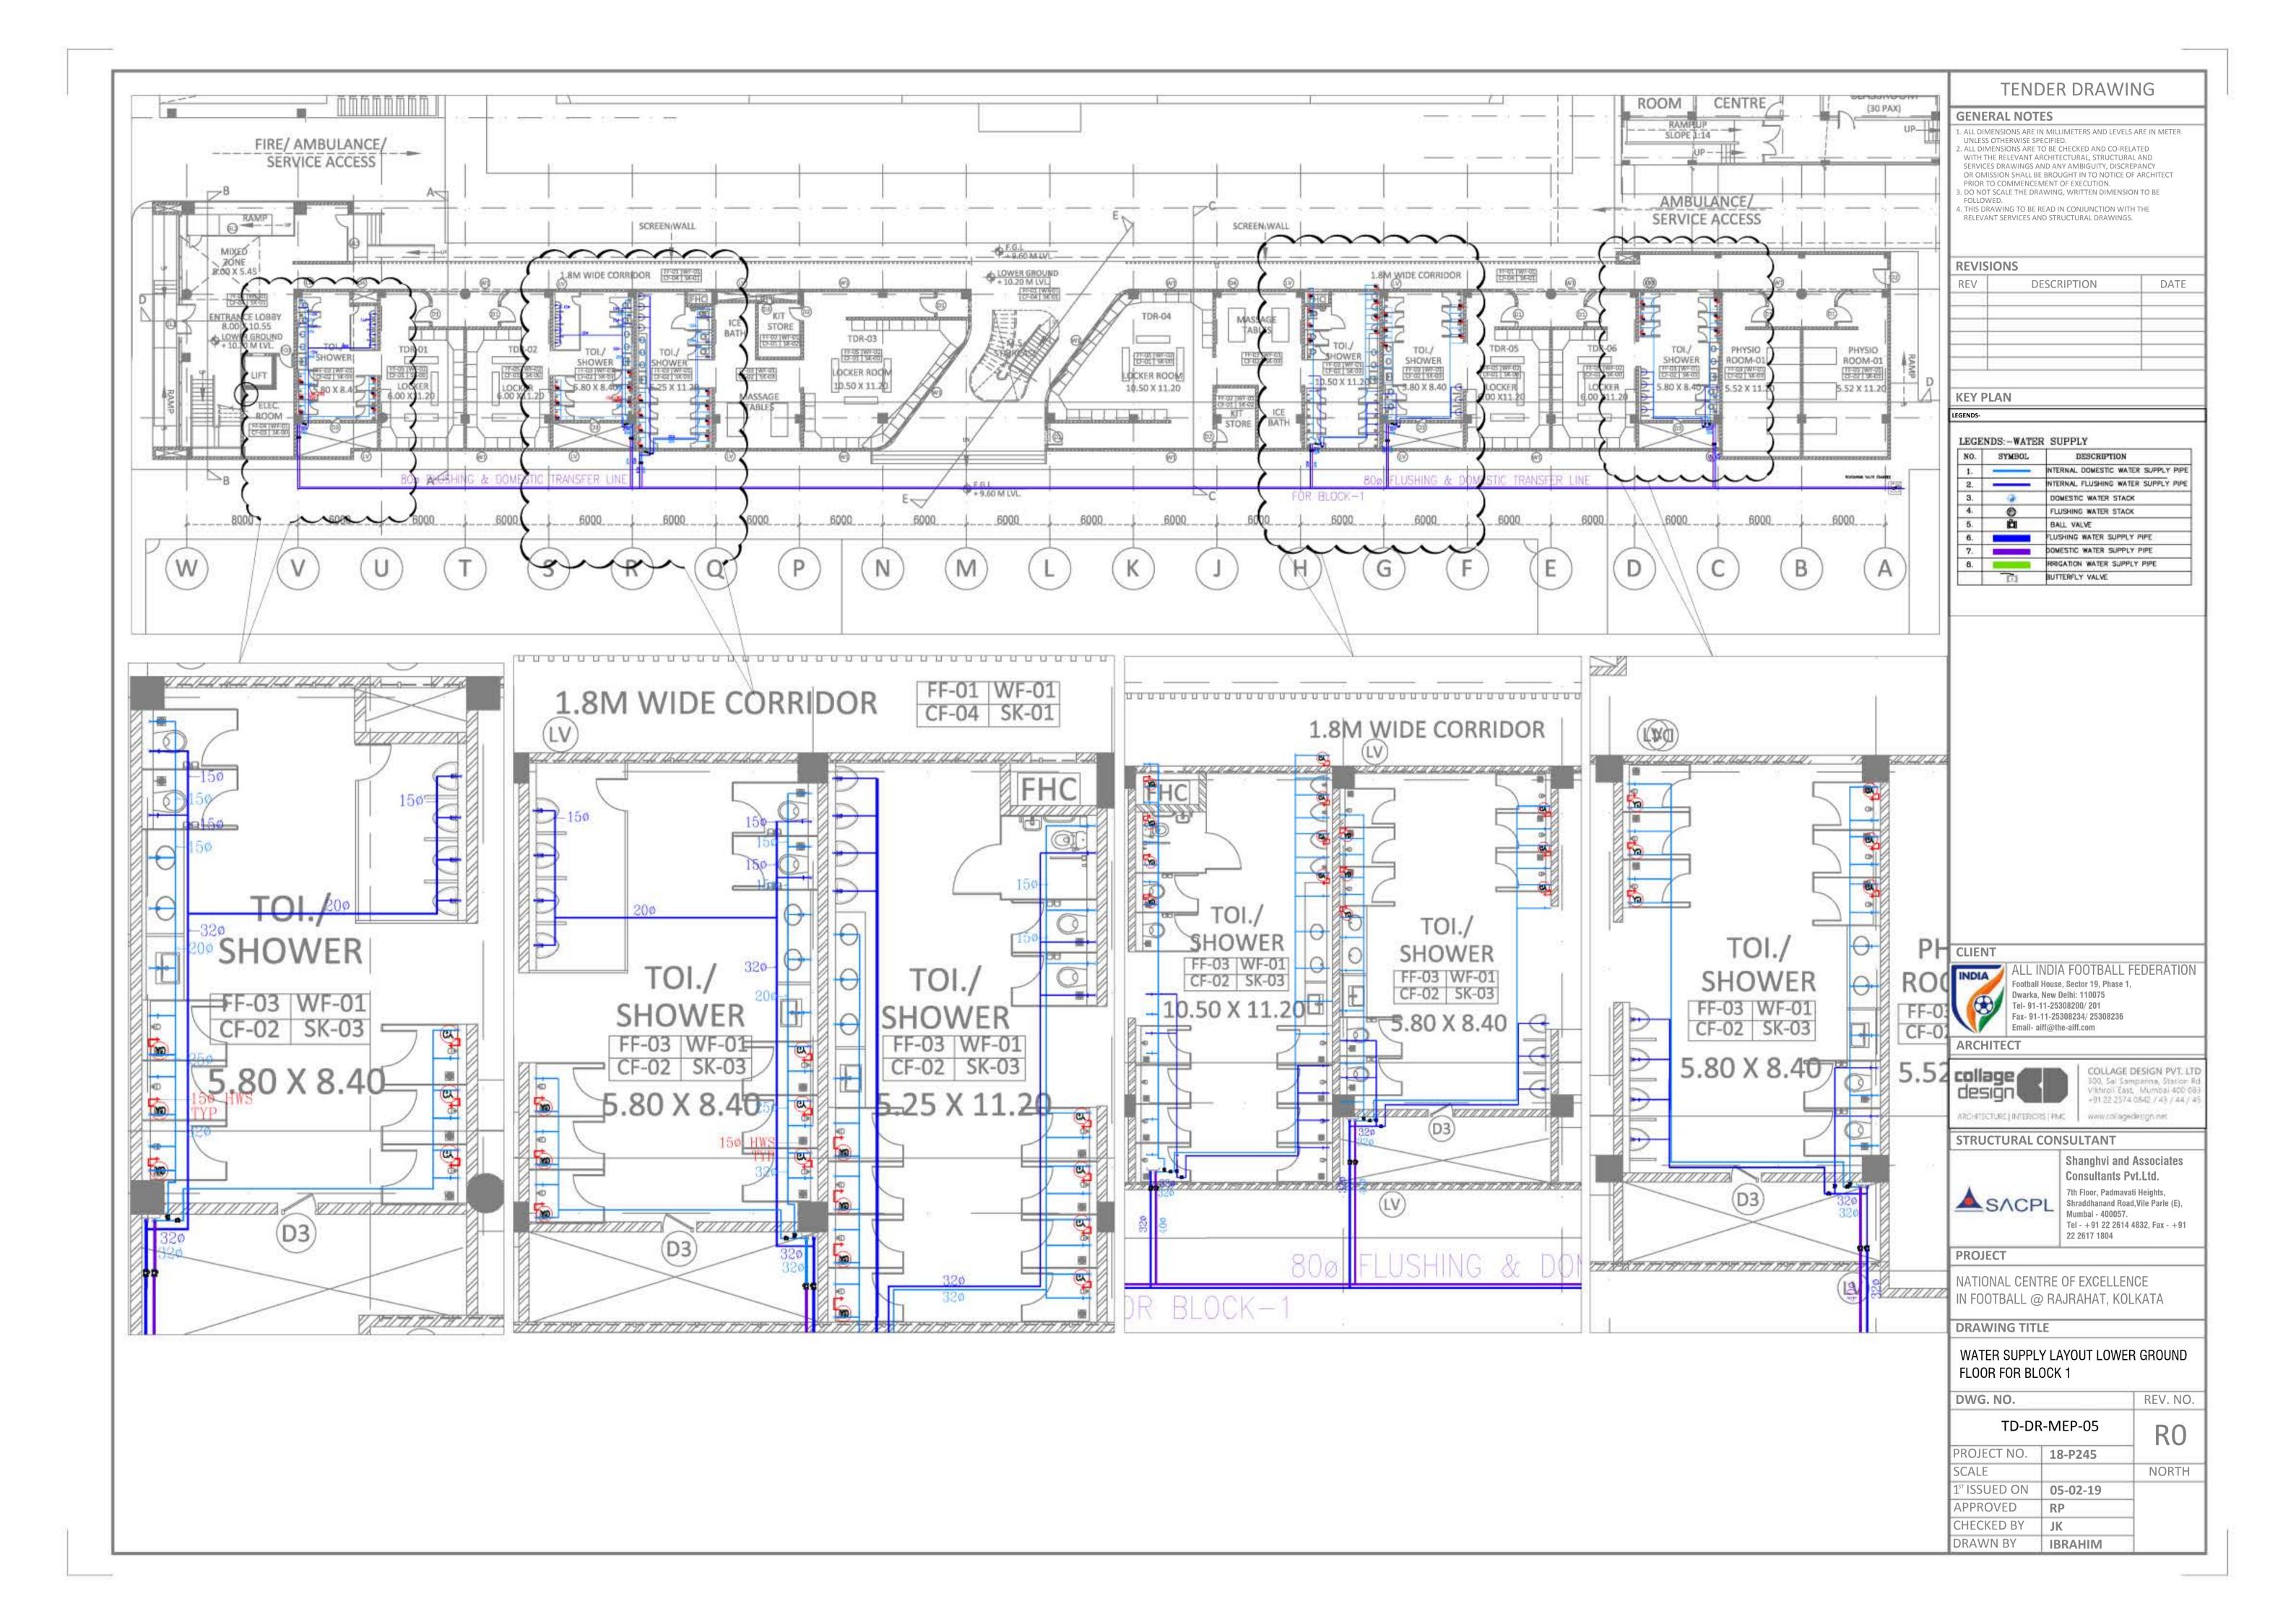


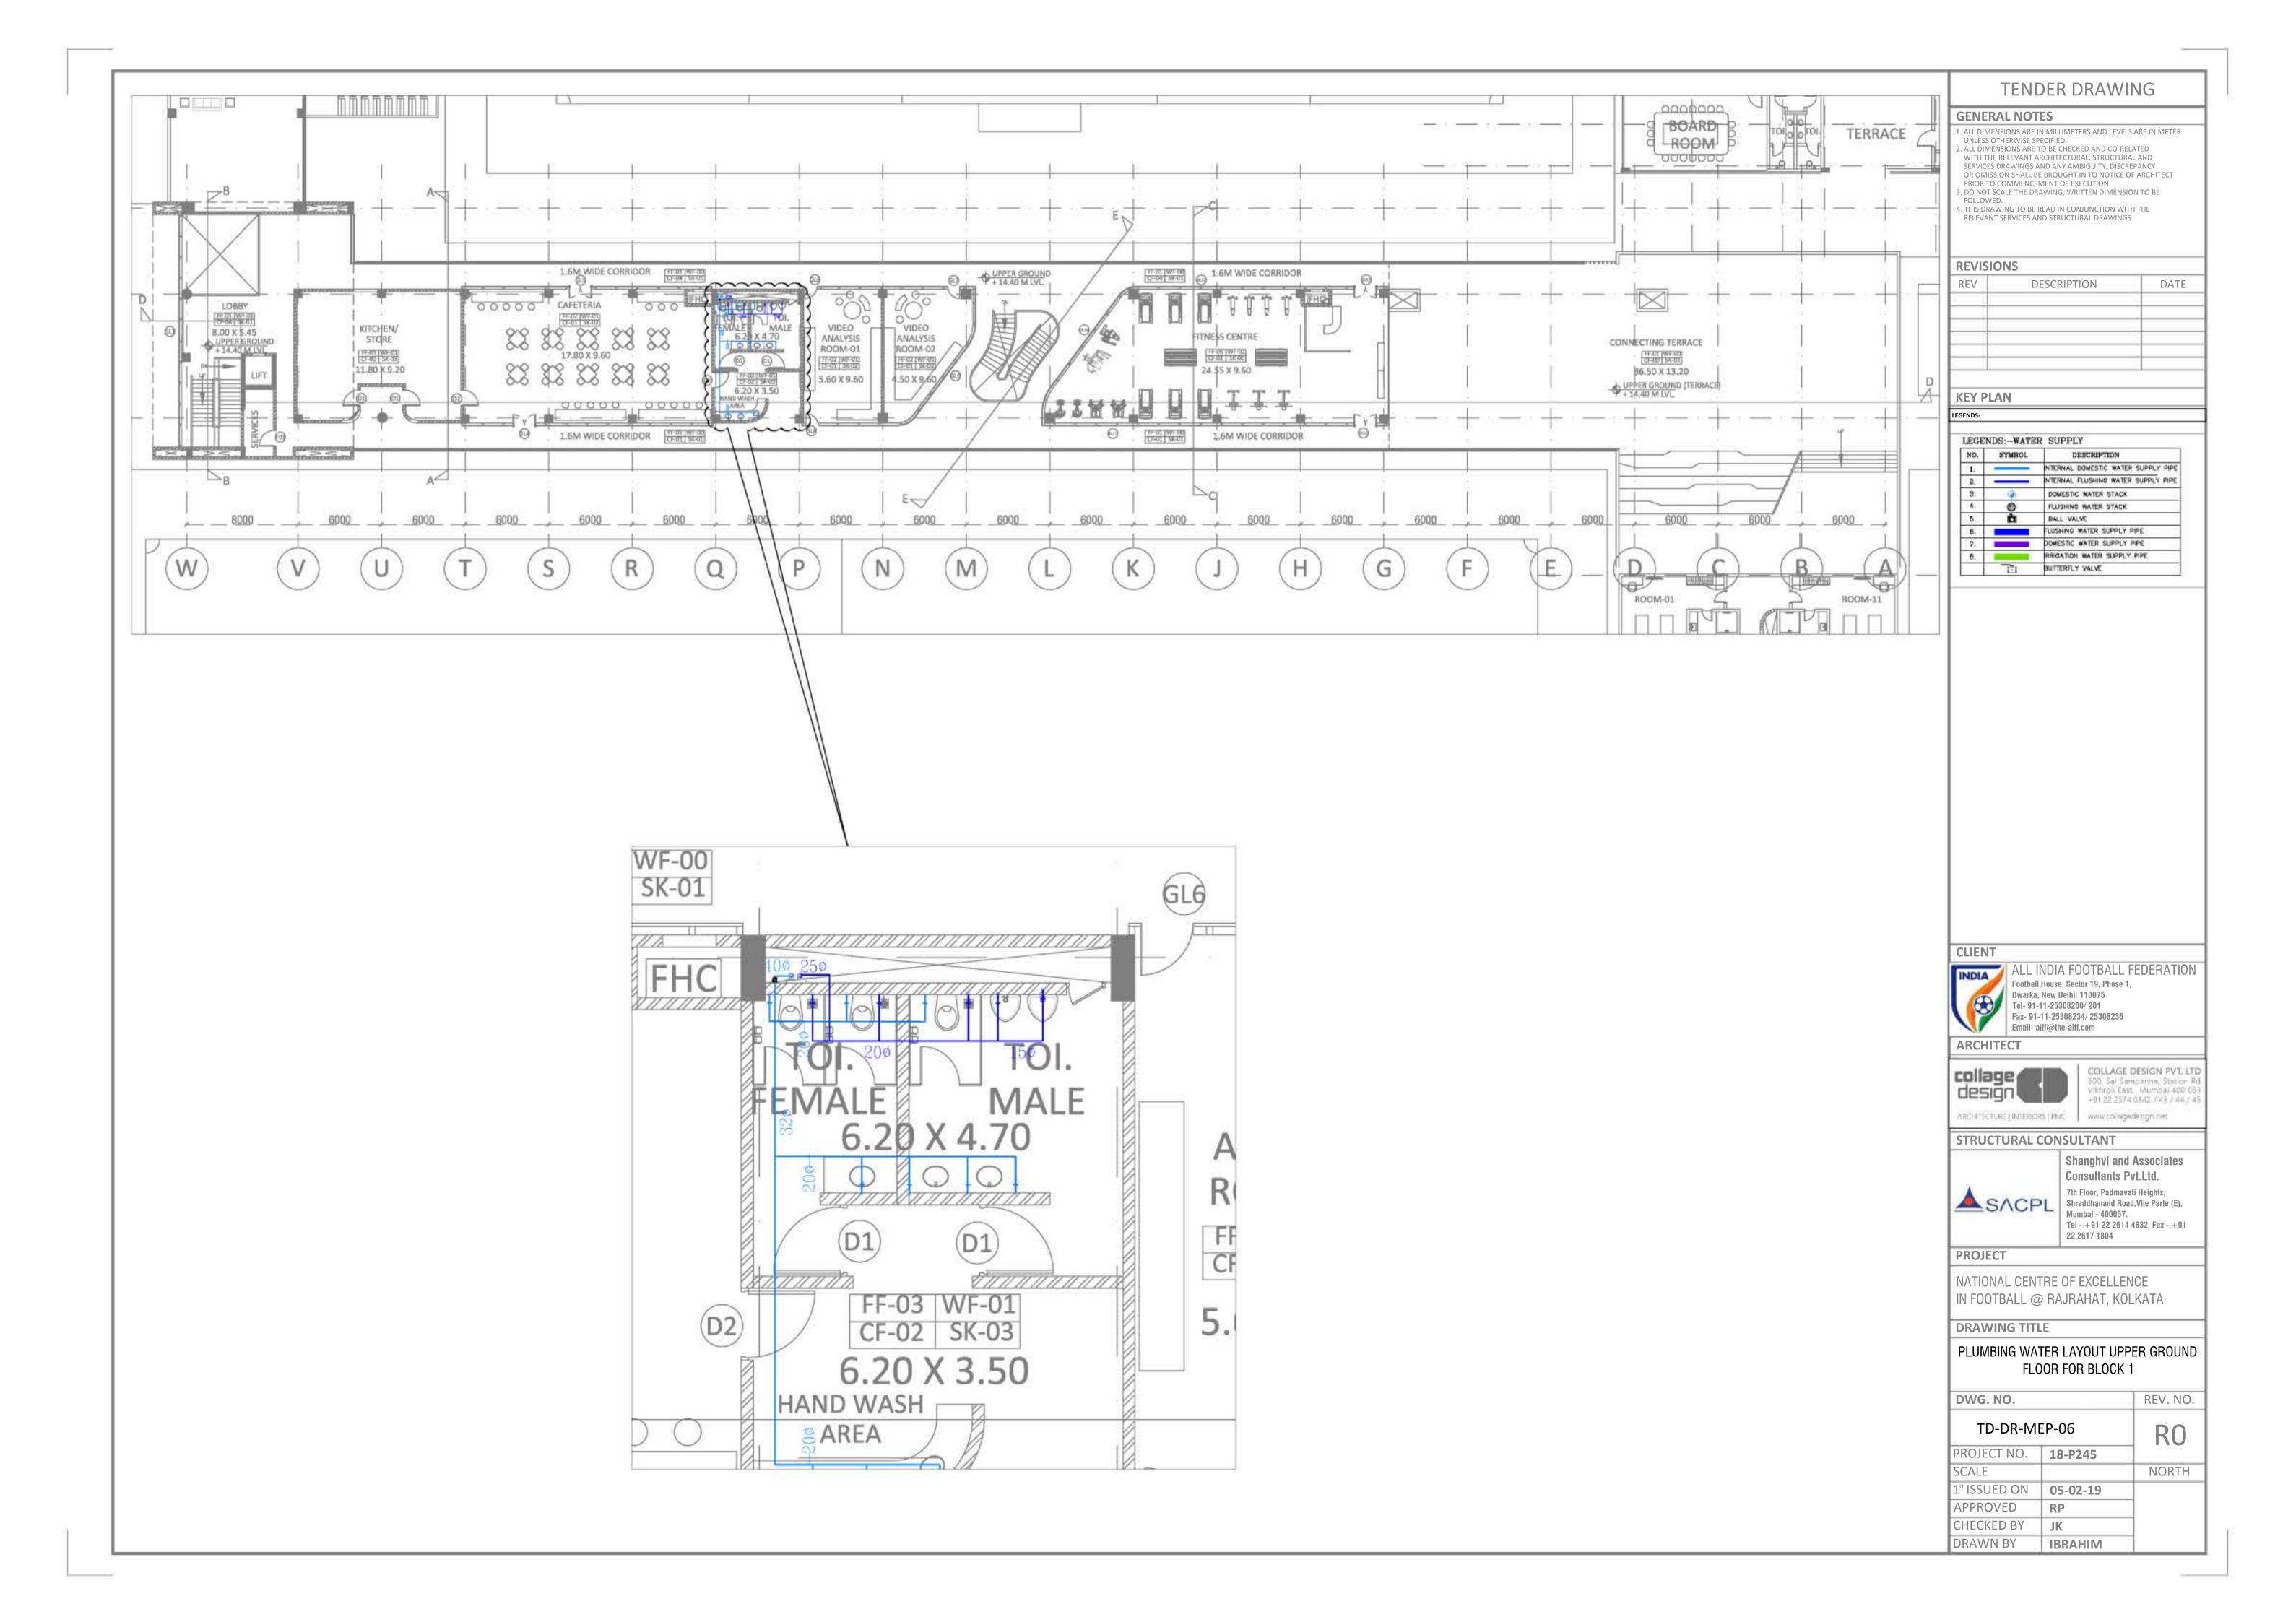


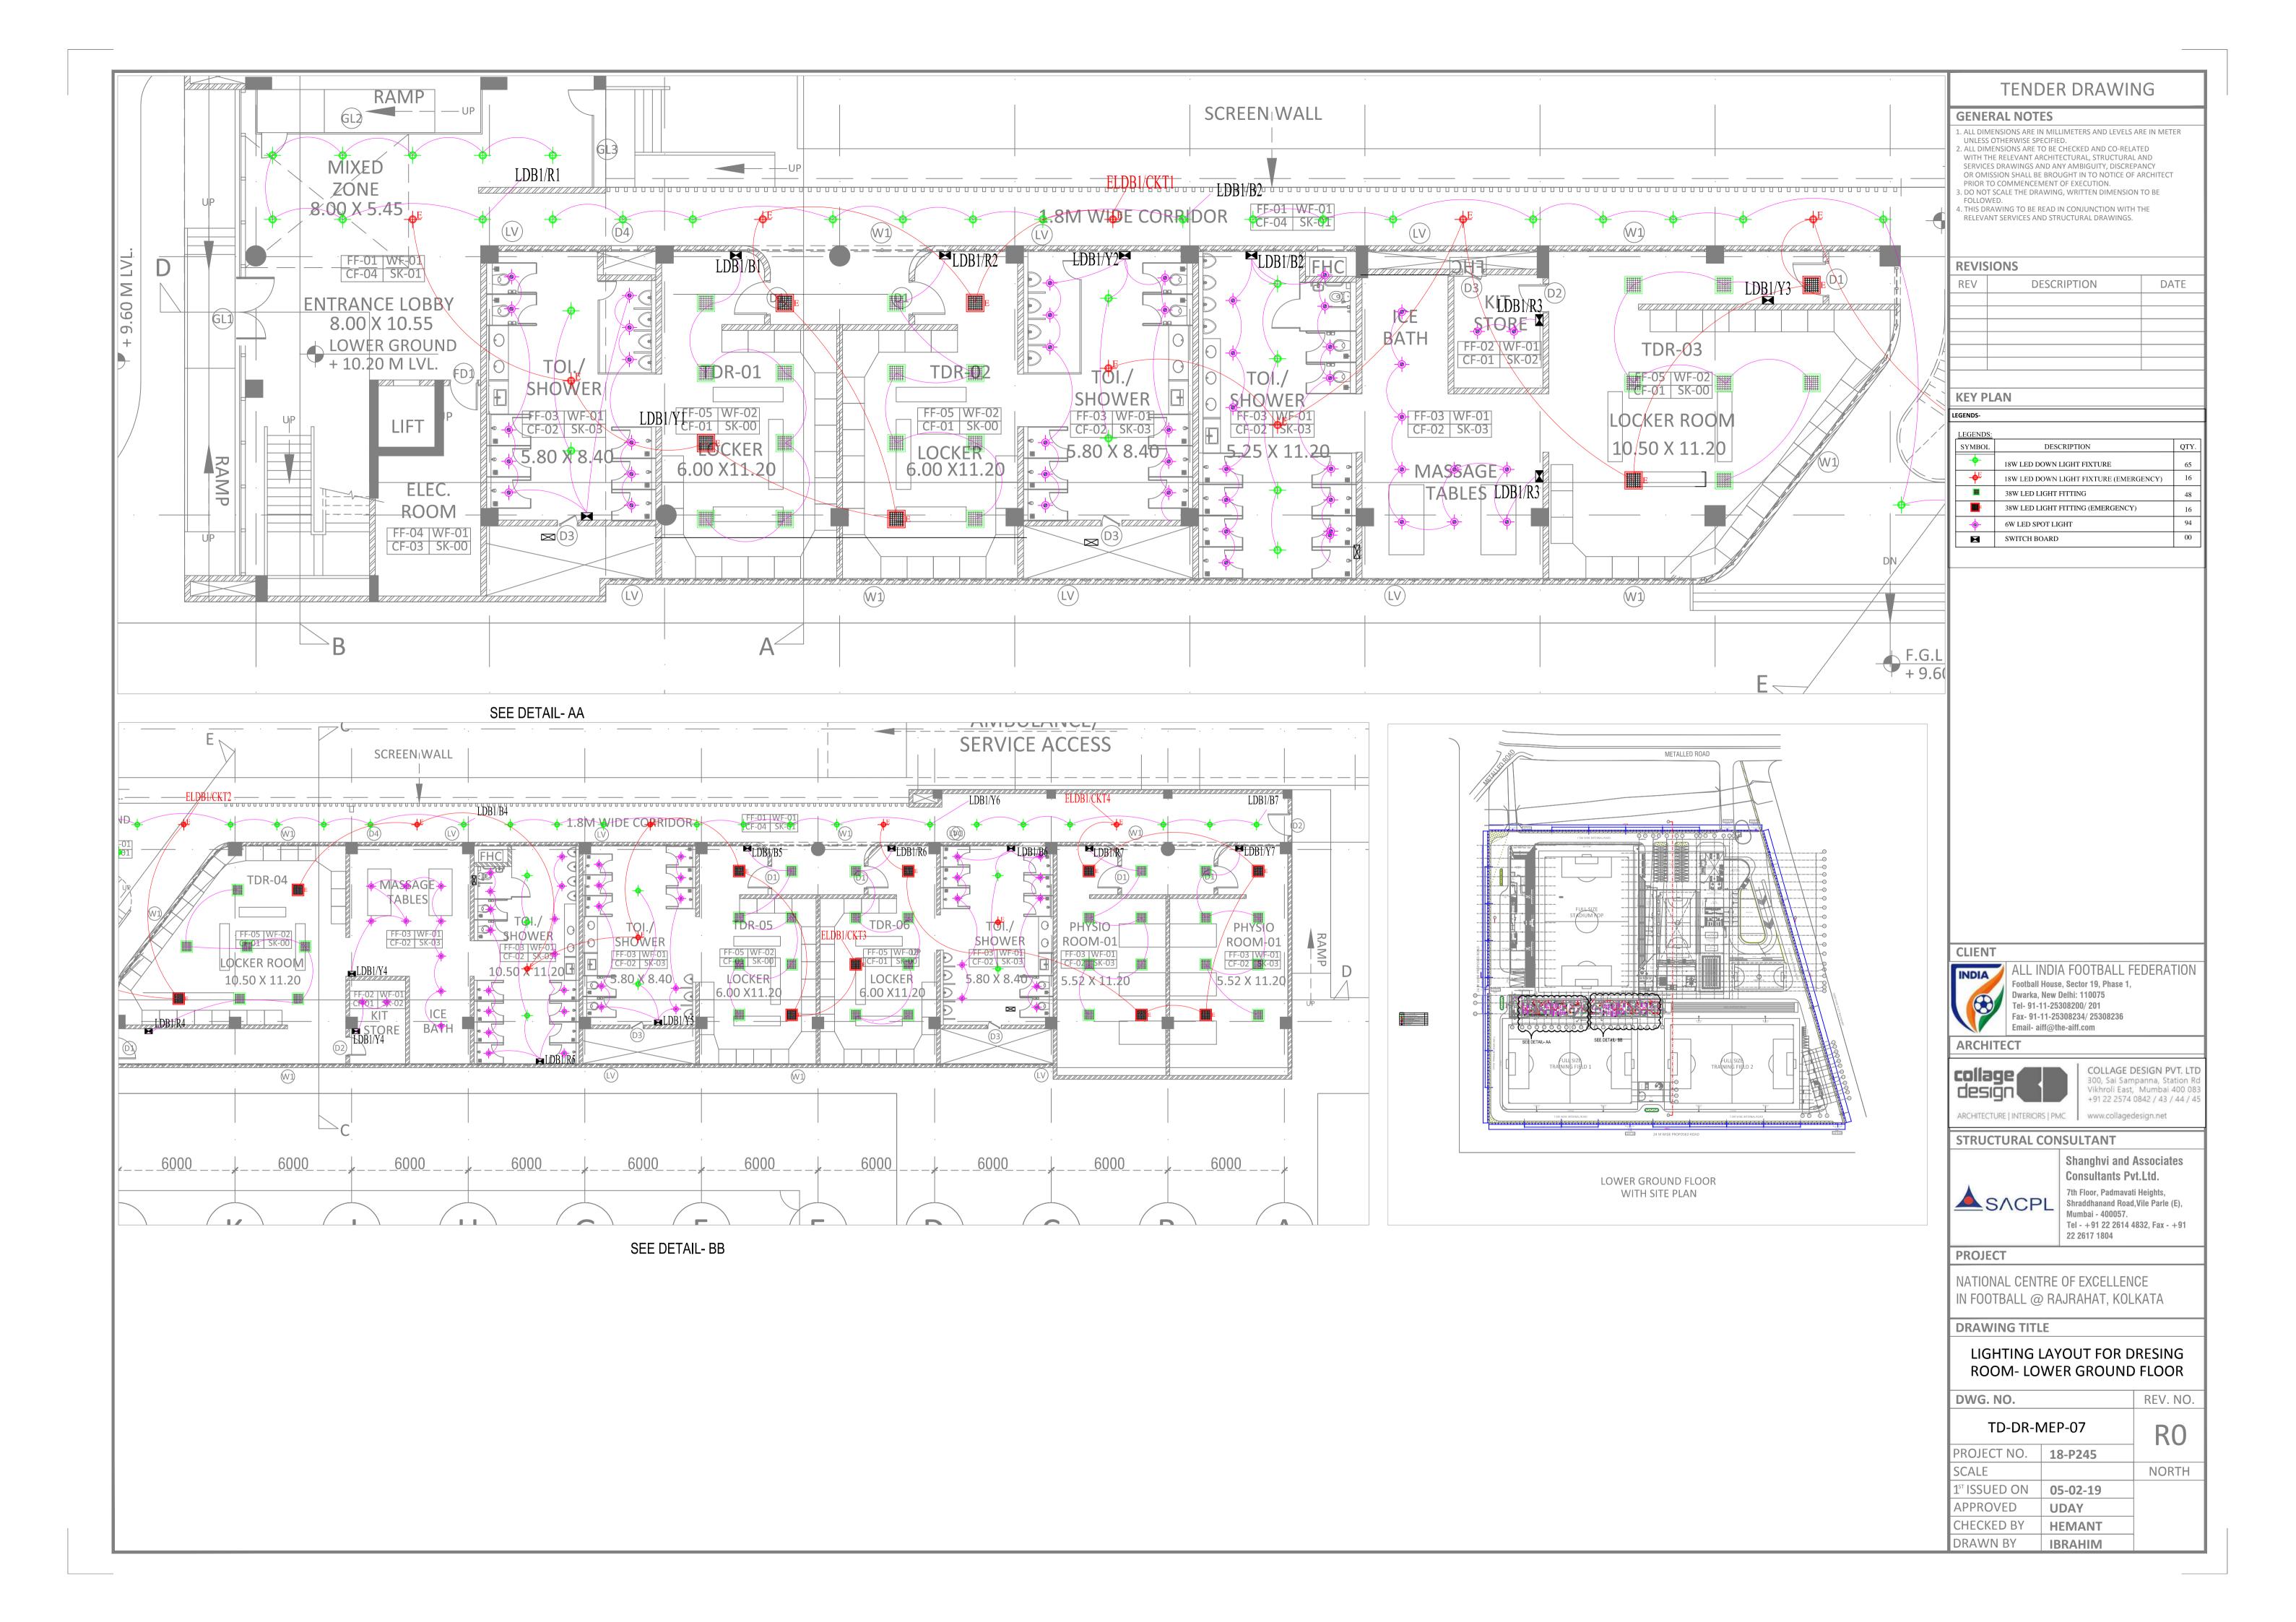


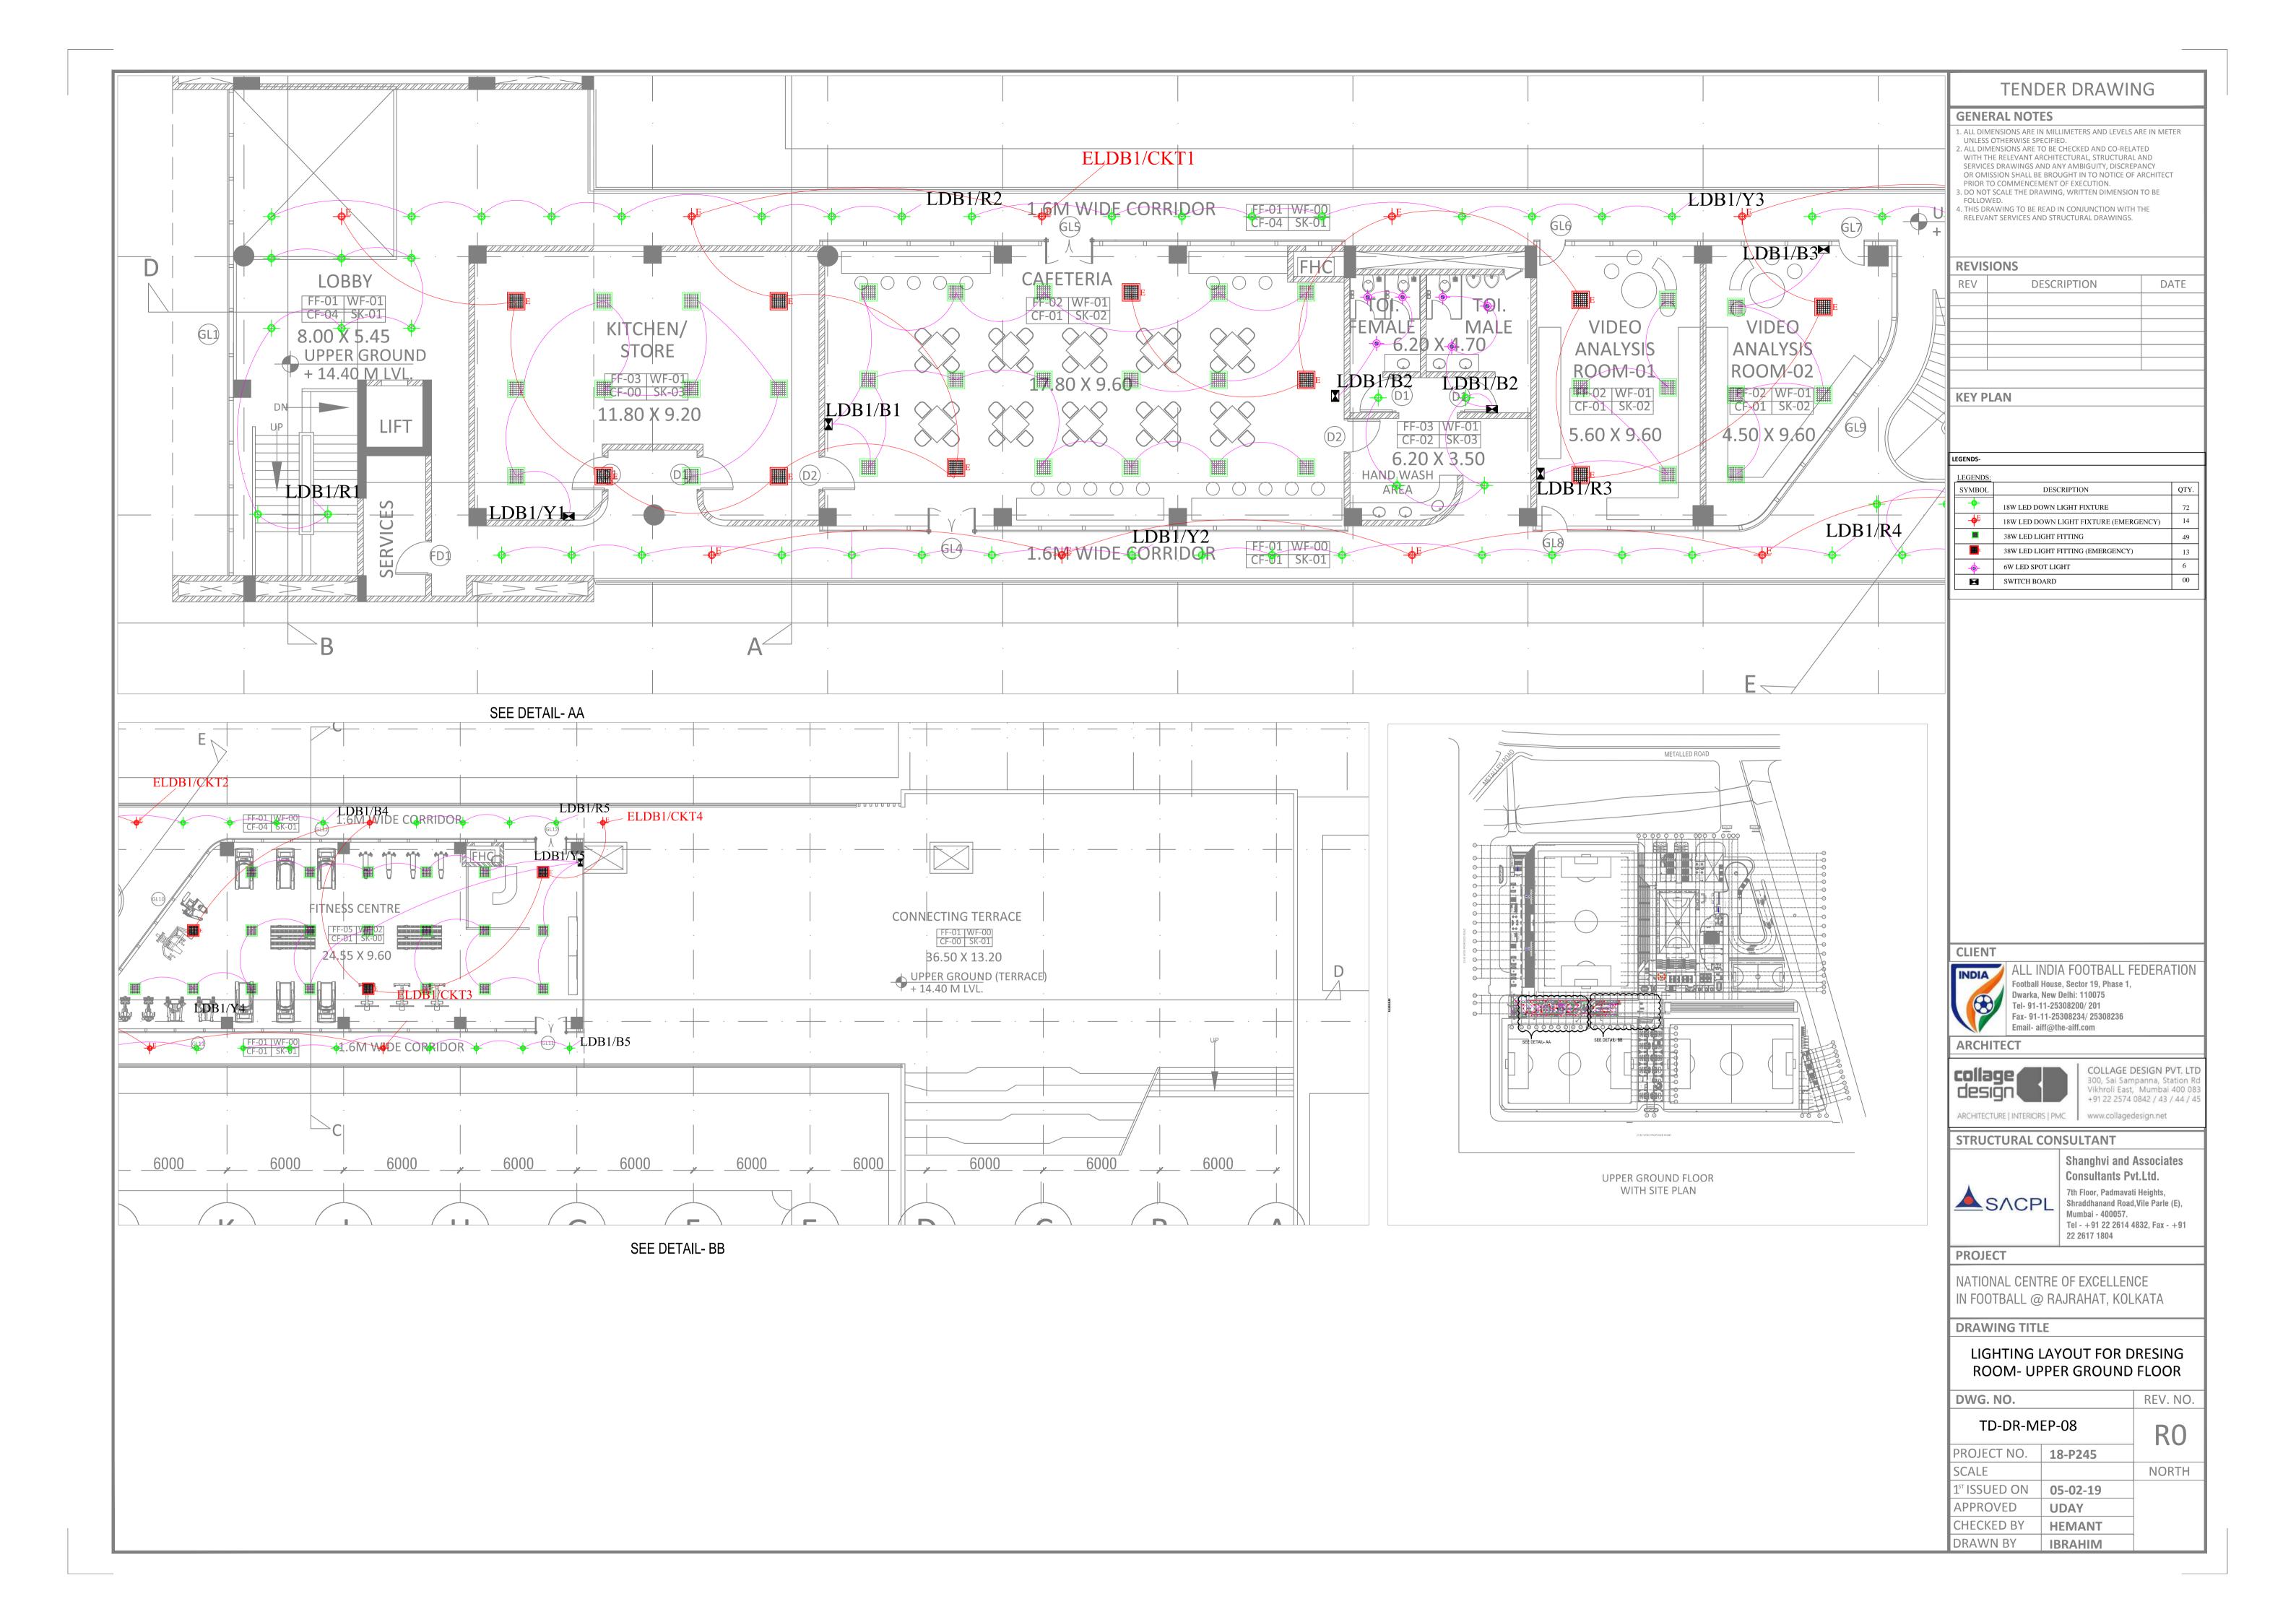

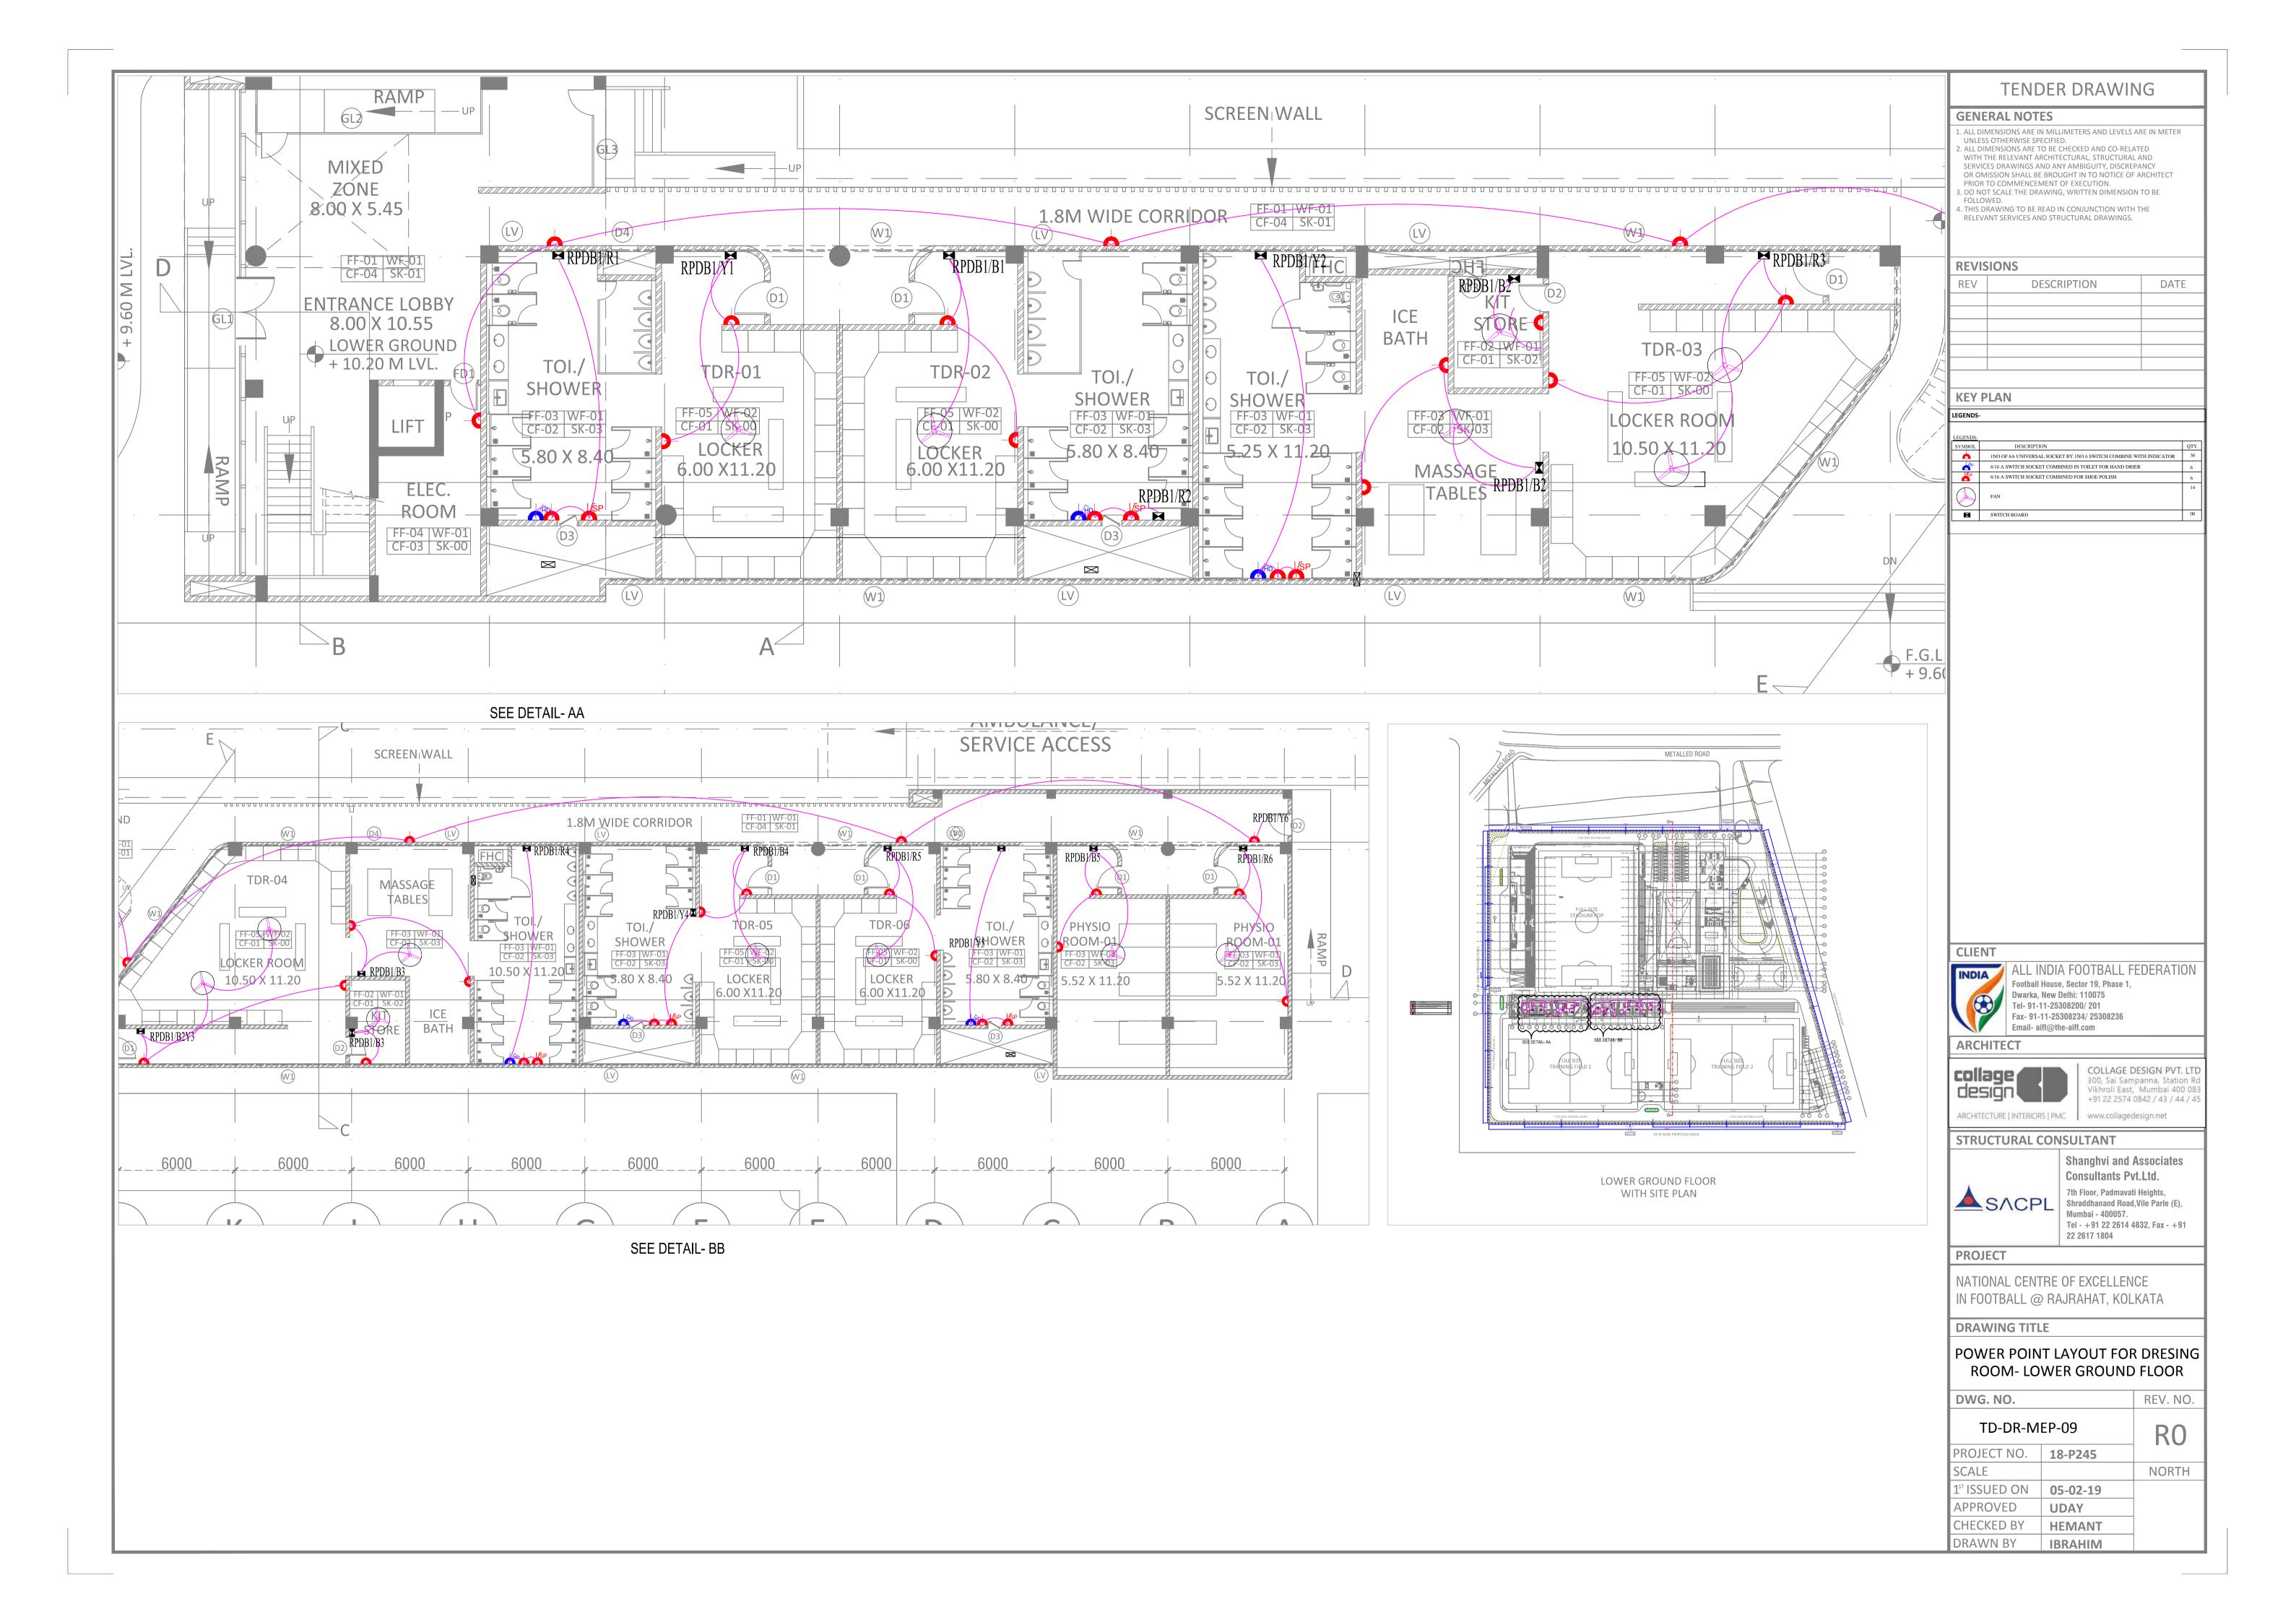


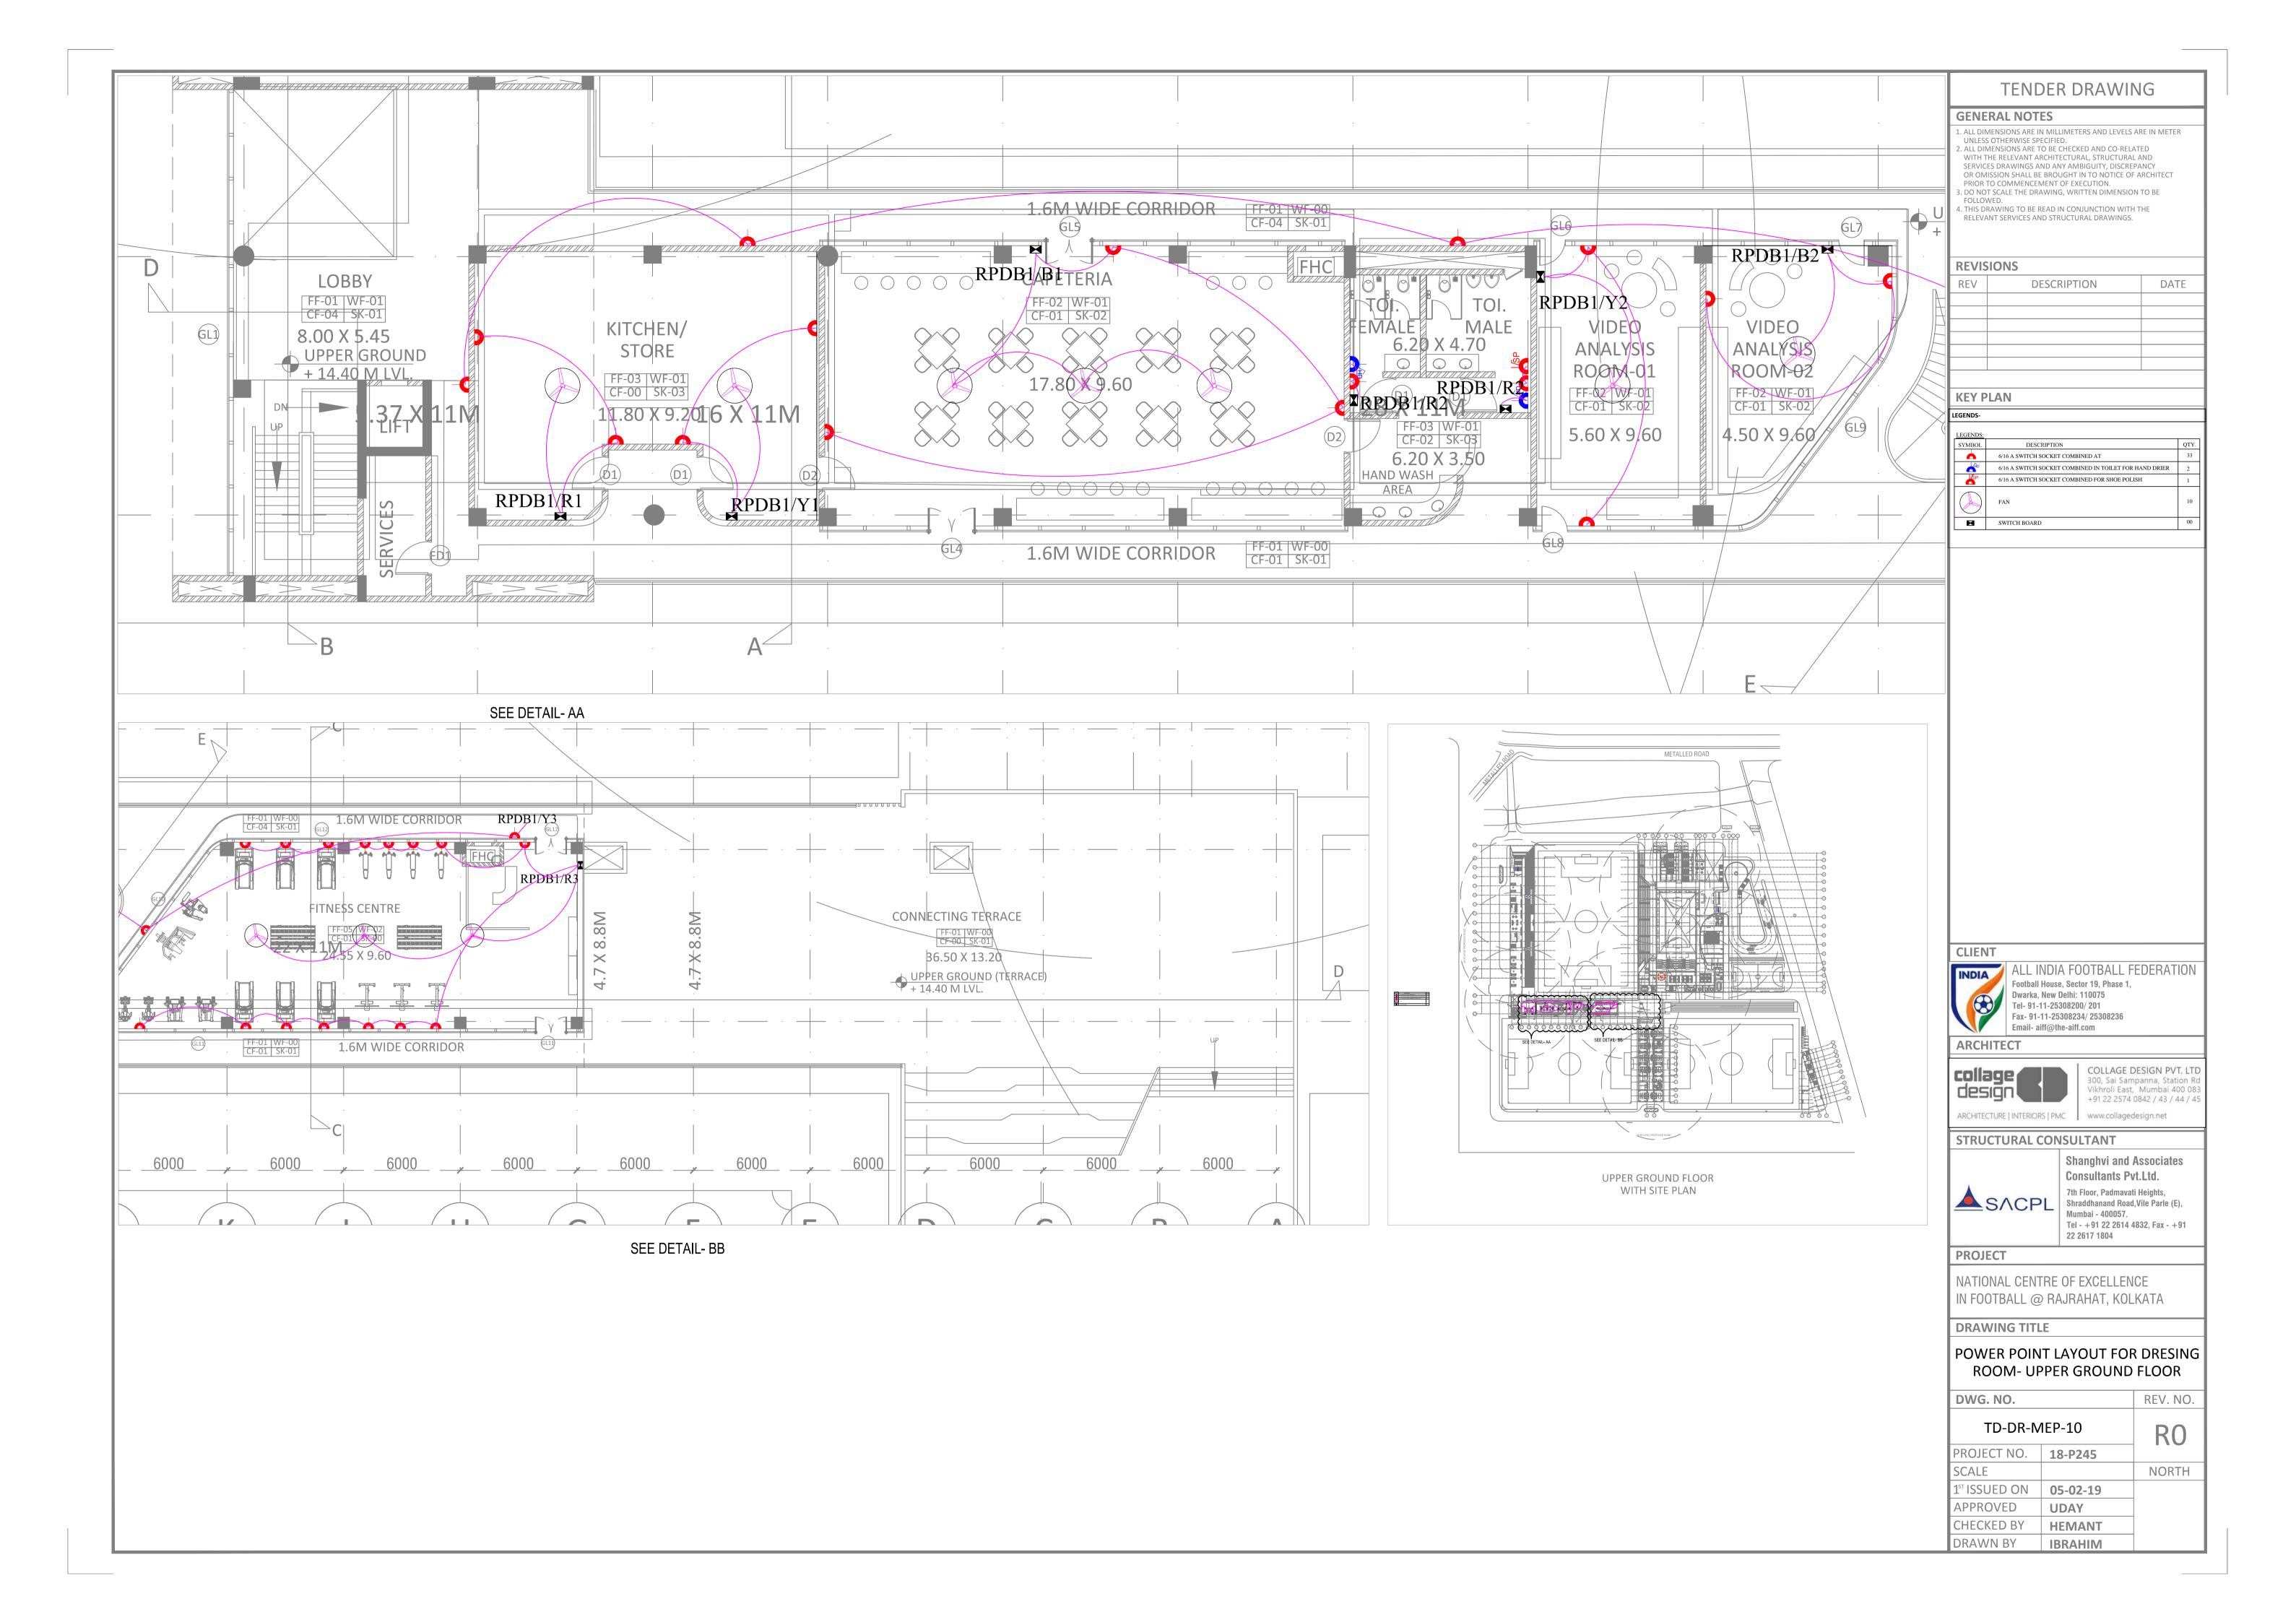


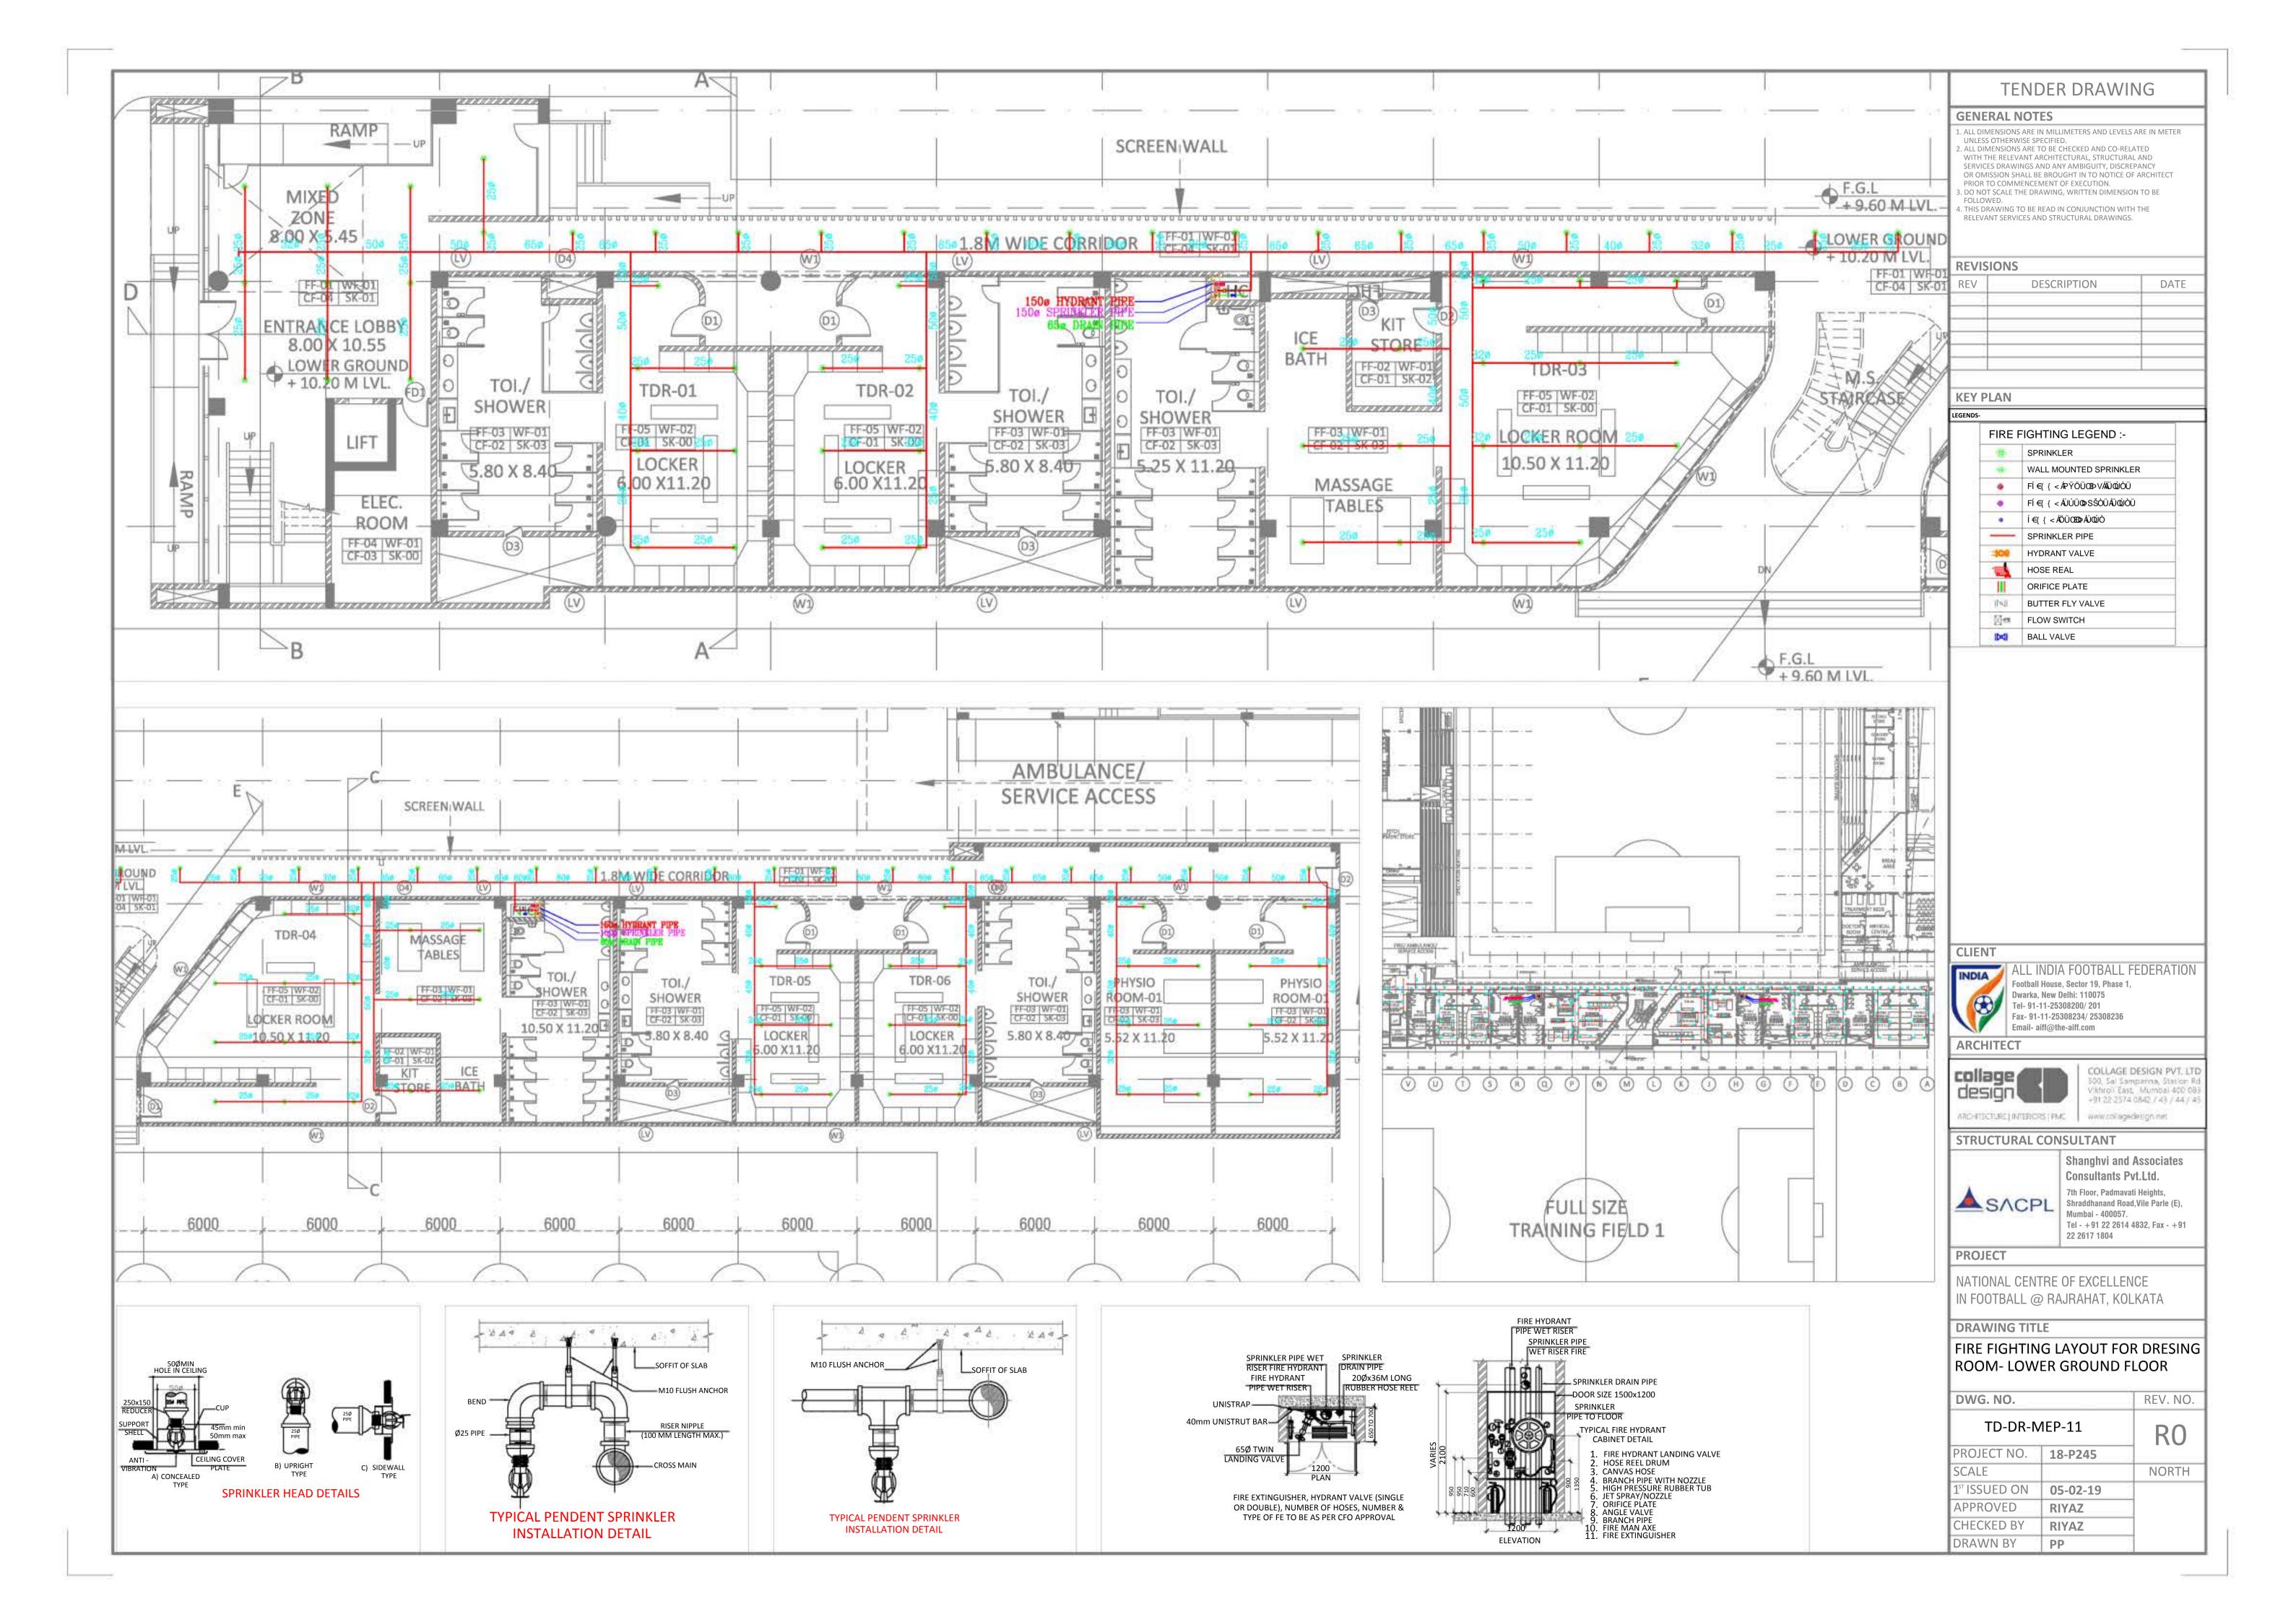


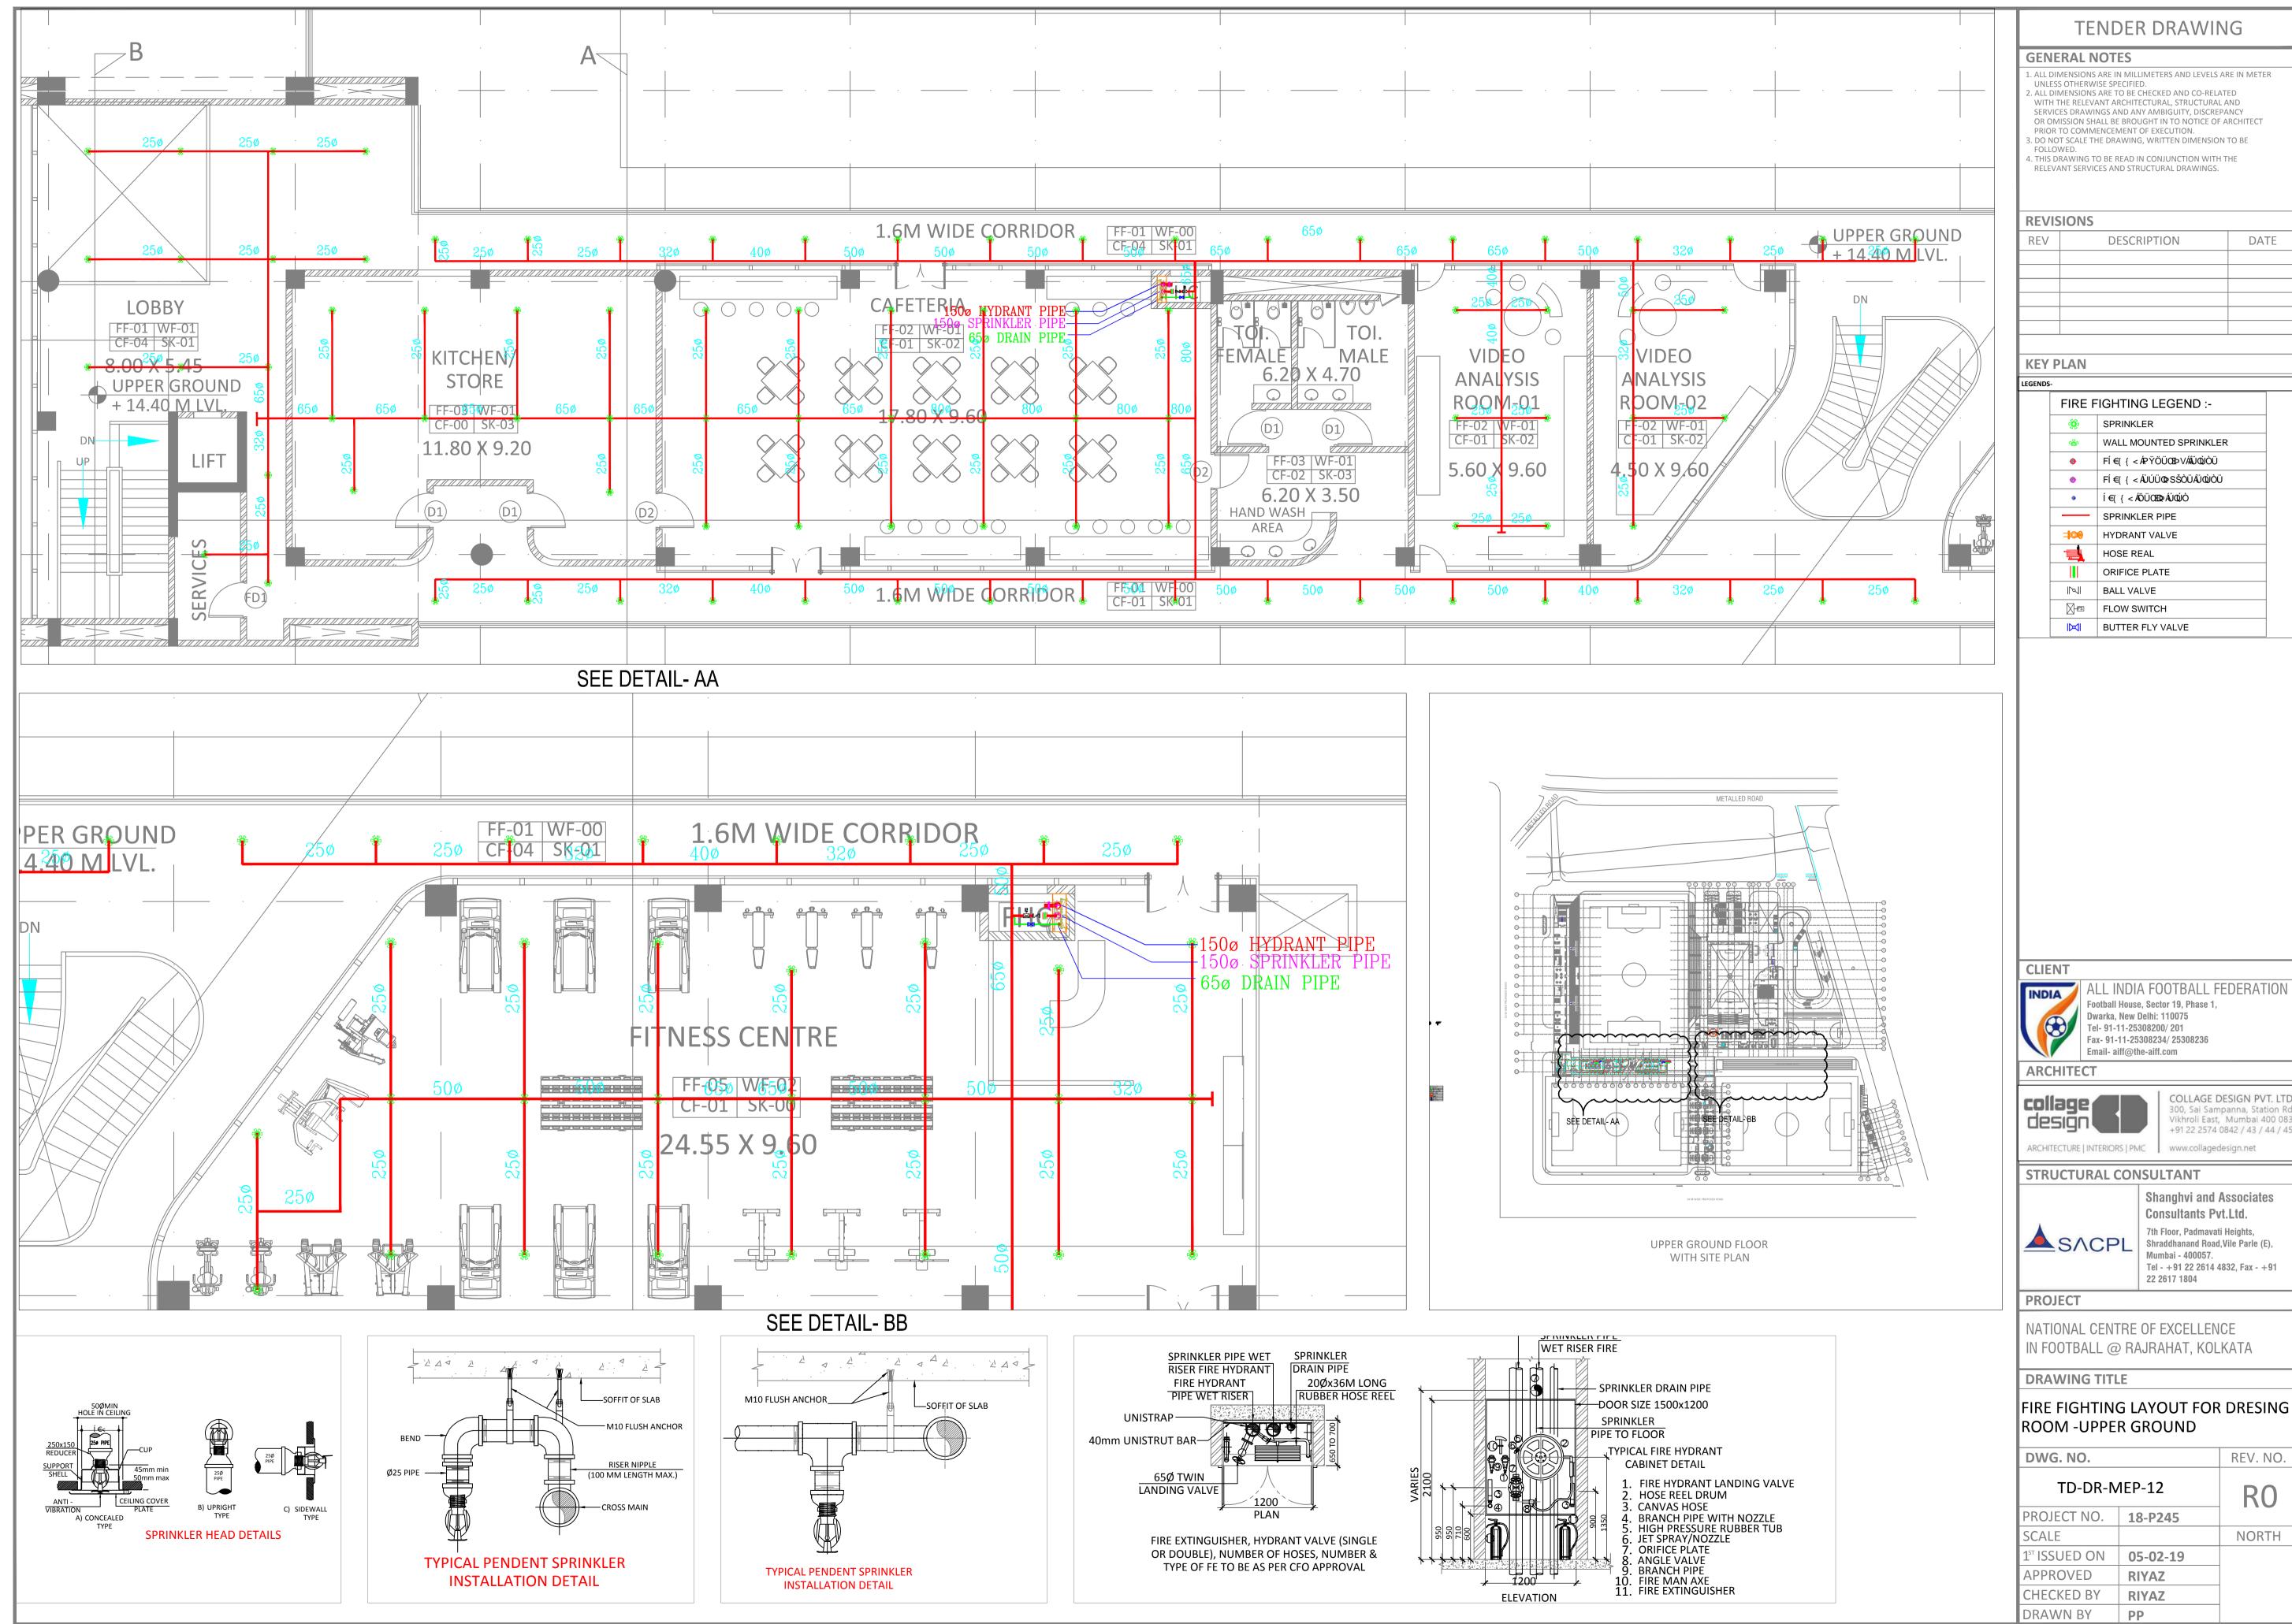



	TF	NDER DRAWIN	G
			0
1. ALL UNL 2. ALL WIT SERV OR C PRIC 3. DO I FOLI 4. THIS	ESS OTHERW DIMENSIONS H THE RELEV/ /ICES DRAWII DMISSION SH DR TO COMM NOT SCALE TH .OWED. DRAWING T	ARE IN MILLIMETERS AND LEVELS AR ISE SPECIFIED. ARE TO BE CHECKED AND CO-RELATE ANT ARCHITECTURAL, STRUCTURAL AI NGS AND ANY AMBIGUITY, DISCREPAI ALL BE BROUGHT IN TO NOTICE OF AF ENCEMENT OF EXECUTION. HE DRAWING, WRITTEN DIMENSION T O BE READ IN CONJUNCTION WITH TH CES AND STRUCTURAL DRAWINGS.	D ND NCY RCHITECT O BE
RFV	ISIONS		
REV		DESCRIPTION	DATE
KEY	PLAN		
LEGENDS	-		
	FIRE F	FIGHTING LEGEND :-	
	***	SPRINKLER	
	<b>\$</b>	WALL MOUNTED SPRINKLER	
	•	FÍ€{{ < ÁPŸÖÜ02∋∨ÁÄÜQÙÒÜ	
	•	FÍ €{ { < ÂIJÚÜΦౖSŠÒÜÂIJÒÒÜ	
	٠	Í€{{ < AÖÜŒÐAĴÓÒ	
		SPRINKLER PIPE	
		HYDRANT VALVE	
		HOSE REAL	
		ORIFICE PLATE	
	2	BALL VALVE	
		FLOW SWITCH	
		BUTTER FLY VALVE	

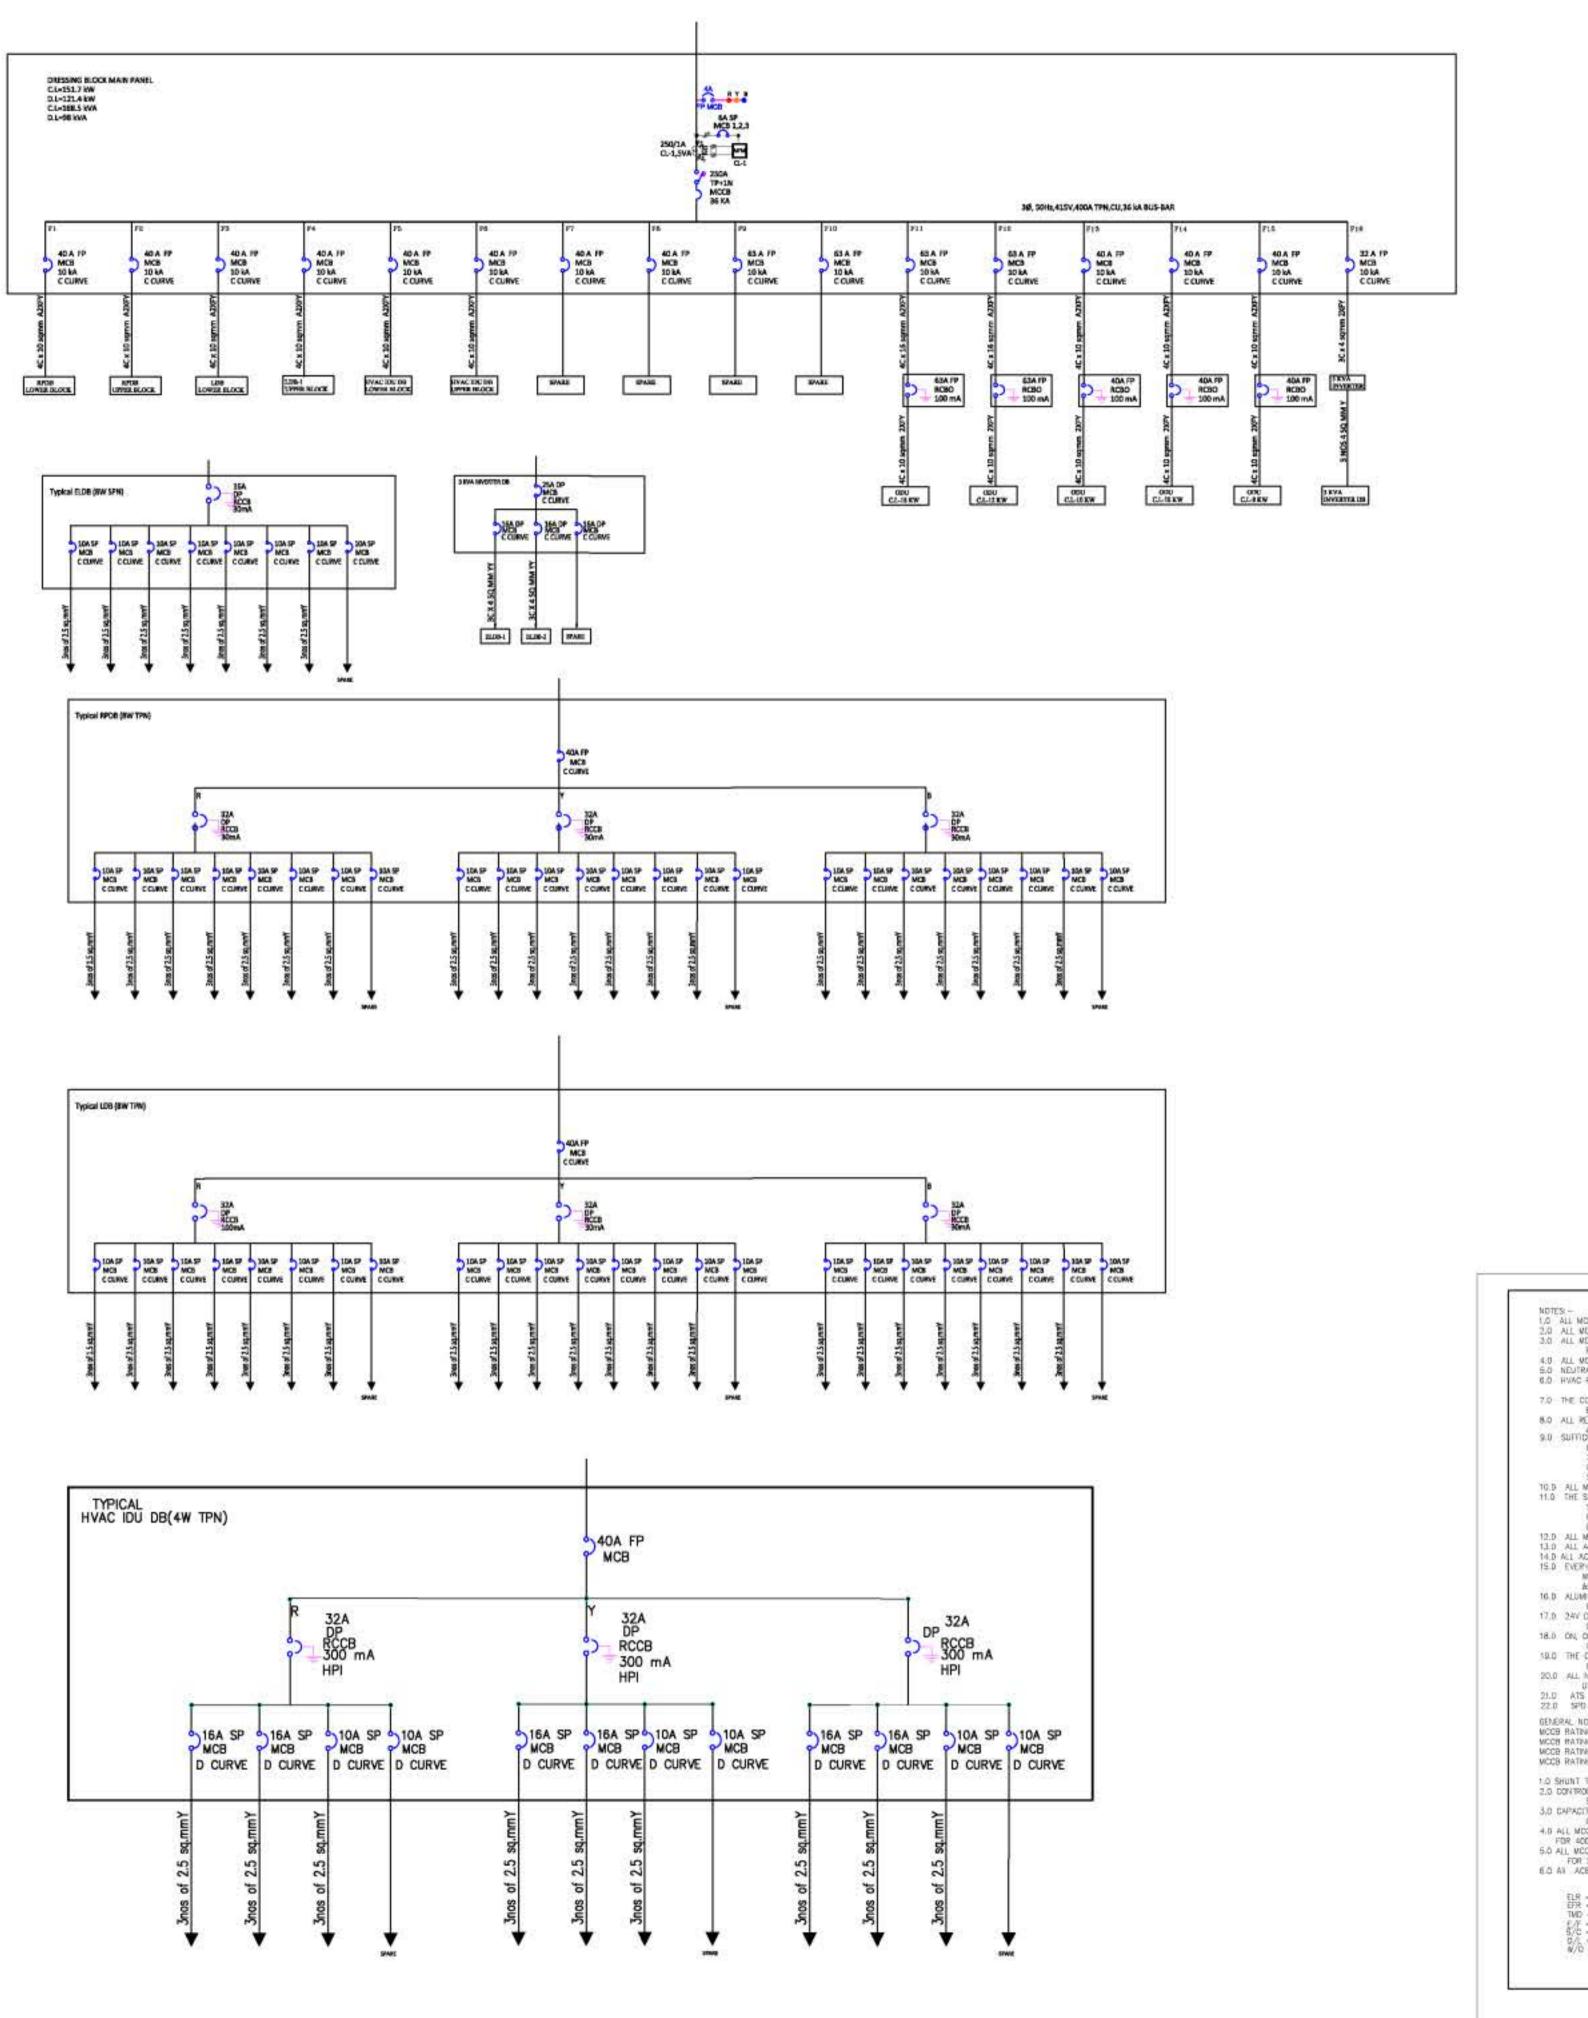

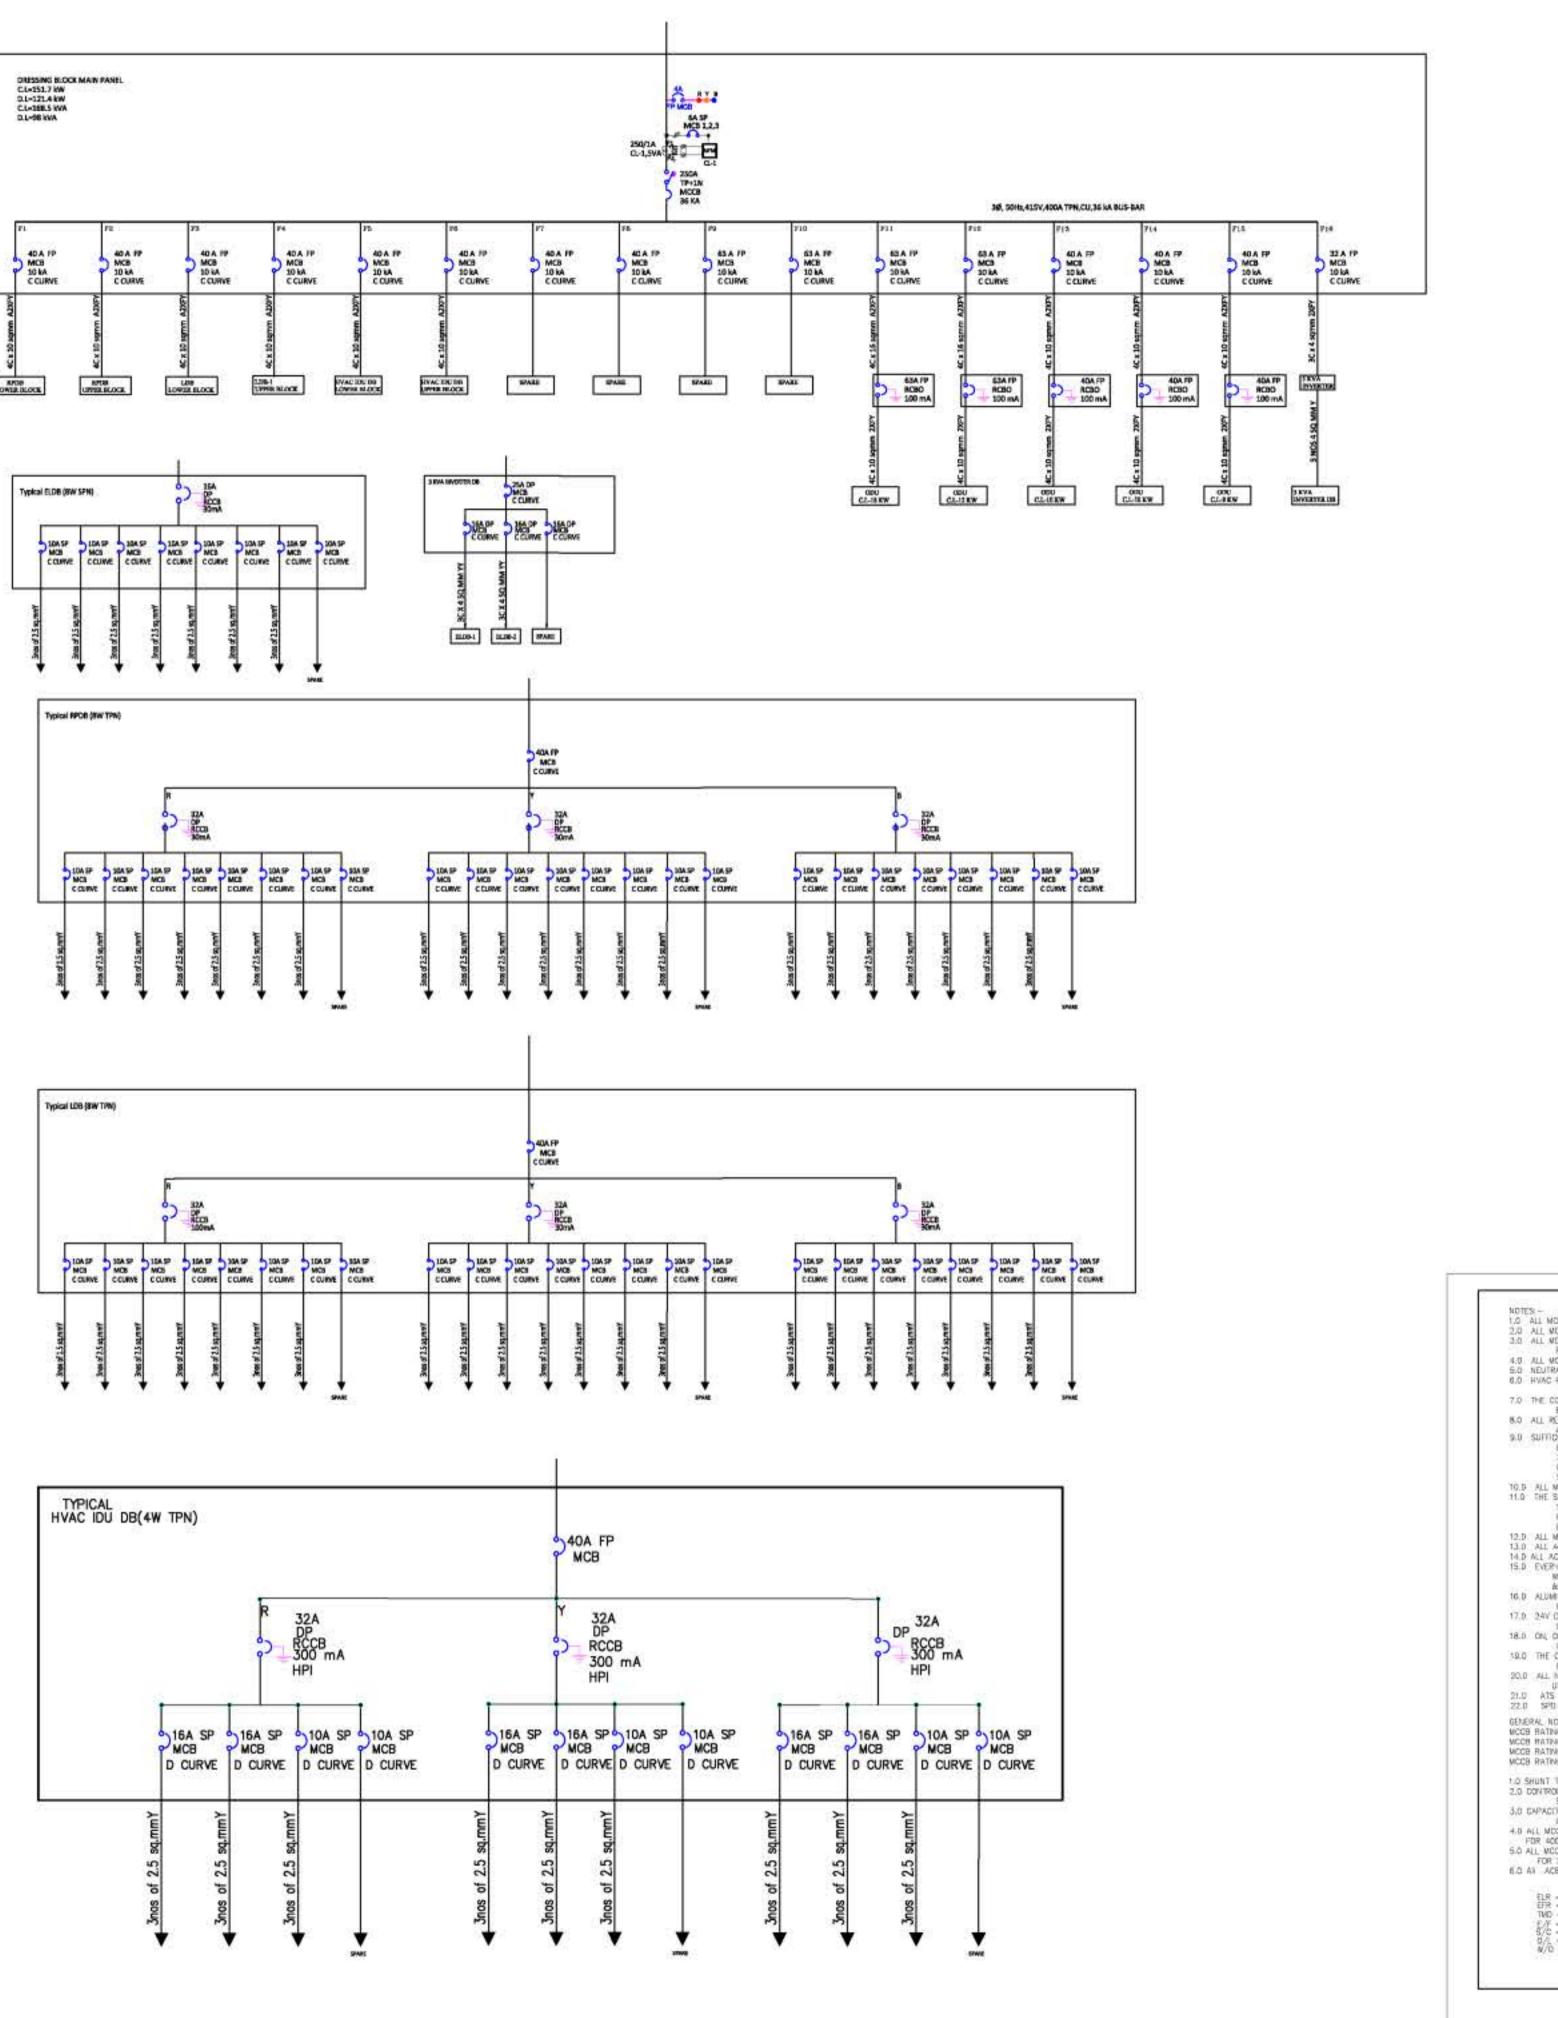

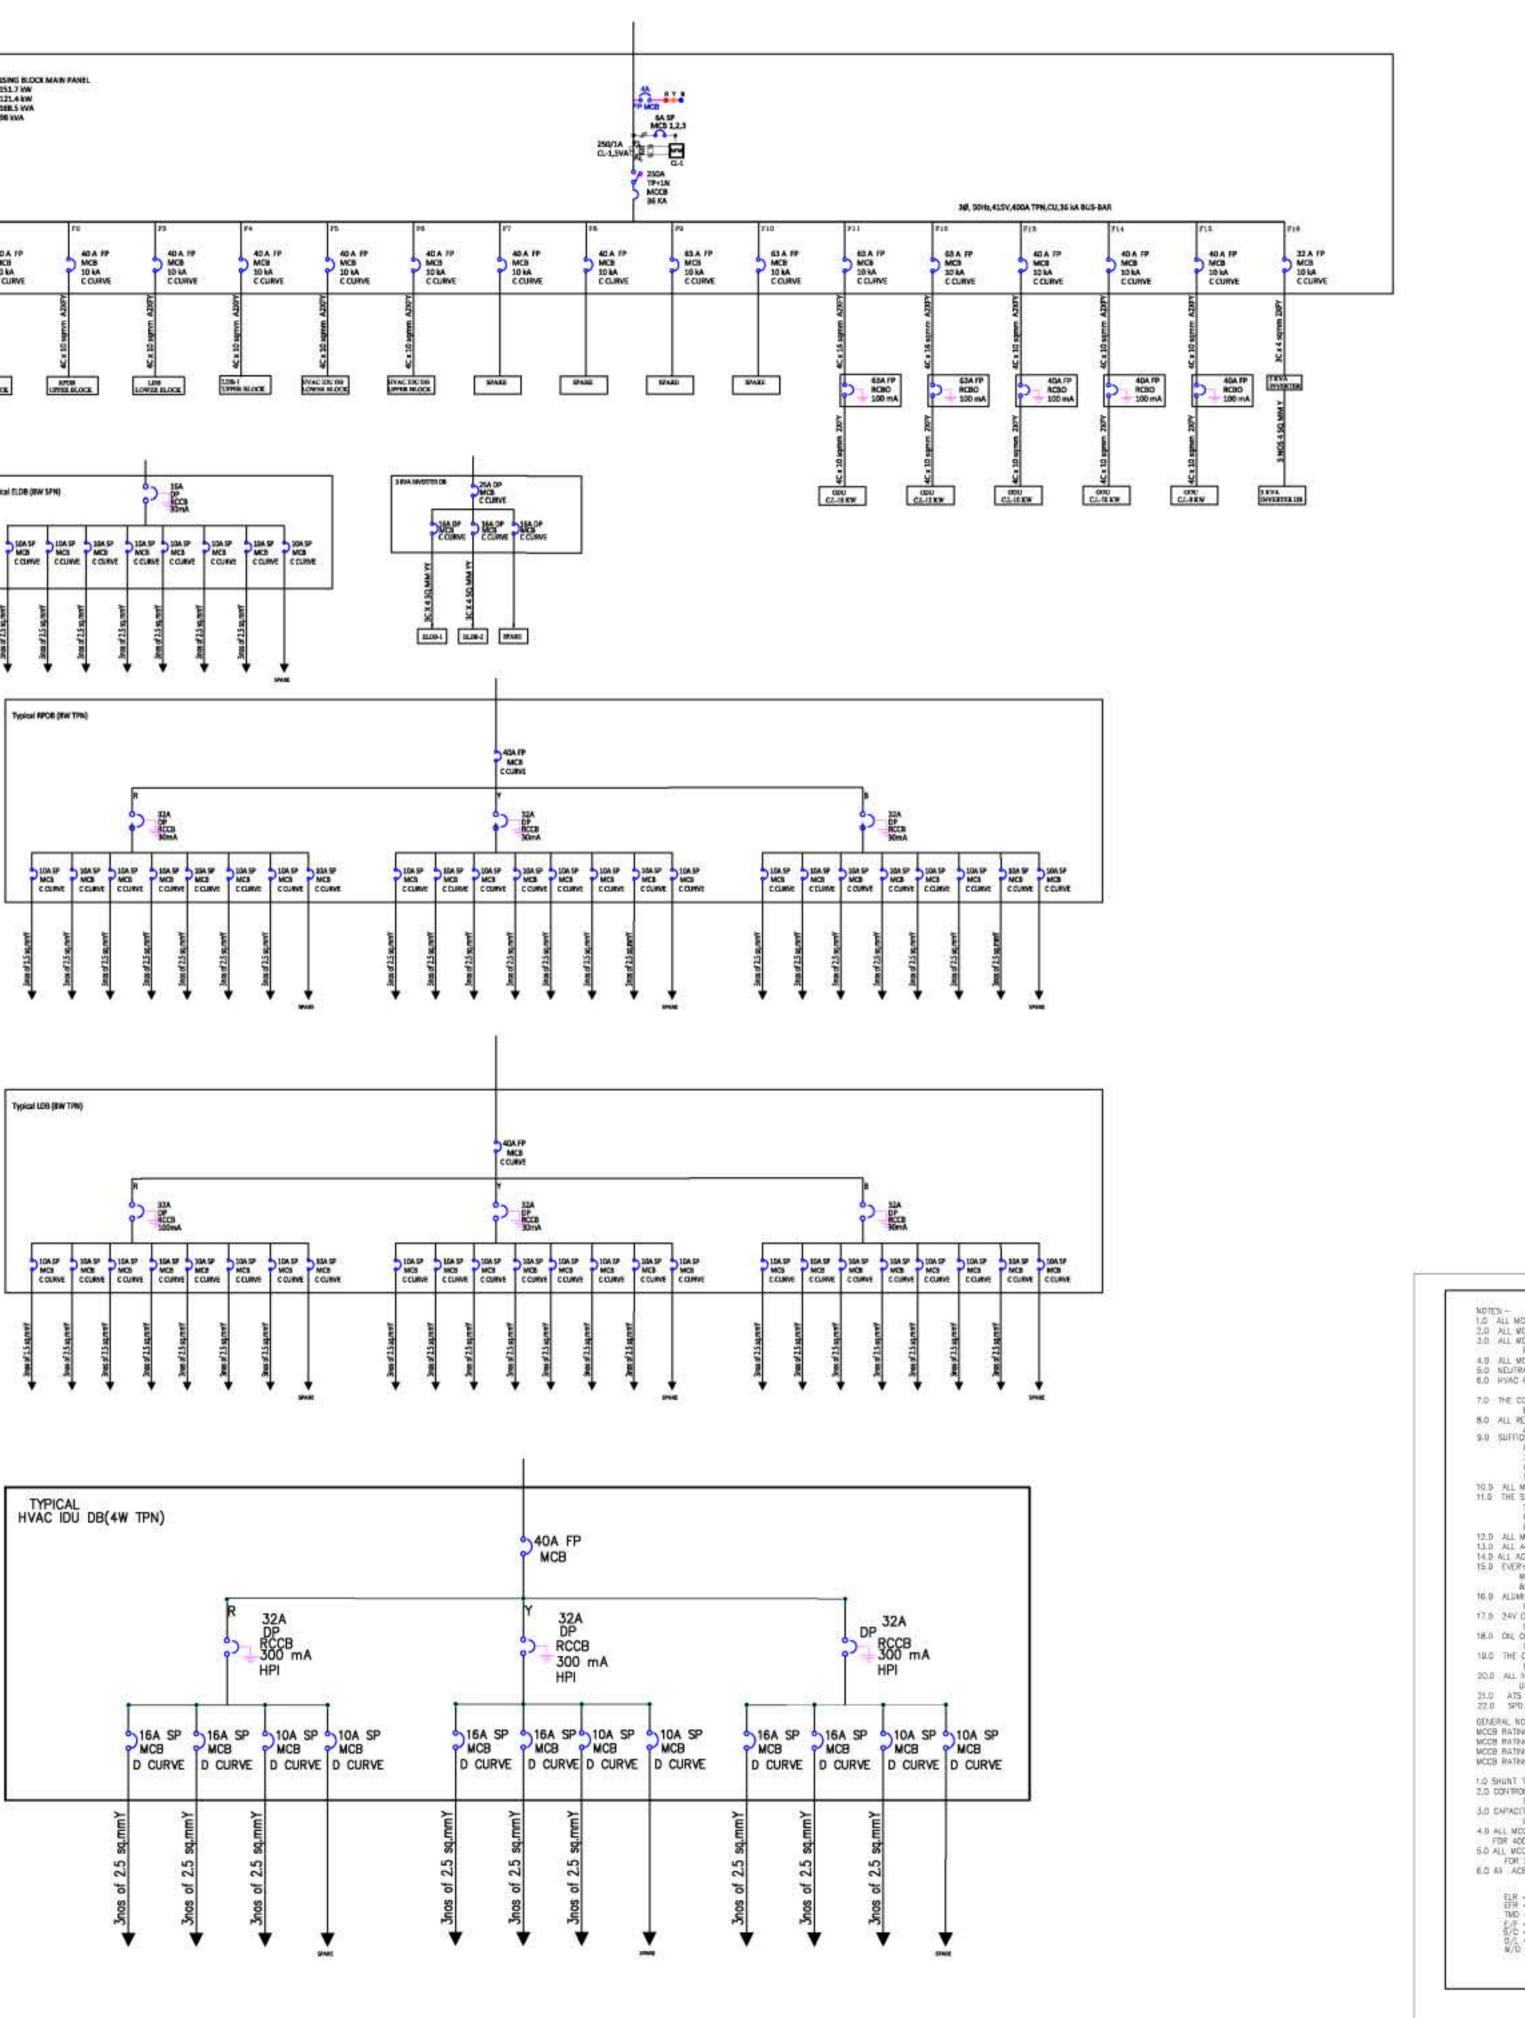


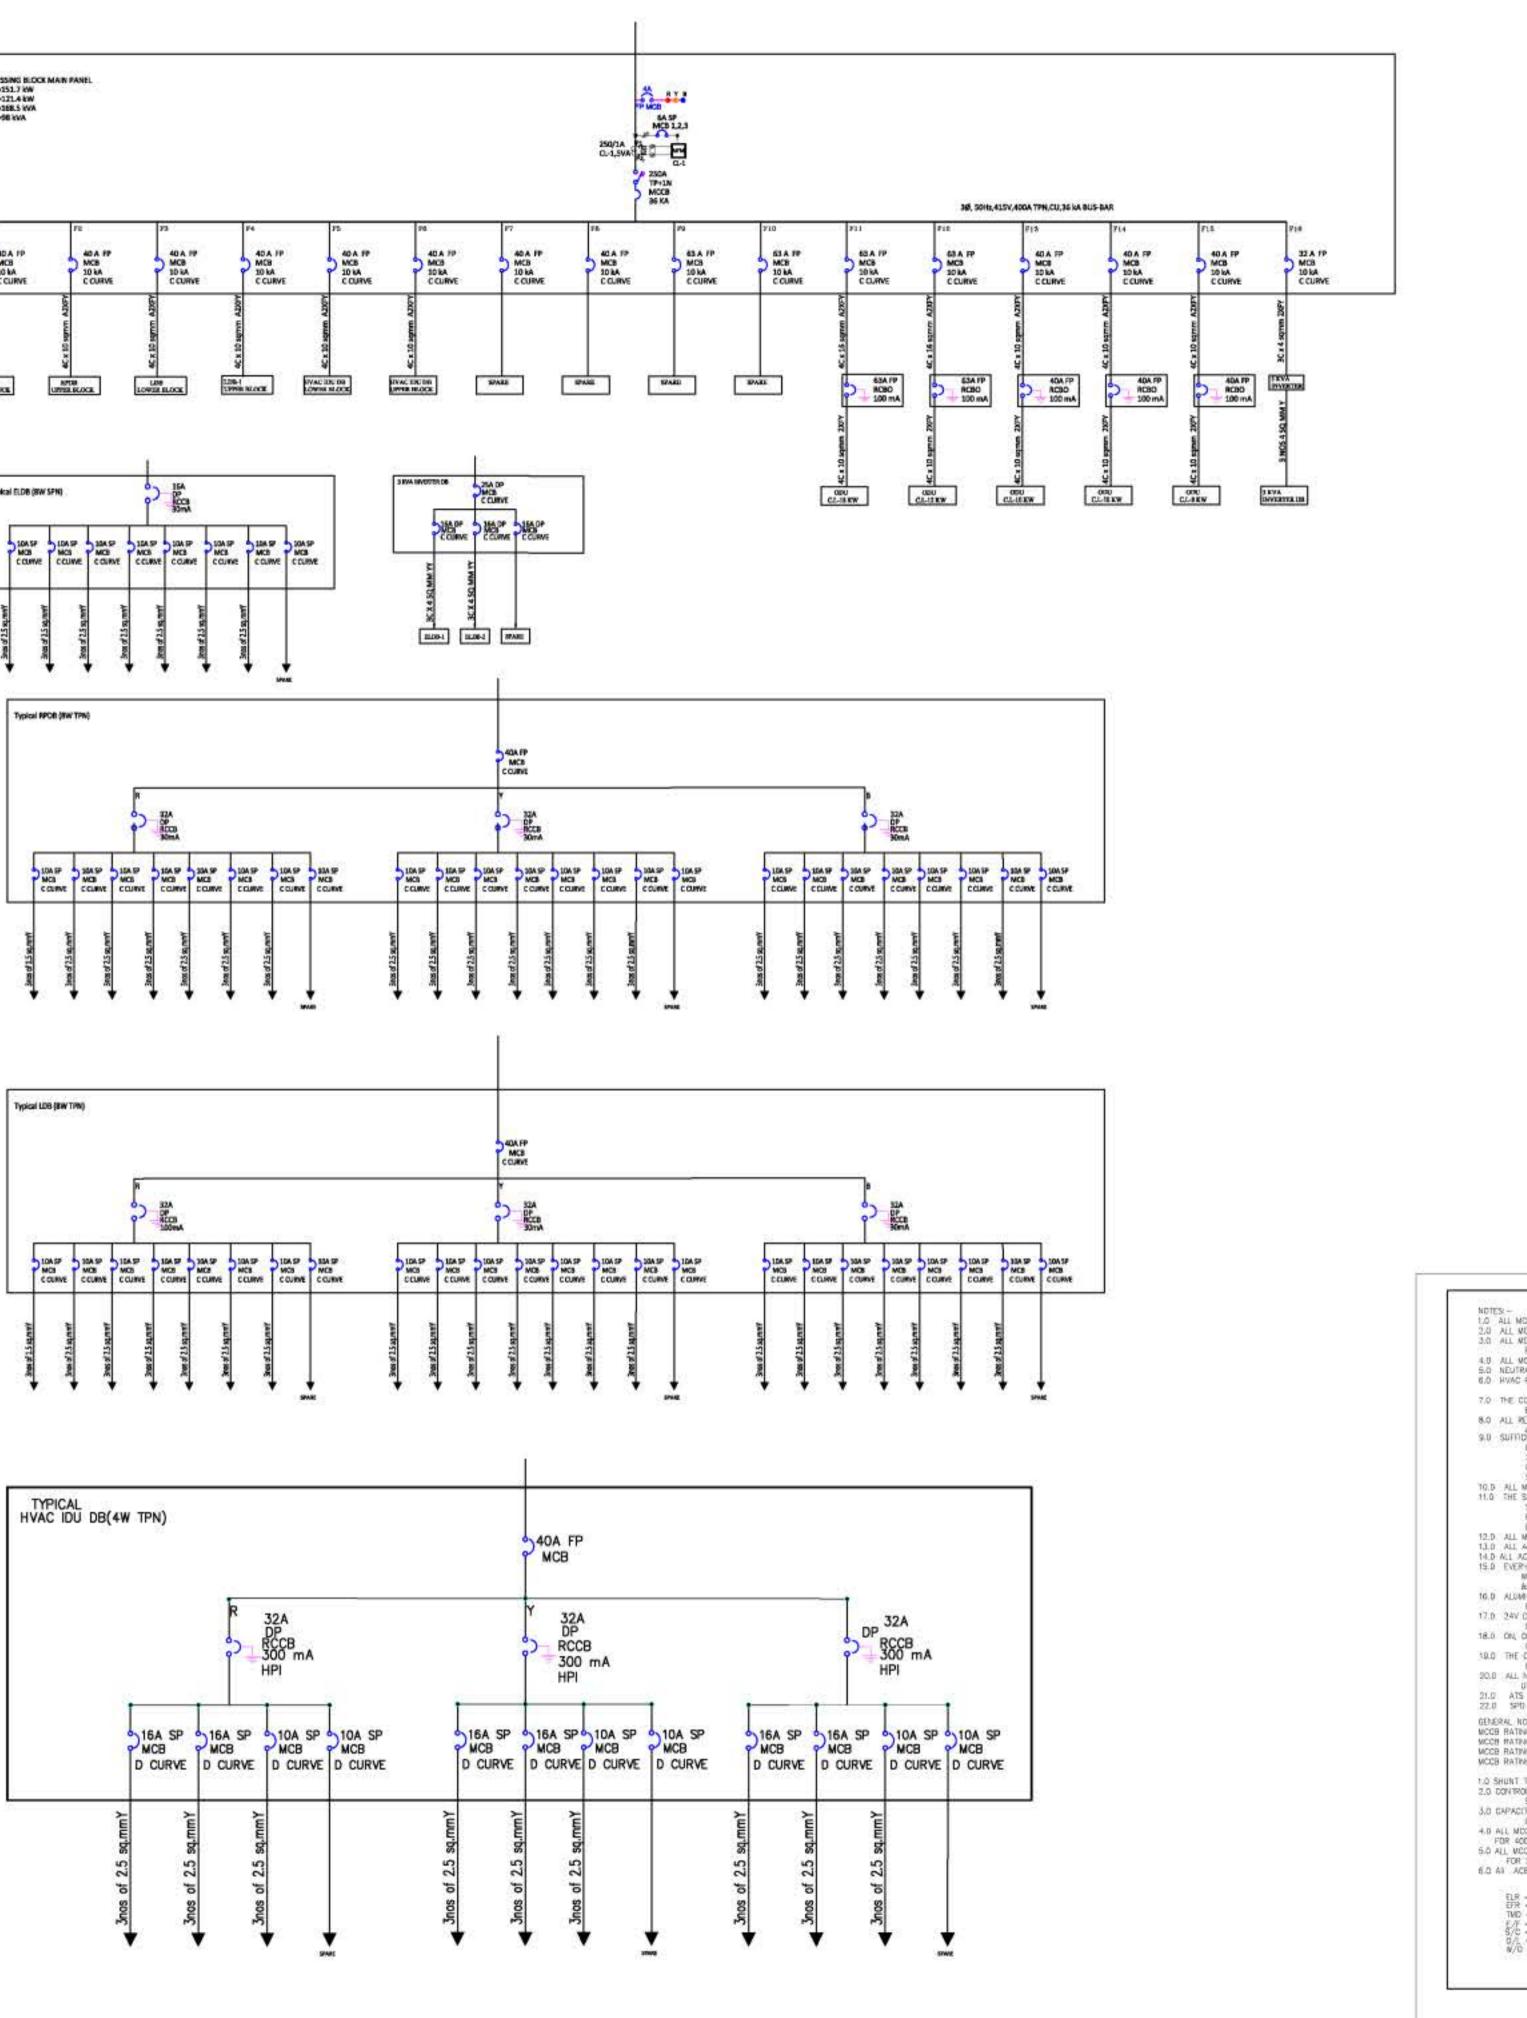

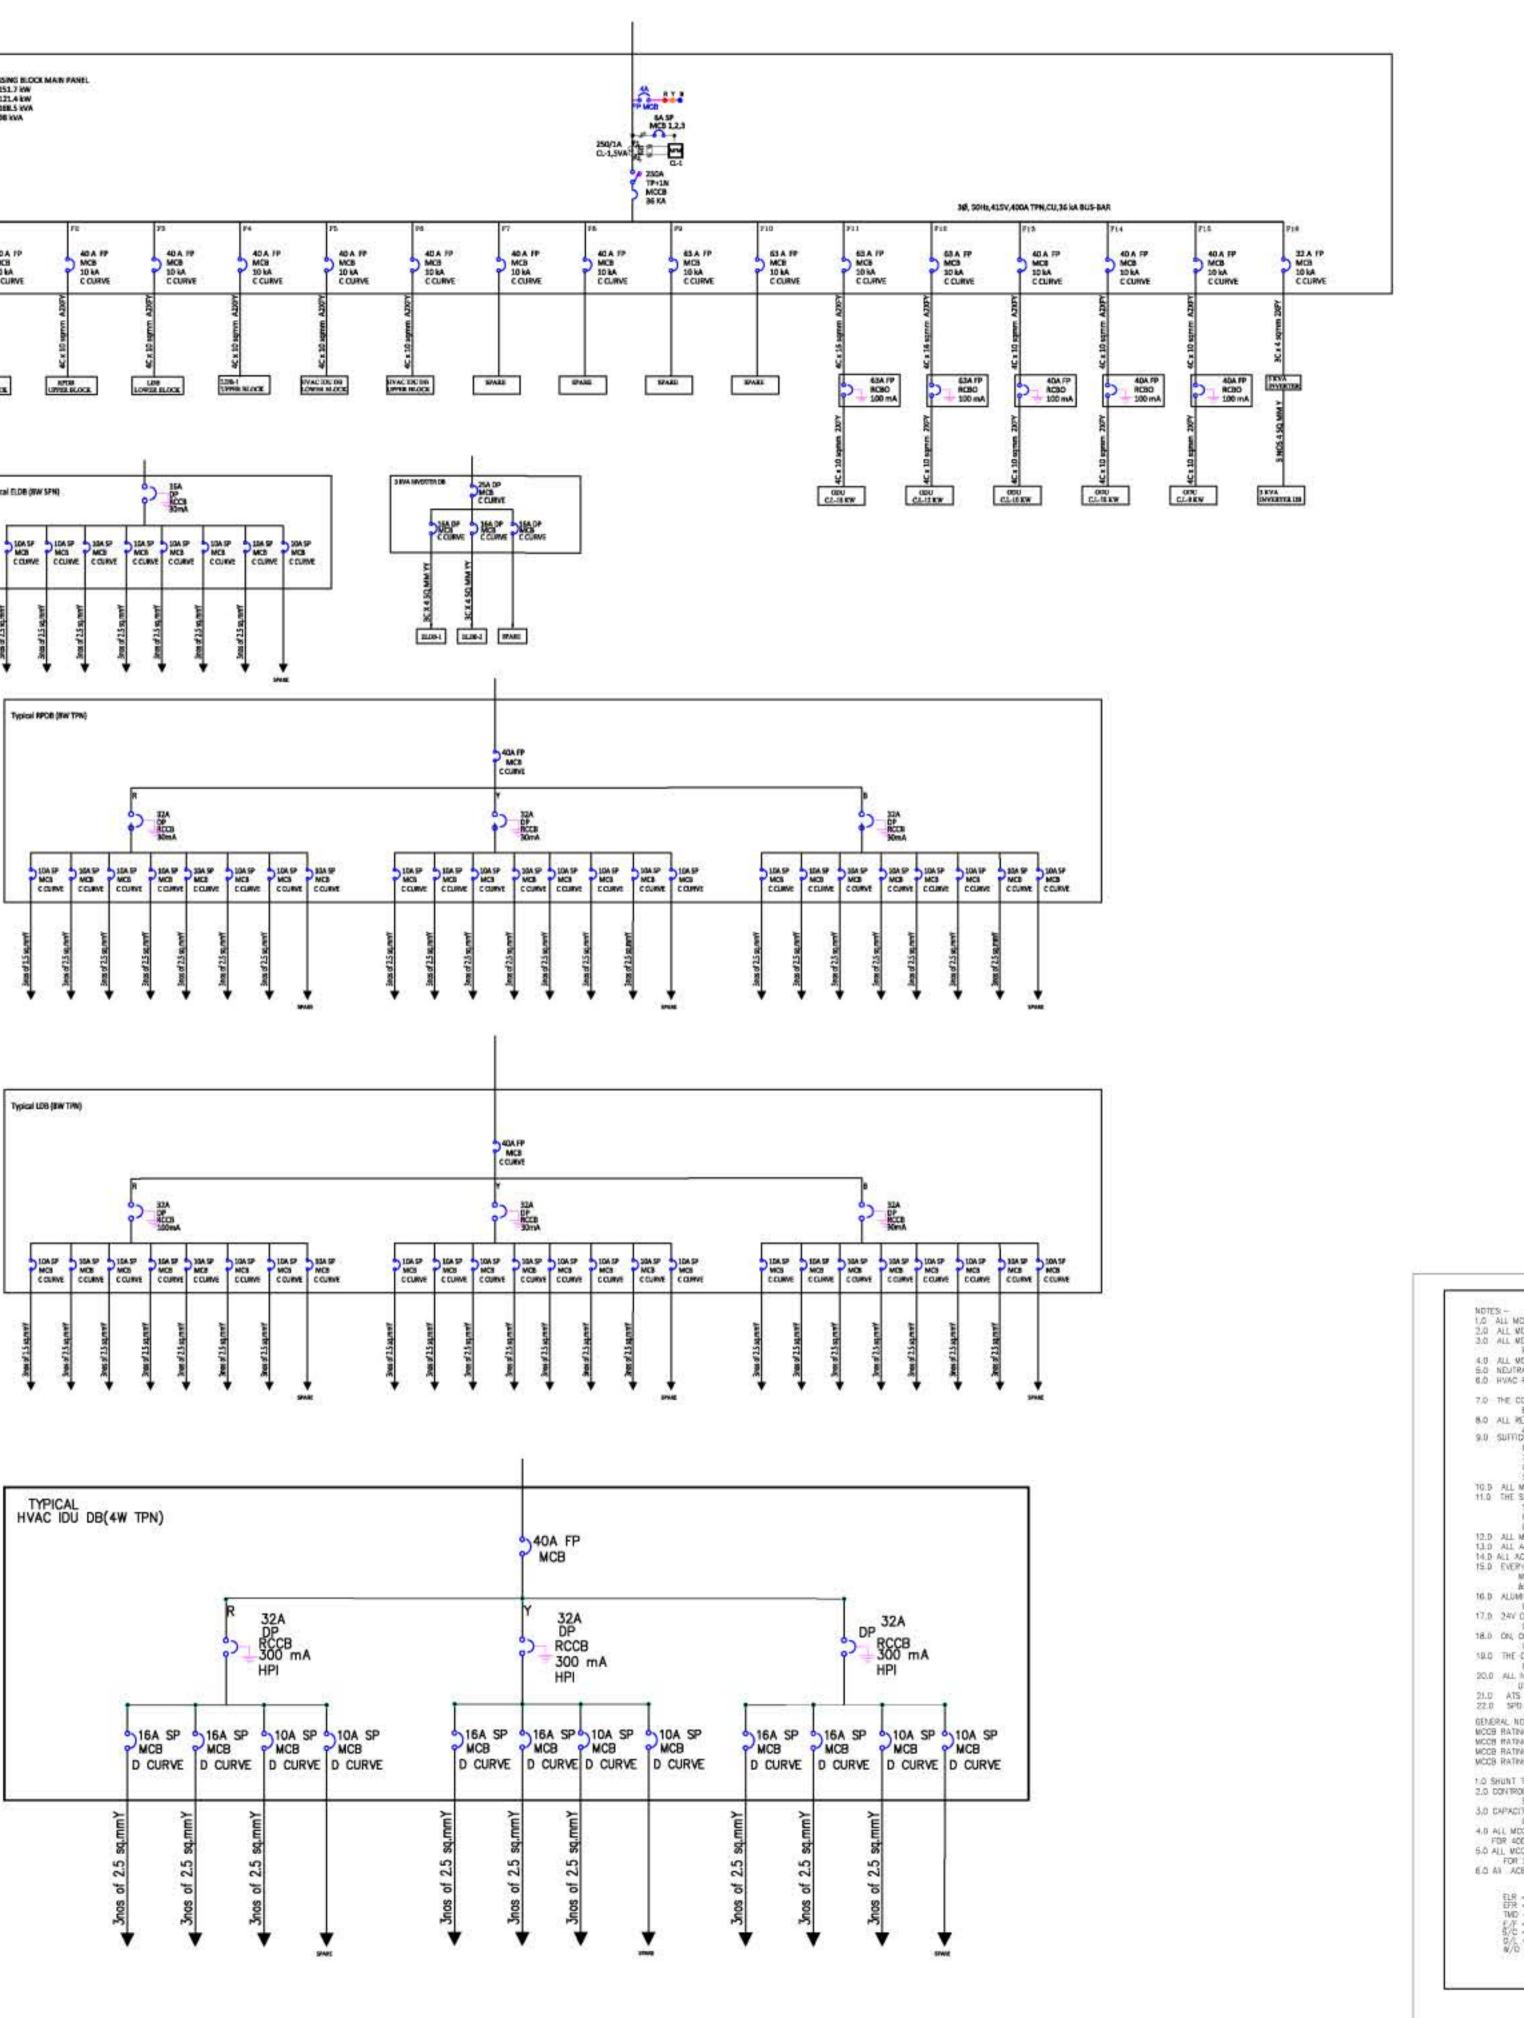



_							
		TEN	DEF	r drav	VIN	G	
GEN	IFR		TES				-
				LIMETERS AND LI	EVELS AF	RE IN METER	_
UNL	ESS O	THERWISE	SPECIFIE				
WIT	Н ТНЕ	RELEVANT	ARCHIT	ECTURAL, STRUC	TURAL A	ND	
				JGHT IN TO NOT OF EXECUTION.	ICE OF A	RCHITECT	
FOLI	LOWE	D.		G, WRITTEN DIM			
				N CONJUNCTION		ΉE	
REV	ISIC	ONS					
REV			DESCE	RIPTION		DATE	
_	-						_
-							
3	S				- 3		
_	-				-		-
2							
KEY	PL/	AN					
EGENDS	6-						
LEGEN	_			Victor Walking			
100	MIC	ROPROCES	SOR REI				
		S/C & O/L I	-	TION) JIT BREAKER (W	пн	-	
5		EASE FOR E	E/F,S/C 8	O/L PROTECTI	ON)		
2	1	IATURE CI	RCUIT B	REAKER		-	
3	EAR	TH LEAKAG	E CIRCI	JIT BREAKER - 30	) mA	-	
	-	SE INDICA		1002030201124	0000	-	
-	-						
		TMETER					
	AM	METER					
	VOI	TAGE SELE	CTOR S	WITCH			
80	AM	METER SEL	ECTOR	SWITCH			
1	CUR	RENT TRA	NSFORM	MER			
E.	100	tal energy		idicating true RM			
En		manne These			Tactors.		
	volt in H		, KVAR,	KVAh, KVARh,K		mana,	
<u>د</u>	volt in H		, KVAR,			inona,	
	volt in H with Digit	z, KVA, KW h RS485 po tal energy	rt & simeter w	oftware. ith dual reading	(Wh, De	ing true	
	Volt in H with Digi RMS pow	z, KVA, KW h RS485 po tal energy S value of " ver factors,	, KVAR, ort & si meter w Three wo frequer	oftware. Ath dual reading Ditages, Three Co Tocy in HZ, KVA,	(Wh, De Indicati urrents, KW, KV	ing true three AR, KVAh,	
8	Volt in H with Digi RMS pow	z, KVA, KW h RS485 po tal energy S value of " ver factors,	, KVAR, ort & si meter w Three wo frequer	oftware. And the second	(Wh, De Indicati urrents, KW, KV	ing true three AR, KVAh,	
8	Volt in H with Digi RMS pow	z, KVA, KW h RS485 po tal energy S value of " ver factors,	, KVAR, ort & si meter w Three wo frequer	oftware. Ath dual reading Ditages, Three Co Tocy in HZ, KVA,	(Wh, De Indicati urrents, KW, KV	ing true three AR, KVAh,	
8	volt in H with Digi RMS pow KVA	IZ, KVA, KW n RS485 pc tal energy S value of ' ver factors, Rh,KWh, D	/, KVAR, ort & si meter w Three vo frequer emand,	oftware. hth dual reading pltages, Three Concy in HZ, KVA, with RS485 po	(Wh, De Indicat urrents, KW, KV, int & si	ing true three AR, KVAh, oftware.	
	volt in H with Digi RMS pow KVA	Z, KVA, KW h R5485 pc tal energy S value of ' ver factors, Rh,KWh, D	/, KVAR, ort & si meter w Three vo frequer remand,	A FOOTBAI	(Wh, De Indicat urrents, KW, KV, rt & sk	ing true three AR, KVAh, oftware.	DN
	volt in H with Digi RMS pow KVA	Z, KVA, KW h R5485 pc tal energy i S value of ' ver factors, Rh,KWh, D	/, KVAR, ort & si meter w Three vo frequer remand, all House a, New I	A FOOTBAI e, Sector 19, Pha Delhi: 110075	(Wh, De Indicat urrents, KW, KV, rt & sk	ing true three AR, KVAh, oftware.	DN
	volt in H with Digi RMS pow KVA	Z, KVA, KW h R5485 pc tal energy S value of ' ver factors, Rh,KWh, D ALL Footba Dwark Tel- 9 Fax- 9	INDI/ all House a, New I 1-11-25 1-11-25	A FOOTBAI e, Sector 19, Pha Delhi: 110075 308230/ 201 308234/ 253082	L FE	ing true three AR, KVAh, oftware.	DN
	NT	Z, KVA, KW h R5485 pc tal energy i S value of ' ver factors, Rh,KWh, D ALL Footba Dwark Tel- 9 Fax- 9 Email-	INDI/ all House a, New I 1-11-25 1-11-25	A FOOTBAI e, Sector 19, Pha Delhi: 110075 308200/ 201	L FE	ing true three AR, KVAh, oftware.	DN
	NT	Z, KVA, KW h R5485 pc tal energy S value of ' ver factors, Rh,KWh, D ALL Footba Dwark Tel- 9 Fax- 9	INDI/ all House a, New I 1-11-25 1-11-25	A FOOTBAI e, Sector 19, Pha Delhi: 110075 308230/ 201 308234/ 253082	L FE	ing true three AR, KVAh, oftware.	DN
		Z, KVA, KW h R5485 pc tal energy i S value of ' ver factors, Rh,KWh, D ALL Footba Dwark Tel- 9 Fax- 9 Email- FECT	INDI/ all House a, New I 1-11-25 1-11-25	A FOOTBAI e, Sector 19, Pha Delhi: 110075 308200/ 201 308234/ 253082 te-aiff.com	LL FE ase 1, 36	DERATIO	LTD
		Z, KVA, KW h RS485 pc tal energy i S value of ' ver factors, Rh,KWh, D ALL Footba Dwark Tel- 9 Fax- 9 Email- FECT	INDI/ all House a, New I 1-11-25 1-11-25	A FOOTBAI e, Sector 19, Pha Delhi: 110075 308200/ 201 308234/ 253082 he-aiff.com	CWh, De Indicat urrents, KW, KV, rt & se LL FE ise 1, 236	Ing true three AR, KVAh, oftware.	LTE n Rd
		Z, KVA, KW h RS485 pc tal energy i S value of ' ver factors, Rh,KWh, D ALL Footba Dwark Tel- 9 Fax- 9 Email- FECT	INDI/ all House a, New I 1-11-25: aiff@th	A FOOTBAI e, Sector 19, Pha Delhi: 110075 308200/201 308234/253082 ne-aiff.com	CWh, De Indicat urrents, KW, KV, rt & si LL FE ise 1, 236	DERATIO	LTE n Rd
		Z, KVA, KW h RS485 pc tal energy i S value of ' ver factors, Rh,KWh, D ALL Footba Dwark Tel-9 Fax-9 Email- FECT Sec ( RH) (MCE/2)	INDI/ all House a, New I 1-11-25: aiff@th	A FOOTBAI e, Sector 19, Pha Delhi: 110075 308200/ 201 308234/ 253082 he-aiff.com	CWh, De Indicat urrents, KW, KV, rt & se LL FE ise 1, 2574 08 lagese	DERATIO	LTE n Rd
		Z, KVA, KW h RS485 pc tal energy i S value of ' ver factors, Rh,KWh, D ALL Footba Dwark Tel-9 Fax-9 Email- FECT Sec ( RH) (MCE/2)	INDI/ all House a, New I 1-11-25: aiff@th	A FOOTBAI a, Sector 19, Pha Delhi: 110075 308200/ 201 308234/ 253082 he-aiff.com COLLA 300 Se Victoral 451 22 1SULTANT	CWh, De Indicat urrents, KW, KV, rt & se LL FE ise 1, 236	DERATIO	LTD n Rd 1 083
		Z, KVA, KW h RS485 pc tal energy i S value of ' ver factors, Rh,KWh, D ALL Footba Dwark Tel-9 Fax-9 Email- FECT Sec ( RH) (MCE/2)	INDI/ all House a, New I 1-11-25: aiff@th	A FOOTBAI e, sector 19, Pha Delhi: 110075 308200/201 308234/253082 re-aiff.com	KWh, De Indicati urrents, KW, KV, rt & sk LL FE ase 1, 236 GE DE Samp East 0 Lagese Lagese and As ts Pvt. mavati H Road, V	Ing true three AR, KVAh, oftware. DERATIO	LTD n Rd 1 003
		Z, KVA, KW h R5485 pc tal energy i S value of ' ver factors, Rh,KWh, D ALL Footba Dwark Tel. 9 Fax- 9 Email- TECT SC ( TURAL	INDI/ all House a, New I 1-11-25: aiff@th	A FOOTBAI experimental states of the second swith RS485 points with RS485 points with RS485 points and second seco	CWh, De Indicati urrents, KW, KV, rt & sk LL FE ase 1, 236 GE DE Samp East 0 Lagese lagese and As ts Pvt. mavati H I Road, V 057.	DERATIO	LTD n Rd 1 003
		Z, KVA, KW A R5485 pc tal energy i S value of ' ver factors, Rh,KWh, D ALL Footba Dwark Tel- 9 Fax- 9 Email- FECT SCCI SCCI	INDI/ all House a, New I 1-11-25: aiff@th	A FOOTBAI e, sector 19, Pha Delhi: 110075 308200/ 201 308234/ 253082 re-aiff.com	CWh, De Indicati urrents, KW, KV, rt & sk LL FE ase 1, 236 GE DE Samp East 0 Lagese lagese and As ts Pvt. mavati H I Road, V 057.	DERATIO	LTD n Rd 1 083
		Z, KVA, KW h R5485 pc tal energy i S value of ' ver factors, Rh,KWh, D ALL Footba Dwark Tel. 9 Fax- 9 Email- TURAL SACI SACI	INDI/ all House a, New I 1-11-25: aiff@th CON	A FOOTBAI a, sector 19, Pha Delhi: 110075 308200/ 201 308234/ 253082 he-aiff.com ISULTANT Shanghvi a Consultant 7th Floor, Pad Shraddhanand Mumbai - 4000 Tel - +91 22 2 22 2617 1804	LL FE se 1, 236	DERATIO	LTE n Rd 1 083
		Z, KVA, KW h R5485 pc tal energy i S value of ' ver factors, Rh,KWh, D ALL Footba Dwark Tel-9 Fax-9 Email- TURAL SACI SACI CT AL CEN	INDI/ all House a, New I 1-11-25: 1-11-25: aiff@th CON	A FOOTBAI experimental states of the second swith RS485 points with RS485 points with RS485 points and second seco	LL FE se 1, 236	DERATIO	LTD n Rd 1 003
		Z, KVA, KW h R5485 pc tal energy i S value of ' ver factors, Rh,KWh, D ALL Footba Dwark Tel-9 Fax-9 Email- TURAL SACI SACI CT AL CEN	INDI/ all House a, New I 1-11-25 1-11-25 aiff@th CON	A FOOTBAI e, sector 19, Pha Delhi: 110075 308230/ 201 308234/ 253082 he-aiff.com	LL FE se 1, 236	DERATIO	LTE n Rd 1 083
		Z, KVA, KW RS485 pc tal energy i S value of ' ver factors, Rh,KWh, D ALL Footba Dwark Tel- 9 Fax- 9 Email- FECT SAL CEN BALL CEN BALL CEN TURAL	INDI/ all House a, New I 1-11-25: aiff@th CON PL JTRE @ RA	A FOOTBAI e, sector 19, Pha Delhi: 110075 308230/ 201 308234/ 253082 he-aiff.com	LL FE se 1, 236 GE DE Samp East 1 2574 00 Lagede Samp East 1 2574 00 Lagede Samp East 1 2574 00 Lagede Lagede Lage	DERATIO	LTE n Rc 1 083
		Z, KVA, KW RS485 pc tal energy i S value of ' ver factors, Rh,KWh, D ALL Footba Dwark Tect Fax- 9 Email- Fax- 9 Email- Fax- 9 Email- TURAL SACI RE   INTER TURAL SACI RE   INTER TURAL SACI RE   INTER TURAL SACI RE   INTER TURAL	INDI/ all House a, New I 1-11-25: 1-11-25: aiff@th CON PL JTRE @ RA	A FOOTBAI a, sector 19, Pha Delhi: 110075 308200/ 201 308234/ 253082 15ULTANT Shanghvi a Consultant 7th Floor, Pad Shraddhanand Mumbai - 4001 Tel - + 91 22 2 22 2617 1804 OF EXCEL AJRAHAT, I E DRAWI	LL FE se 1, 236 GE DE Samp East 1 2574 00 Lagede Samp East 1 2574 00 Lagede Samp East 1 2574 00 Lagede Lagede Lage	DERATIO	LTD n Rd 1 / 45
		Z, KVA, KW RS485 pc tal energy i S value of ' ver factors, Rh,KWh, D ALL Footba Dwark Tel-9 Fax-9 Email- TURAL SACCI RECT AL CEN BALL CEN BALL CEN ING TIT NGLE	INDI/ all House a, New I 1-11-25: 1-11-25: aiff@th CON PL JTRE @ RA	A FOOTBAI a, sector 19, Pha Delhi: 110075 308200/ 201 308234/ 253082 15ULTANT Shanghvi a Consultant 7th Floor, Pad Shraddhanand Mumbai - 4001 Tel - + 91 22 2 22 2617 1804 OF EXCEL AJRAHAT, I E DRAWI	LL FE se 1, 236 GE DE Samp East 1 2574 00 Lagede Samp East 1 2574 00 Lagede Samp East 1 2574 00 Lagede Lagede Lage	DERATIO	1 0.
		Z, KVA, KW RS485 pc tal energy i S value of ' ver factors, Rh,KWh, D ALL Footba Dwark Tect Fax- 9 Email- Fax- 9 Email- Fax- 9 Email- TURAL SACI RE   INTER TURAL SACI RE   INTER TURAL SACI RE   INTER TURAL SACI RE   INTER TURAL	INDI/ all House a, New I 1-11-25: aiff@th CON DL JTRE @ RA TLE LINE	A FOOTBAI a, sector 19, Pha Delhi: 110075 308200/ 201 308234/ 253082 15ULTANT Shanghvi a Consultant 7th Floor, Pad Shraddhanand Mumbai - 4001 Tel - + 91 22 2 22 2617 1804 OF EXCEL AJRAHAT, I E DRAWI	LL FE se 1, 236 GE DE Samp East 1 2574 00 Lagede Samp East 1 2574 00 Lagede Samp East 1 2574 00 Lagede Lagede Lage	DERATIO	1 0.
		Z, KVA, KW RS485 pc tal energy i S value of ' ver factors, Rh,KWh, D ALL Footba Dwark Tel. 9 Fax- 9 Email- FECT AL CEN TURAL CT AL CEN TURAL CT AL CEN TAL CEN	INDI/ all House a, New I 1-11-25: aiff@th CON DL JTRE @ RA TLE LINE	A FOOTBAI a, sector 19, Pha Delhi: 110075 308234/ 253082 ISULTANT Shanghvi a Consultant 7th Floor, Pad Shraddhanand Mumbai - 4001 Tel - + 91 22 2 22 2617 1804 OF EXCEL AJRAHAT, I E DRAWI EP-13	LL FE se 1, 236 GE DE Samp East 1 2574 00 Lagede Samp East 1 2574 00 Lagede Samp East 1 2574 00 Lagede Lagede Lage	DERATIO	1 0.
		Z, KVA, KW h RS485 pc tal energy i S value of ver ractors, Rh,KWh, D ALL Footba Dwark Tect Fax- 9 Email- Fax- 9 Email- Fax- 9 Email- TURAL SACCI AL CEN BALL ( NG TI AL CEN BALL ( NG TI NGLE NO. TD-DI T NO. ED ON	INDI/ all House a, New I 1-11-25: 1-11-25: aiff@th CON CON FLE LINE R-MI 18	A FOOTBAI a, sector 19, Pha Delhi: 110075 308234/ 253082 ISULTANT Shanghvi a Consultant 7th Floor, Pad Shraddhanand Mumbai - 4001 Tel - + 91 22 2 22 2617 1804 OF EXCEL AJRAHAT, I E DRAWI EP-13	LL FE se 1, 236 GE DE Samp East 1 2574 00 Lagede Samp East 1 2574 00 Lagede Samp East 1 2574 00 Lagede Lagede Lage	DERATIO	1 0.
		Z, KVA, KW RS485 pc tal energy i S value of ver Factors, Rh, KWh, D ALL Footba Dwark Tect Factors Factors Fa	INDI/ all House a, New I 1-11-25 1-11-25 aiff@th I I I I I I I I I I I I I I I I I I I	A FOOTBAI e, sector 19, Pha Delhi: 110075 308234/ 253082 he-aiff.com Shanghvi a Consultant 7th Floor, Pad Shraddhanand Mumbai - 400 Tel - +91 22 2 22 2617 1804 OF EXCEL AJRAHAT, I A FOOTBAI a Shanghvi a Consultant 7th Floor, Pad Shraddhanand Mumbai - 400 Tel - +91 22 2 22 2617 1804	LL FE se 1, 236 GE DE Samp East 1 2574 00 Lagede Samp East 1 2574 00 Lagede Samp East 1 2574 00 Lagede Lagede Lage	DERATIO	1 0.
		Z, KVA, KW RS485 pc tal energy Svalue of ver factors, Rh,KWh, D ALL Footba Dwark Tel. 9 Fax. 9 Email- Fax. 9 Email- Fax. 9 Email- TURAL SALL OUR TURAL SALL OUR TURAL SALL OUR TURAL SALL OUR TURAL SALL OUR TURAL SALL OUR TURAL SALL OUR TURAL SALL OUR TURAL SALL OUR TURAL SALL OUR TO-DI TNO. TD-DI TNO.	INDI/ all House a, New I I-11-25: aiff@th CON CON CON CON CON CON CON	A FOOTBAI e, sector 19, Pha Delhi: 110075 308234/ 253082 he-aiff.com Shanghvi a Consultant 7th Floor, Pad Shraddhanand Mumbai - 4000 Tel - +91 22 2 22 2617 1804 OF EXCEL AJRAHAT, I COF EXCEL AJRAHAT, I E DRAWI Shanghvi a Consultant 7th Floor, Pad Shraddhanand Mumbai - 4000 Tel - +91 22 2 22 2617 1804	LL FE se 1, 236 GE DE Samp East 1 2574 00 Lagede Samp East 1 2574 00 Lagede Samp East 1 2574 00 Lagede Lagede Lage	DERATIO	1 0.


NOTES -
ALL MODE'S WILL HAVE 2ND + 2ND ALXILIARY CONTACTS FOR BMS CM/OFF & TRIP.
ALL MODY'S WILL HE OF 3NA WHEREVER NOT SPECIFIED/MORCATED.
ALL MODY'S WILL HAVE MURDPROCESSOR RELEASE FOR SUCJULAE/F
HOTERTON WHEREVER NOT SPECIFIED/INDICATED.
ALL MOD'S WILL BE OF TOKA MHEREVER NOT SPECIFIED/INDICATED.
ALL MOD'S WILL BE OF TOKA MHEREVER NOT SPECIFIED/INDICATED.
ALL MOD'S WILL BE OF TOKA MHEREVER NOT SPECIFIED/INDICATED.
ALL MOD'S WILL BE OF TOKA MHEREVER NOT SPECIFIED/INDICATED.
ALL MOD'S WILL BE OF TOKA MHEREVER NOT SPECIFIED AFTER GETTING FINAL
HWW COMFOURATION.
HWW COMFOURATION.
TO THE CONTROL SCHEMATICS BHOLD BE THROUGH PLC COMPATIBLE TO
BMS(SEPARATE OUTPUT DF PLC SHOULD BE AMOLTABLE TO
BMS(SEPARATE OUTPUT DF PLC SHOULD EN AVAILABLE TO
BMS(SEPARATE OUTPUT DF PLC SHOULD AND AVAILABLE TO
BMS(SEPARATE ON TO BE PROVIDED MHERE EVER REQUIRED MHICH CAU GIVE
SATTERES SHARES TO HAVE TWO MHERE VER REQUIRED MAIL FACILITY WITH
SELECTOR SMITCH (VALIT) MAYE AND A AVAILABLE AVAILABLE TO OMAND FROM BWS
FOR UNDERSENT METALENER ON A BARCENER ALL DE COMMANDER TO ANANDAL FACILITY
10. THE STRUETES IN THE HAVE SWD + BANC AVAILABLY CONTACTS.
ALL MOTORISED MICED FROM SHOULD HAVE AUTO / MANDAL FACILITY WITH
SELECTOR SMITCH (VALIT) MAIL INVE INDICATON LAWES CONTACTS.
ALL MODY'S MOLE THAN THE MEDAL BAYE FOR ALL THE THREE PHAR GENERAL NOTES -MCCB RATING 2000A AND ABOVE WILL BE - BSKA MCCB RATING 1000A AND BOGA WILL BE - 50KA MCCB RATING 630A AND BELOW WILL BE- 36KA MCCB RATING 125A AND BELOW WILL BE- 25KA 1.0 SHUNT THP TO BE PROVDED FOR CONNECTING TO FIRE ALARM SB . 2.0 CONTROL DIT TO BUILT UP TO THP MAIN BREAKER WITH SIGNAL FROM FIRE ALARM 3.0 CAPACIDOR APEC SB SHALL BE ISOLATED DURING D.G. OPERATION & TO BE INTERLOCKED WITH D.G. SUPPLY ORCUIT BREAKER. 4.0 ALL MCCB WILL BE WITH MICHD PROCESSOR RELEASE FOR S/C, D/L & E/F FOR 400 A WED ABOVE S.O. ALL WCOB WILL BE WITH THERMAL RELEASE FOR S/C, O/L & ELECTRONIC E/F FOR 250 A AND BELLOW (WITH DBCT) 6.0 ALL ACE TO HAVE MICROPROCESSOR RELEASE FOR S/C D/L & E/EWITH DBCT) 

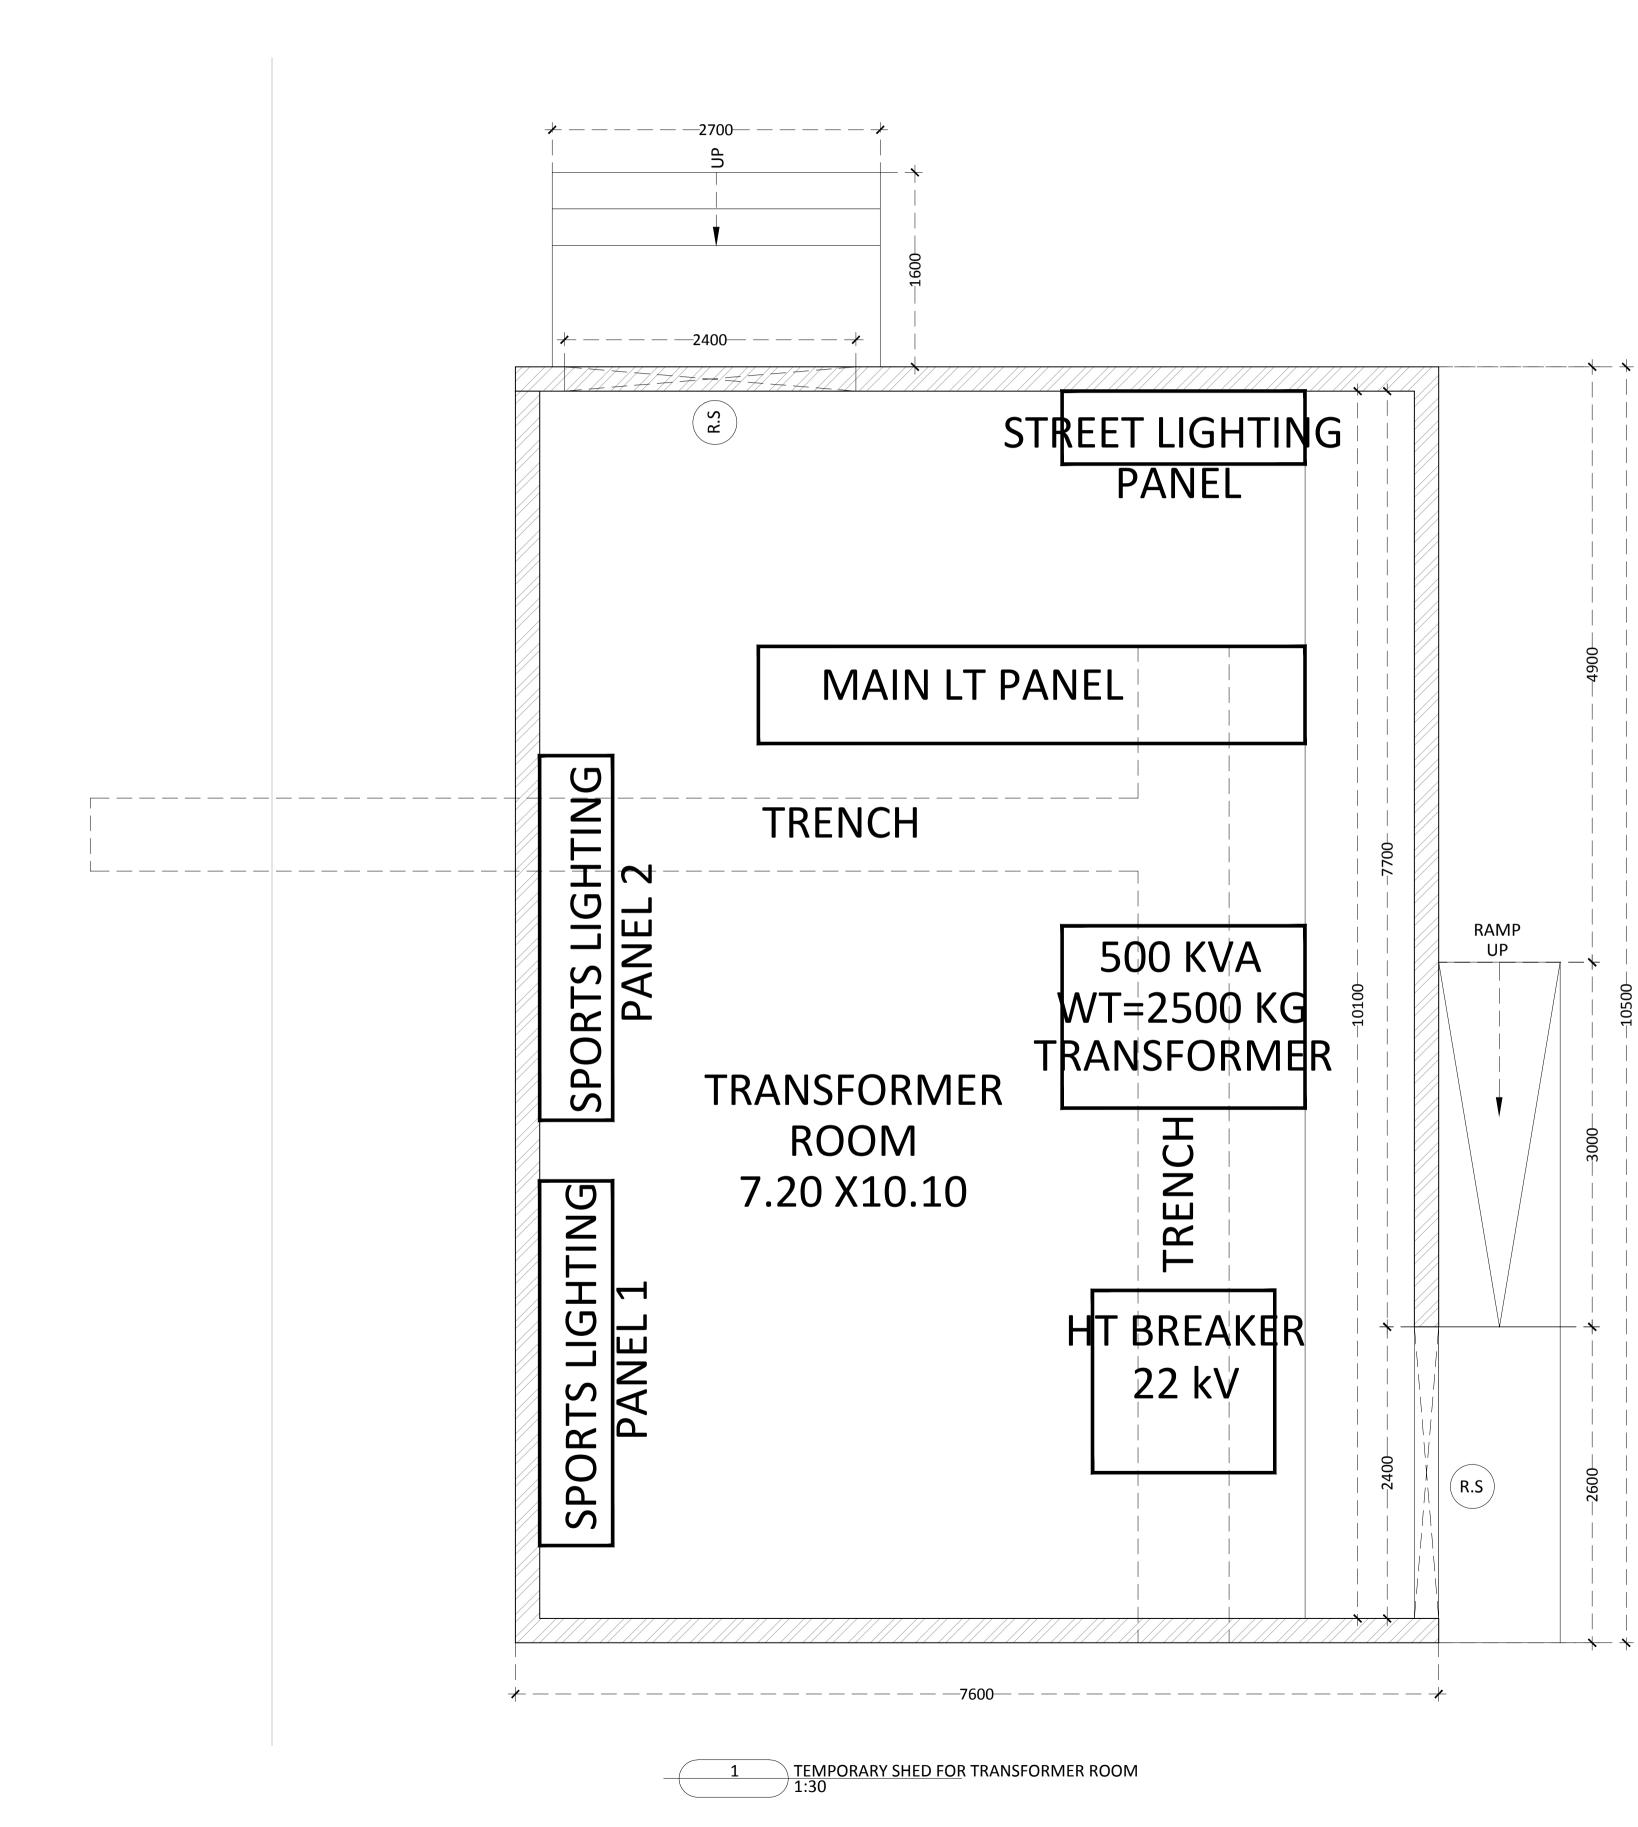

TENDER DRAWING							
GENERAL NOTES							
UNLES	S OTHERWISE SP	ECIFIED.	ERS AND LEVELS				
2. ALL DIMENSIONS ARE TO BE CHECKED AND CO-RELATED WITH THE RELEVANT ARCHITECTURAL, STRUCTURAL AND SERVICES DRAWINGS AND ANY AMBIGUITY, DISCREPANCY OR OMISSION SHALL BE BROUGHT IN TO NOTICE OF ARCHITECT							
PRIOR TO COMMENCEMENT OF EXECUTION. 3. DO NOT SCALE THE DRAWING, WRITTEN DIMENSION TO BE FOLLOWED.							
4. THIS DRAWING TO BE READ IN CONJUNCTION WITH THE RELEVANT SERVICES AND STRUCTURAL DRAWINGS.							
	SIONS						
REV	D	ESCRIPT	ION	DATE			
KEY PLAN							
ĺ							
ĺ							
ĺ							
<u></u>	. <del></del>						
CLIEN		NDIA F	OOTBALL F	EDERATION			
INDIA	Football Dwarka,	House, Se New Delhi	ctor 19, Phase 1, : 110075				
	Tel- 91- Fax- 91-	11-253082 11-253082	00/ 201 34/ 25308236				
	Email- a	iff@the-ai	1.com				
			COLLAGE	DESIGN PVT. LTD			
<b>colla</b> des			300, Sai Sam Vikhroli East,	panna, Station Rd Mumbai 400 083			
		RS   PMC	+91 22 2574 www.collagec	0842 / 43 / 44 / 45 design.net			
STRU	CTURAL (	CONSU	ILTANT				
			anghvi and				
		7+	nsultants Pv Floor, Padmava	ti Heights,			
	SACP	IVIL	raddhanand Road mbai - 400057.				
			- +91 22 2614 4 2617 1804	1032, Fax - +91			
PROJECT							
NATIONAL CENTRE OF EXCELLENCE IN FOOTBALL @ RAJRAHAT, KOLKATA							
			AITAT, KUL	INATA			
	EVELOPM		דווכ				
DWG. NO. REV. NO. TD-A.0.05							
		1		RO			
	CT NO.	18-Р 1:30	245	Νοστυ			
SCALE 1 <sup>st</sup> ISSU	: JED ON	1:30 18-02-	2019	NORTH			
APPR		RS					
CHEC DRAW		BD					
		עט					

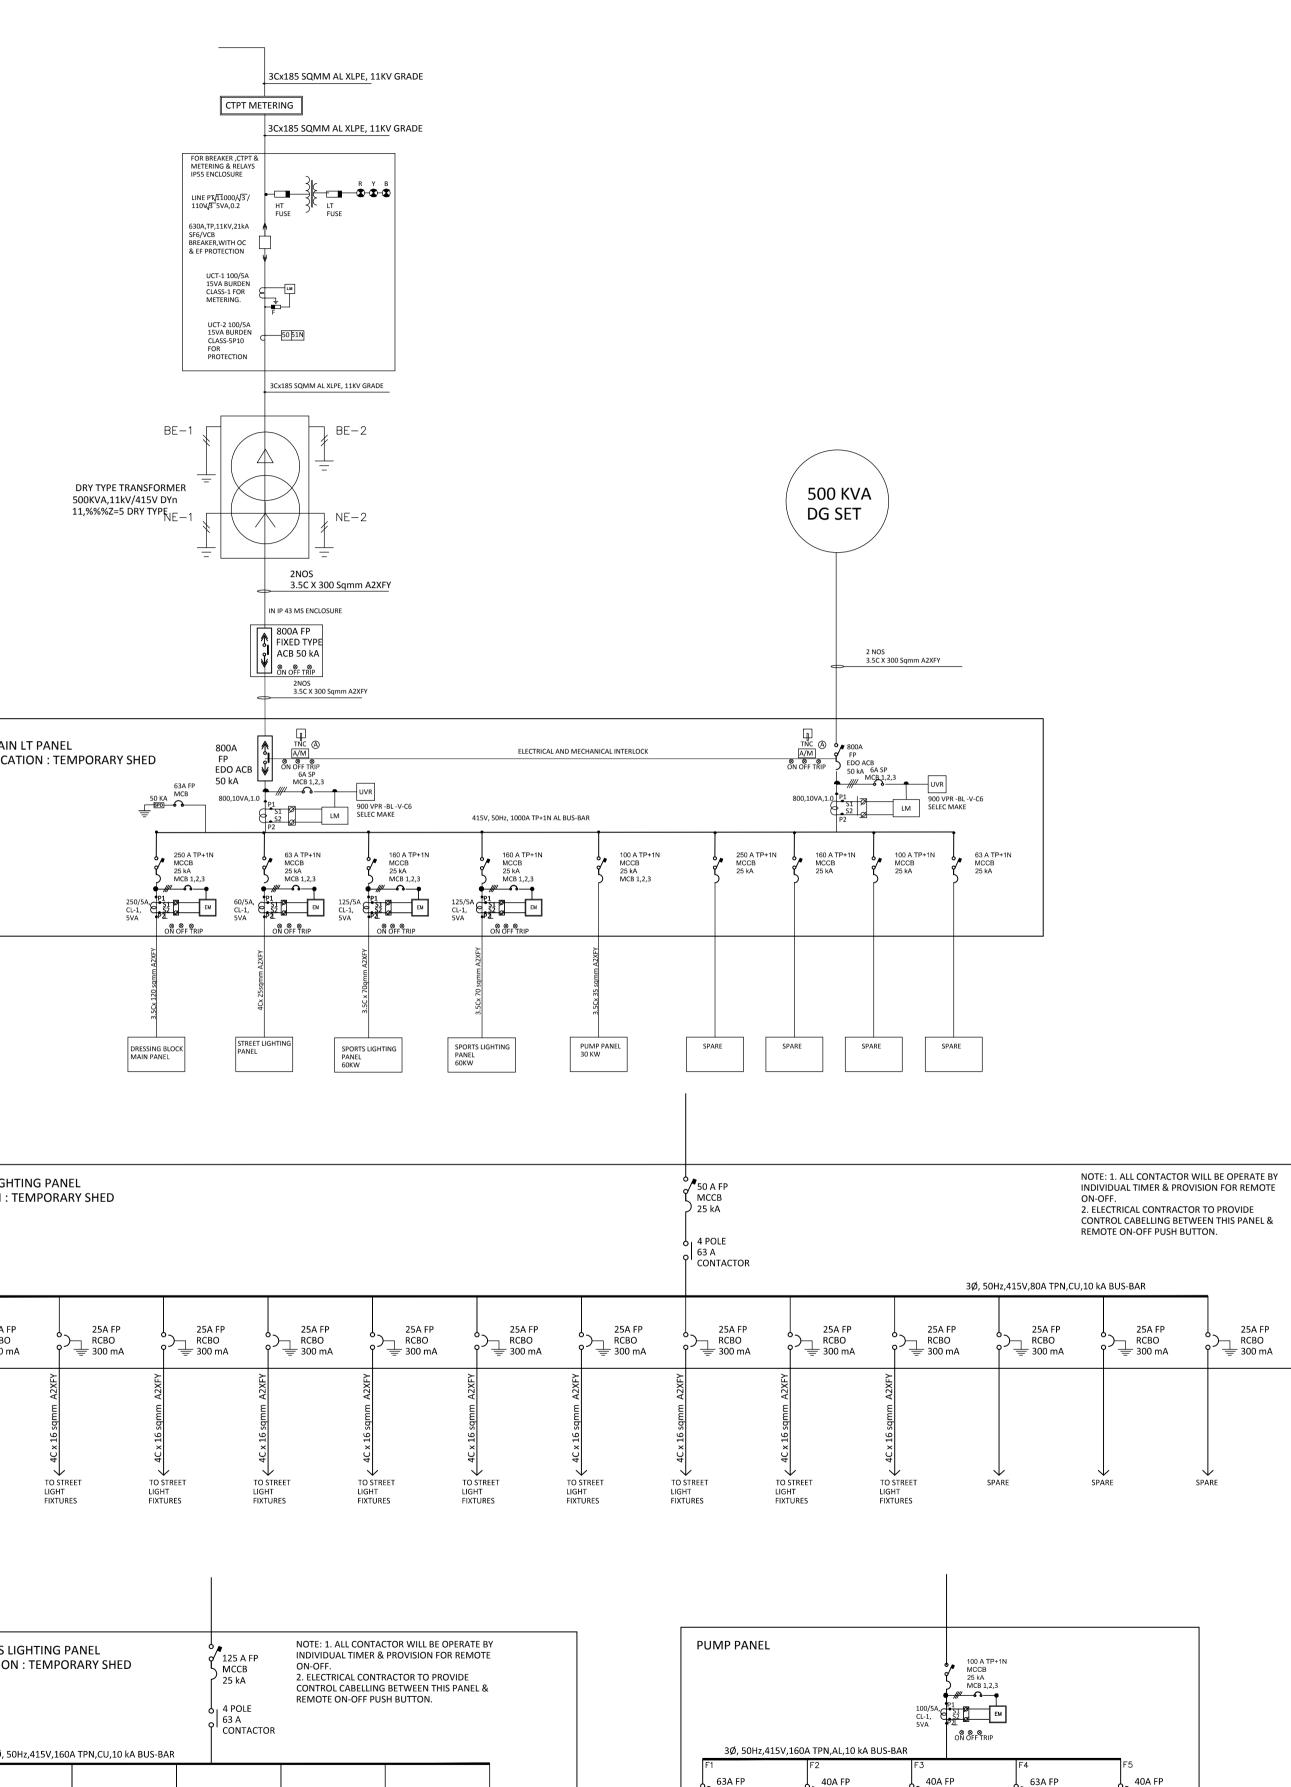

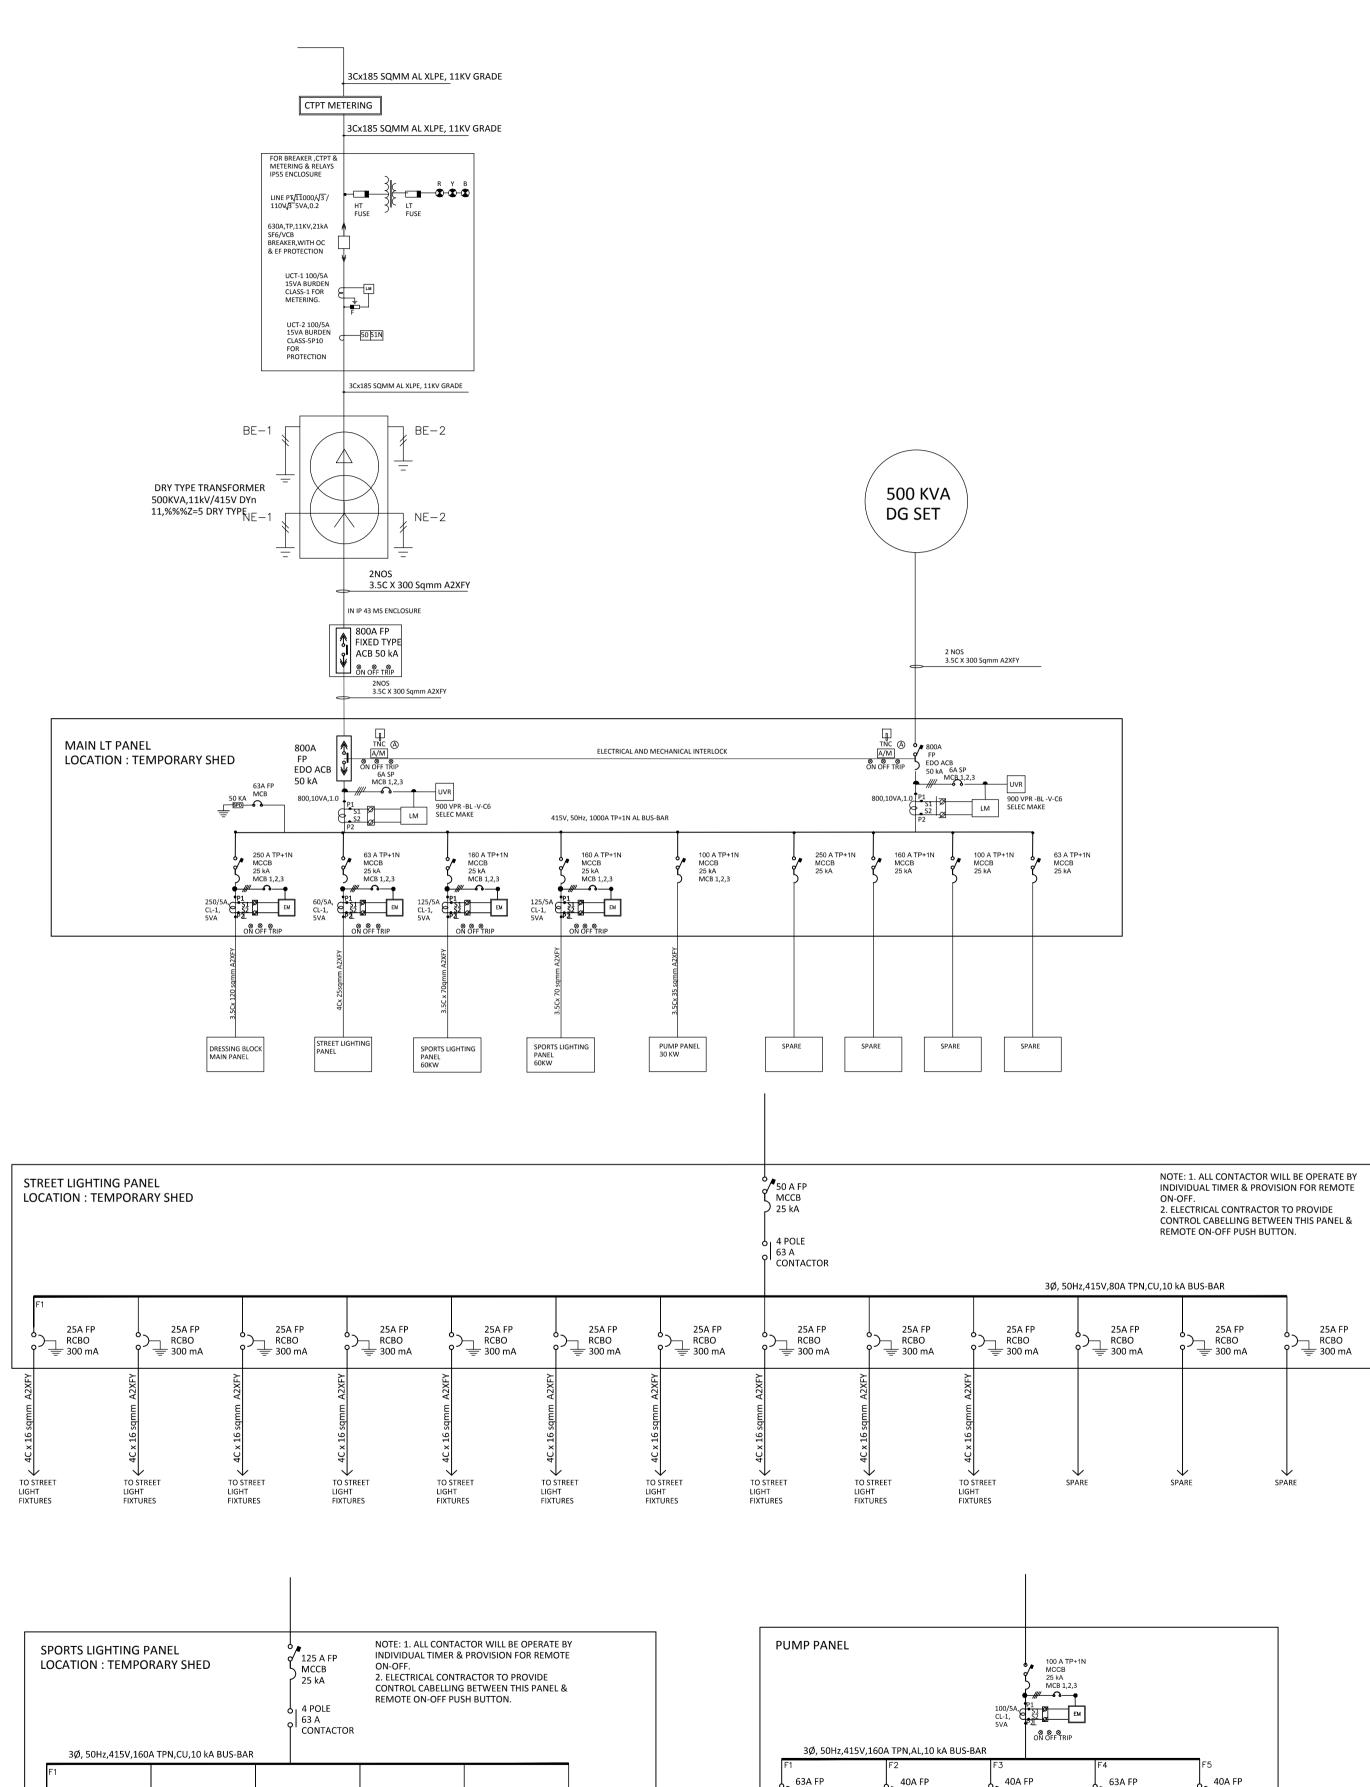

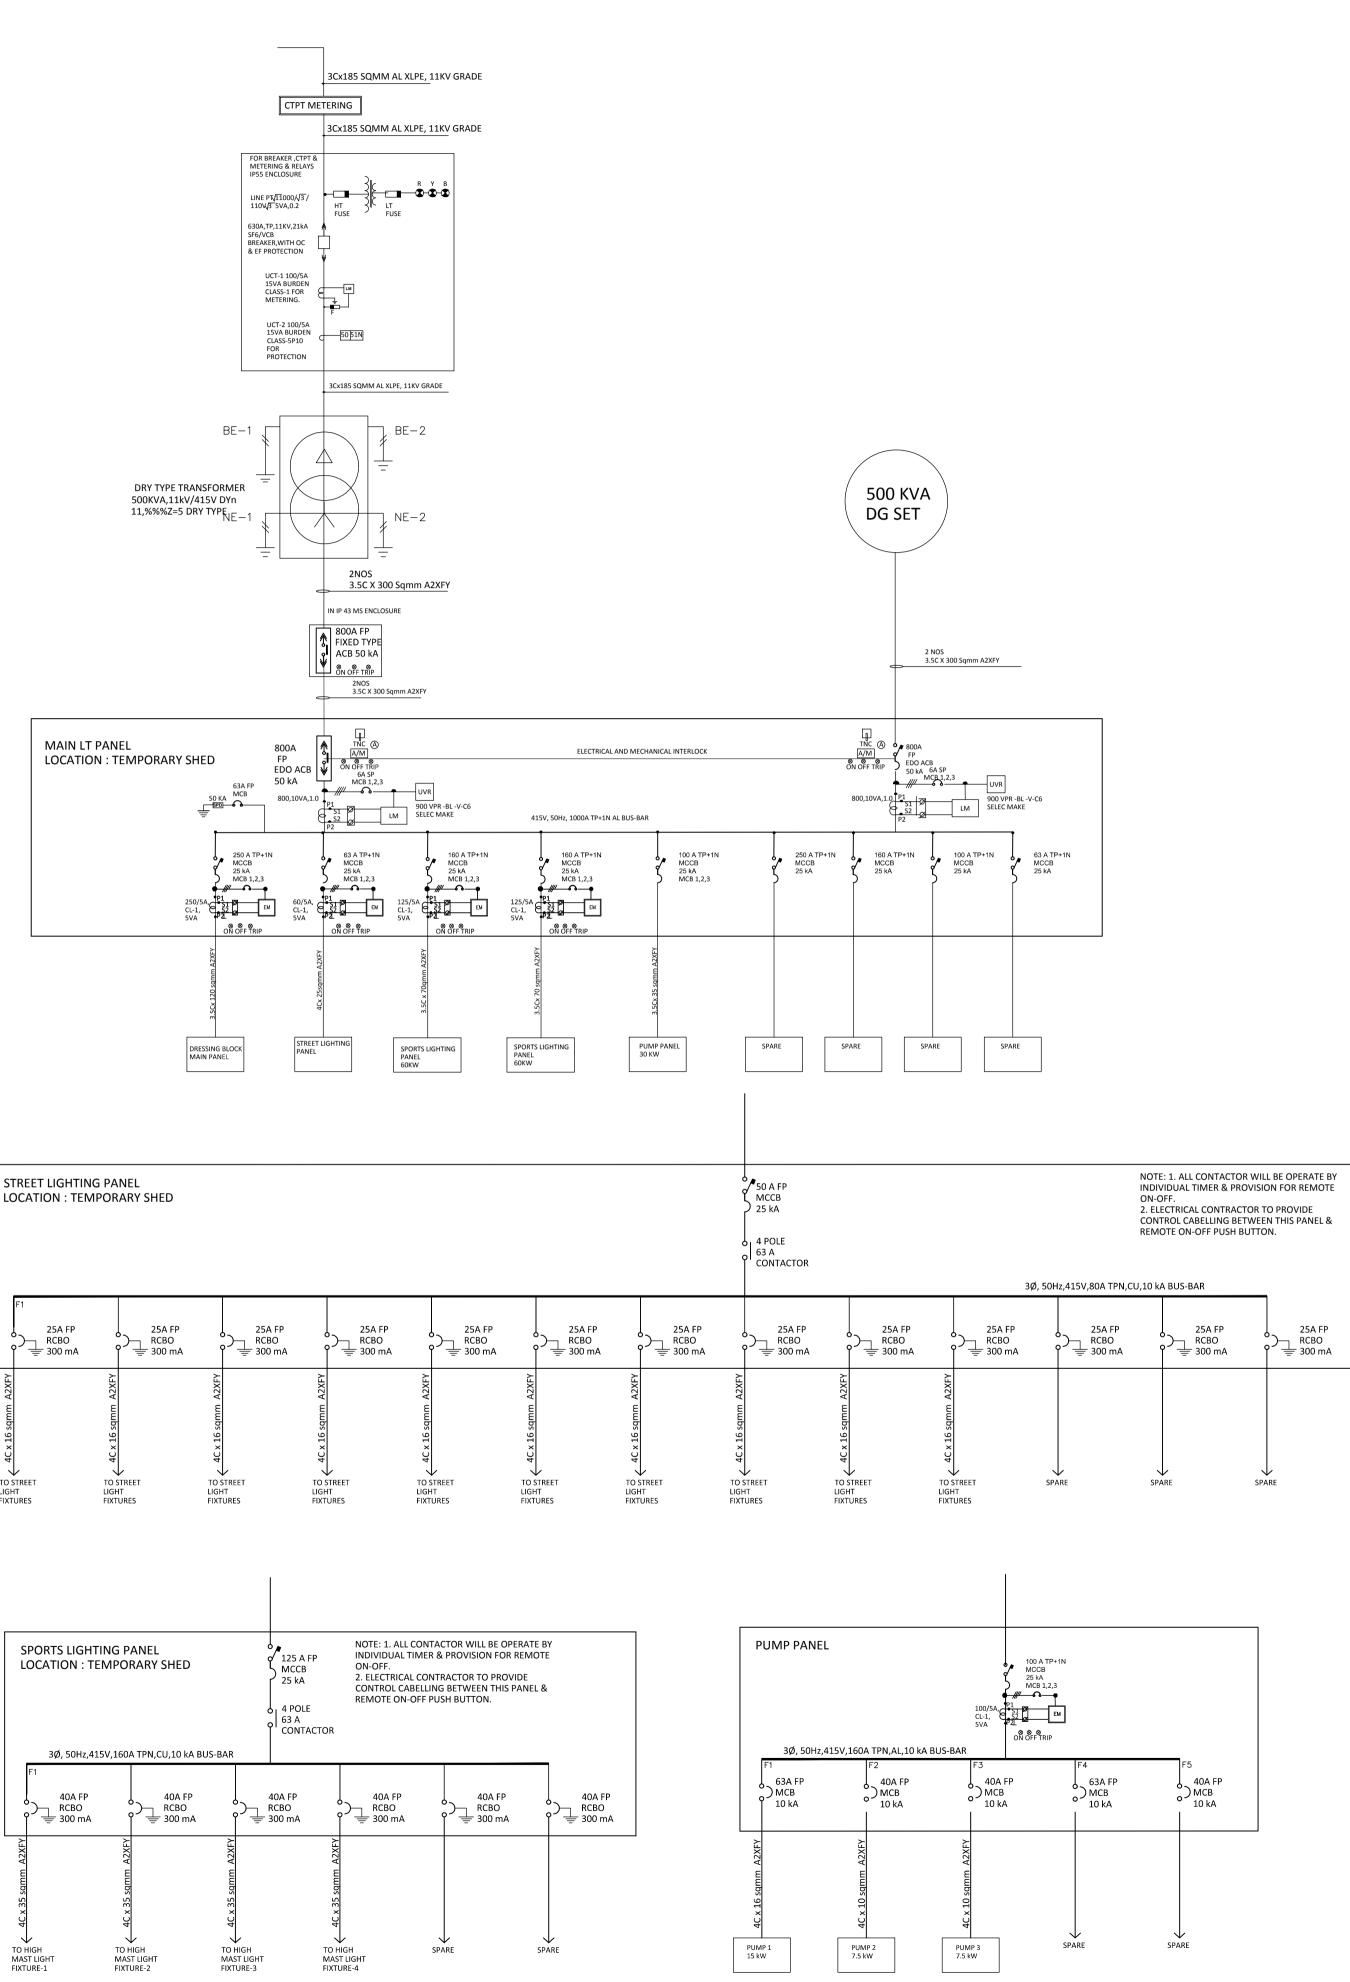

TENDER DRAWING								
GENERAL NOTES								
UNLESS 2. ALL DIN	<ol> <li>ALL DIMENSIONS ARE IN MILLIMETERS AND LEVELS ARE IN METER UNLESS OTHERWISE SPECIFIED.</li> <li>ALL DIMENSIONS ARE TO BE CHECKED AND CO-RELATED</li> </ol>							
WITH THE RELEVANT ARCHITECTURAL, STRUCTURAL AND SERVICES DRAWINGS AND ANY AMBIGUITY, DISCREPANCY OR OMISSION SHALL BE BROUGHT IN TO NOTICE OF ARCHITECT PRIOR TO COMMENCEMENT OF EXECUTION.								
<ol> <li>DO NOT SCALE THE DRAWING, WRITTEN DIMENSION TO BE FOLLOWED.</li> <li>THIS DRAWING TO BE READ IN CONJUNCTION WITH THE</li> </ol>								
RELEVANT SERVICES AND STRUCTURAL DRAWINGS.								
REVISIONS								
REV	D	ESCRIPT	ION	DATE				
KEY P	KEY PLAN							
CLIEN								
INDIA	Football	House, Se	ctor 19, Phase 1,	EDERATION				
	)   Tel- 91-	New Delhi 11-253082 11-253082						
ARCH	Email- a	iff@the-ai	f.com					
				DESIGN PVT. LTD				
<b>colla</b> des			Vikhroli East,	panna, Station Rd Mumbai 400 083 0842 / 43 / 44 / 45				
ARCHITEC	CTURE   INTERIOF	RS   PMC	www.collagec	lesign.net				
STRU	CTURAL (			A				
			anghvi and onsultants Pv					
	SACF	Sh Sh	l Floor, Padmavat raddhanand Road					
		Te	mbai - 400057.   - +91 22 2614 4 2617 1804	1832, Fax - +91				
PROJECT								
			EXCELLEN					
IN FOOTBALL @ RAJRAHAT, KOLKATA								
DRAWING TITLE								
SINGLE LINE DIAGRAM								
DWG	NO.			REV. NO.				
TD-E.								
	CT NO.	18-P	245	RO				
SCALE				NORTH				
1 <sup>s™</sup> ISSU APPR(	JED ON DVED	05-0 RP	2-19					
		JK						
	IN DI	IBRA						